


Sheet List Table	
Sheet Number	Sheet Title
1	COVER SHEET
2	PARKER WATER AND SANITATION NOTES
3	AREA UTILITY PLAN
4	AREA UTILITY PLAN
5	SANITARY P&P SCARLET SAGE AVE
6	SANITARY P&P SCARLET SAGE AVE
7	SANITARY P&P SCARLET SAGE AVE LATERALS
8	SANITARY P&P BEEBALM AVE
9	SANITARY SEWER DETAILS
10	SANITARY SEWER DETAILS
11	SANITARY SEWER DETAILS
12	WATER P&P SCARLET SAGE AVENUE
13	WATER P&P SCARLET SAGE AVENUE
14	WATER P&P SCARLET SAGE AVENUE
15	SCARLET SAGE AVENUE LATERALS
16	WATER P&P NORTH PINERY PARKWAY
17	WATER P&P NORTH PINERY PARKWAY
18	WATER P&P ALPINE PHLOX STREET
19	WATER P&P ALPINE PHLOX STREET
20	WATER DETAILS
21	WATER DETAILS
22	WATER DETAILS
23	WATER DETAILS
24	WATER DETAILS
25	WATER DETAILS
26	WATER DETAILS

MATERIAL LIST		
DESCRIPTION	QUANTITY	UNIT
8" SEWER (PVC)	1,142	L.F.
12" SEWER (PVC)	0	L.F.
4' DIA. MANHOLE	10	EA.
5' DIA. MANHOLE	0	EA.
STANDARD CLEANOUT	0	EA.
DROP MANHOLE	0	EA.
INTERMEDIATE PLATFORM	0	EA.
4" SEWER SERVICE	0	EA.
CONNECTION TO EXISTING MAIN	1	EA.
6" WATERPIPE (DIP)	211	L.F.
8" WATERPIPE (PVC)	4,079	L.F.
12" WATERPIPE (PVC)	1,081	L.F.
6" GATE VALVE	9	EA.
8" GATE VALVE	23	EA.
12" GATE VALVE	3	EA.
16" BUTTERFLY VALVE	0	EA.
8" MISC. FITTINGS	16	EA.
12" MISC. FITTINGS	6	EA.
AIR / VACUUM VALVE	2	EA.
8" CAP WITH BLOW OFF	11	EA.
2" BLOW OFF VALVE (8" LINE-LOW POINT)	1	EA.
FIRE HYDRANTS WITH 6" LEAD	9	EA.
IRRIGATION SERVICE W/ METER(2")	5	EA.
DOMESTIC WATER SERVICE W/ METER	0	EA.
20" STEEL CASING	0	L.F.
CONNECTION TO EXISTING MAIN	5	EA.

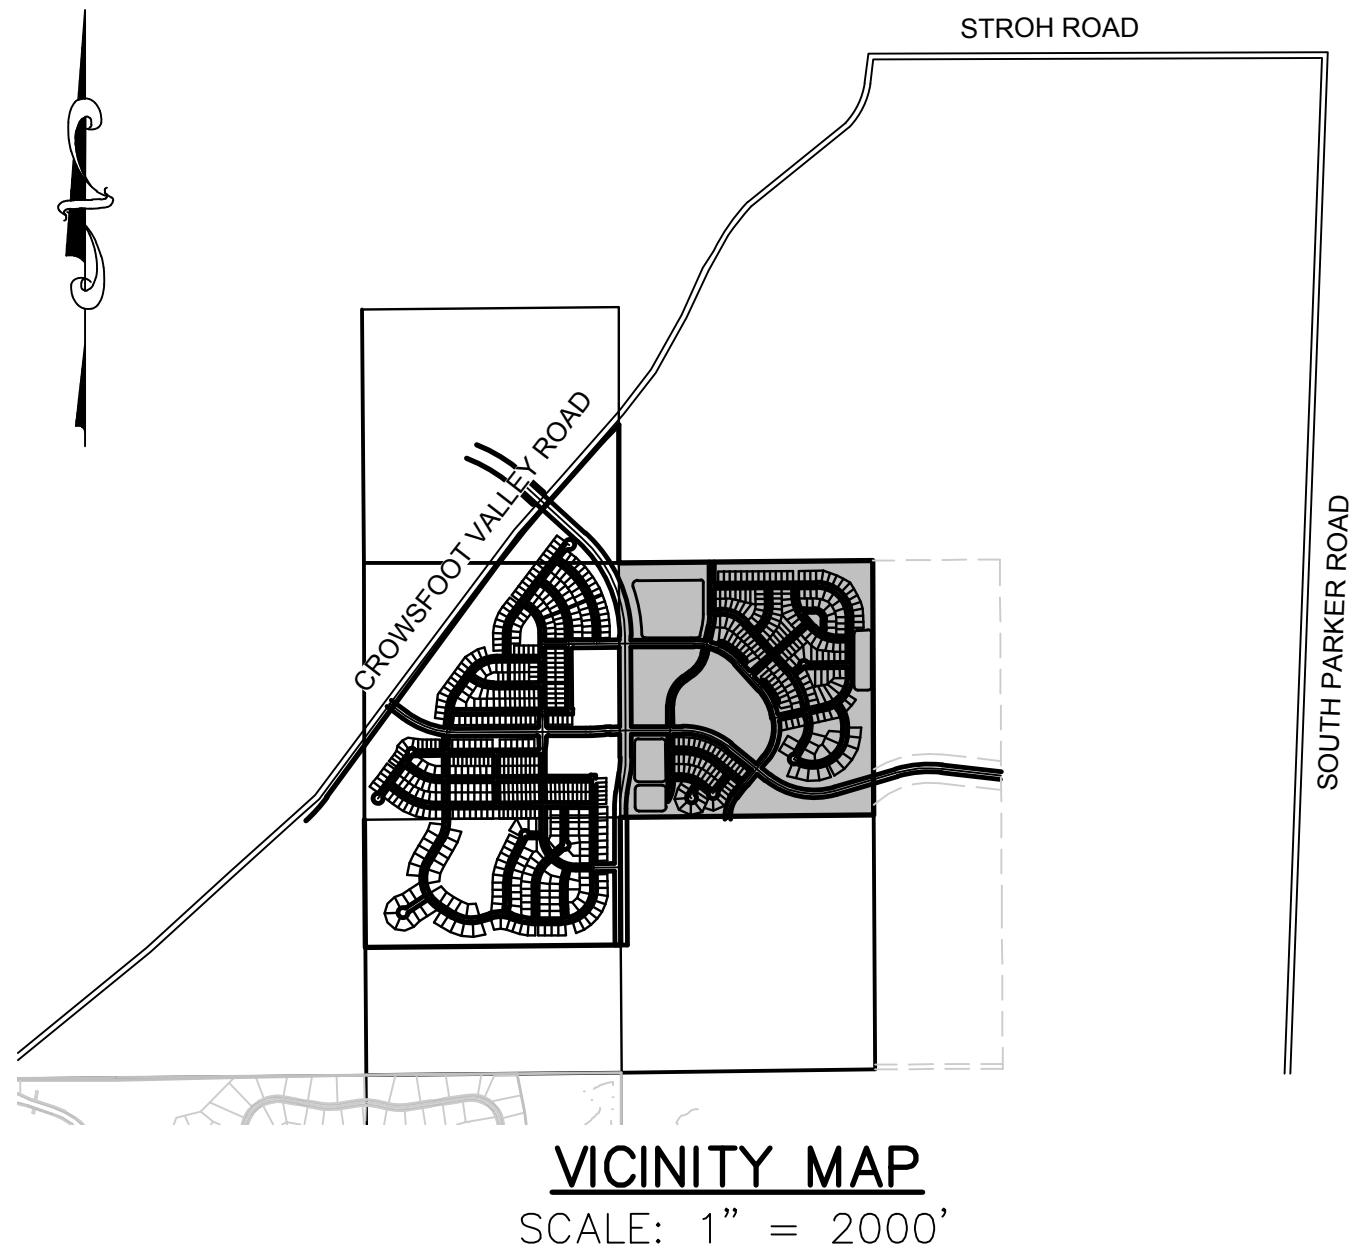

FIRE DEPARTMENT APPROVAL

ALL FIRE HYDRANTS SHALL BE INSTALLED ACCORDING TO WATER UTILITY STANDARDS. THE NUMBER AND LOCATIONS OF THE FIRE HYDRANTS AS SHOWN ON THE OVERALL UTILITY PLAN ARE CORRECT AS SPECIFIED BY THE TOWN OF PARKER, COMMUNITY DEVELOPMENT DEPARTMENT.

(FIRE CODE OFFICIAL OR DESIGNATED REPRESENTATIVE)	DATE
(NOTE- UNDERGROUND FIRE LINE (UFL) SUBMITTAL DOCUMENTS MUST MEET THE REQUIREMENTS OF NFPA24 WHEN SUBMITTING FOR REVIEW.)	

THE DISTRICT INSPECTOR MUST BE NOTIFIED AT LEAST 48 HOURS PRIOR TO START OF CONSTRUCTION. CALL PARKER WATER AND SANITATION DISTRICT AT 303-841-4627. THE DISTRICT WILL PROVIDE PERIODIC INSPECTIONS OF THE WORK. 24 HOUR NOTICE TO THE INSPECTOR IS REQUIRED FOR SCHEDULELINE INSPECTIONS. ANY WORK ACCOMPLISHED WITHOUT THE APPROVAL OF THE INSPECTOR WILL BE SUBJECT TO REJECTION.

REVIEWED FOR CONFORMANCE TO PARKER WATER AND SANITATION DISTRICT
STANDARDS.

BY: _____
(DISTRICT REPRESENTATIVE)

DATE SIGNED: _____

APPROVED FOR CONSTRUCTION:
PARKER WATER AND SANITATION DISTRICT

BY: _____
(DISTRICT ENGINEER)

DATE SIGNED: _____

PREPARED UNDER THE
SUPERVISION OF

BRIAN P. WILSON
COLORADO P.E. 0050067

DEVELOPER

HR 935 LLC
7353 SOUTH ALTON WAY
CENTENNIAL, CO 80112
TEL: (303) 770-9111
CONTACT: MATT JANKE

PLANNER/
LANDSCAPE
DESIGNER:

PCS GROUP, INC.
200 KALAMATH STREET
DENVER, CO 80233
TEL: (303) 531-4905
CONTACT: JOHN PRESTWICH

SURVEYOR/
ENGINEER:

**CVL CONSULTANTS
OF COLORADO, INC.**
10333 E. DRY CREEK RD. STE 240
ENGLEWOOD, CO 80112
TEL: (720) 482-9526
CONTACT: JIM JANNICKE

UTILITY DISTRICT

**PARKER WATER AND
SANITATION DISTRICT**
18100 E. WOODMAN DRIVE
PARKER, CO 80134
TEL: (303) 841-4627

BENCHMARK
DOUGLAS COUNTY CONTROL POINT KNOWN AS 1.060032, BEING A
3-1/4" ALUMINUM CAP, BEING LOCATED IN THE SOUTHWEST
QUARTER OF SECTION 33, TOWNSHIP 6 SOUTH, RANGE 66 WEST
OF THE SIXTH PRINCIPAL MERIDIAN, HAVING A PUBLISHED
ELEVATION OF 1799.2870 METERS (5903.13 FEET) NAVD '88 DATUM.

BASIS OF BEARINGS:
THE EAST LINE OF THE NORTHEAST QUARTER OF SAID SECTION 9
BEING MONUMENTED AT THE NORTHEAST CORNER OF SAID
SECTION 9 BY A 3-1/4" ALUMINUM CAP STAMPED LS 23053 AND AT
THE EAST QUARTER CORNER OF SAID SECTION 9 BY A 2-1/2"
ALUMINUM CAP STAMPED LS 6935 BEING CONSIDERED TO BEAR
SOUTH 00°15'06" EAST, 2648.70 FEET.



UNCC
UTILITY NOTIFICATION
CENTER OF COLORADO

CALL 811
TWO WORKING DAYS
BEFORE YOU DIG
1-800-922-1987

[illegible]

N:\PROJECTS\SSR\BANCOCAD\ENGINEERING\SSHEET SETS\CD\SS\9\PARKER WATER AND SANITATION\9\9 COVER.DWG, CDD\A, 2/28/2018 8:04 PM



UNCC
UTILITY NOTIFICATION
CENTER OF COLORADO

CALL 811

TWO WORKING DAYS

BEFORE YOU DIG

1-800-922-1987

GENERAL NOTES:

1. ALL CONSTRUCTION SHALL COMPLY WITH PARKER WATER AND SANITATION DISTRICT SPECIFICATIONS.
2. THE CONTRACTOR SHALL CONTACT ALL APPROPRIATE UTILITY COMPANIES AND THE TOWN OF PARKER PRIOR TO THE BEGINNING OF ANY CONSTRUCTION. CONTRACTOR SHALL BE RESPONSIBLE FOR LOCATING ANY EXISTING UTILITY (INCLUDING DEPTHS) WHICH MAY CONFLICT WITH THE PROPOSED CONSTRUCTION. ALL EXISTING UTILITIES SHALL BE PROTECTED FROM DAMAGE BY THE CONTRACTOR. DAMAGED UTILITIES SHALL BE REPAIRED BY THE CONTRACTOR AT HIS OWN EXPENSE.
3. ALL ITEMS SHOWN ON THE PLANS AS EXISTING ARE SHOWN IN APPROXIMATE LOCATIONS ONLY. THE ACTUAL LOCATIONS MAY VARY FROM THE PLANS, ESPECIALLY IN THE CASE OF UNDERGROUND UTILITIES. WHENEVER CONTRACTOR DISCOVERS A DISCREPANCY IN LOCATIONS, HE SHALL CONTACT THE ENGINEER IMMEDIATELY.
4. THE DISTRICT ENGINEER AND OTHER APPROVING AGENCIES ARE TO BE NOTIFIED AT LEAST 48 HOURS PRIOR TO CONSTRUCTION.
5. THE CONTRACTOR SHALL OBTAIN, AT HIS EXPENSE, ALL PERMITS THAT ARE NECESSARY TO PERFORM THE PROPOSED WORK.
6. ALL CONCRETE SHALL BE A MINIMUM OF CLASS A, 6 SACK, TYPE II, 3000-POUND COMPRESSION STRENGTH.
7. THE DESIGN ENGINEER SHALL SUBMIT ONE (1) SET OF ROLLED "AS-BUILT" BLUELINE PRINTS AND ELECTRONIC FILES TO THE DISTRICT ENGINEER FOR APPROVAL PRIOR TO PRINTING MYLAR SEPIAS FOR THE DISTRICT. AFTER APPROVAL HAS BEEN GRANTED BY THE DISTRICT ENGINEER, FULL SIZE MYLAR SEPIA PRINTS SHALL BE TRANSMITTED TO THE PARKER WATER AND SANITATION DISTRICT OFFICE.
8. ALL BACKFILL MATERIAL SHALL BE COMPACTED TO 95% STANDARD PROCTOR DENSITY. COMPACTION TESTS MUST BE SUBMITTED TO DISTRICT ENGINEER PRIOR TO PROBATIONARY ACCEPTANCE.
9. TRENCHES SHALL BE EXCAVATED AND THE PIPE EXPOSED FOR THE INSPECTION AT ANY LOCATION ON THE PROJECT IF SO ORDERED BY THE INSPECTOR.
10. THE CONTRACTOR WILL BE HELD RESPONSIBLE FOR THE PROPER FUNCTIONING OF LINES (WATER AND SEWER) FOR UP TO TWO (2) YEARS FROM THE DATE OF PROBATIONARY ACCEPTANCE OF THE LINES BY THE DISTRICT. ANY MALFUNCTION DURING THIS PERIOD OF GUARANTEE SHALL BE REMEDIED BY THE CONTRACTOR TO THE SATISFACTION OF THE DISTRICT ENGINEER AT NO EXPENSE TO THE DISTRICT.
11. SURFACE GRADES ARE TO BE WITHIN PLUS OR MINUS ONE FOOT OF FINISHED GRADE AND VERIFICATION OF COMPACTION RESULTS OBTAINED PRIOR TO THE INSTALLATION OF WATER AND SEWER LINES. RESULTS MUST BE SUBMITTED TO THE DISTRICT ENGINEER.
12. NO WORK SHALL BE BACKFILLED UNTIL THE CONSTRUCTION HAS BEEN INSPECTED AND APPROVED FOR BACKFILLING BY THE DISTRICT ENGINEER OR REPRESENTATIVE OF THE DISTRICT ENGINEER.
13. ALL SERVICES WILL BE PERMANENTLY MARKED ON CURB FACE AS FOLLOWS: "X" FOR SANITARY SERVICE SEWERS "V" FOR WATER SERVICES
14. NO TREES SHALL BE ALLOWED IN EASEMENTS OR WITHIN 8' OF ANY WATER OR SANITARY SEWER MAINS IN RIGHT OF WAY.
15. THE CONTRACTOR SHALL HAVE IN HIS POSSESSION AT ALL TIMES ONE (1) SIGNED COPY OF THE PLANS WHICH HAVE BEEN APPROVED BY THE PARKER WATER AND SANITATION DISTRICT AND THE DISTRICT ENGINEER AND ONE (1) COPY OF THE LATEST PARKER WATER AND SANITATION DISTRICT SPECIFICATION MANUAL.

WATER MAIN NOTES:

1. ALL MATERIALS AND WORKMANSHIP SHALL BE IN CONFORMANCE WITH THE PARKER WATER AND SANITATION DISTRICT ENGINEERING STANDARDS AND SPECIFICATIONS, LATEST REVISIONS. ALL WORK SHALL BE INSPECTED AND APPROVED BY PERSONNEL OF THE PARKER WATER SANITATION DISTRICT AND THE DISTRICT ENGINEER.
2. ALL WATER MAINS SHALL BE PER PWSO MATERIALS SPECIFICATIONS.
3. ALL BENDS, PLUGS, REDUCERS, AND FIRE HYDRANTS TO BE RODDED OR MEGA-LUGGED. ALL FITTINGS SHALL BE WRAPPED WITH 8-MIL MINIMUM THICKNESS POLYETHYLENE MATERIAL PER PWSO MATERIALS SPECIFICATIONS.
4. THERE SHALL BE A MINIMUM COVER OF 4.5 FEET OVER ALL WATER MAINS.
5. FIRE HYDRANTS SHALL CONFORM TO AWWA C-502 "DRY BARREL FIRE HYDRANTS" PIPE HYDRANT ASSEMBLIES SHALL INCLUDE ALL PIPE, FITTINGS, VALVES, MATERIALS, AND LABOR WHICH ARE NECESSARY TO INSTALL THE HYDRANT COMPLETE IN PLACE. SEE MATERIALS SPECIFICATIONS FOR APPROVED MODELS
6. ALL BENDS, TEES, FIRE HYDRANTS, BLOW-OFFS AND PLUGS AT DEAD END MAINS SHALL BE PROTECTED FROM THRUST BY USING CONCRETE THRUST BLOCKS.
7. PRECAUTIONS SHALL BE TAKEN TO PROTECT THE INTERIOR OF PIPES, FITTINGS, AND VALVES AGAINST CONTAMINATION. ALL OPENINGS IN THE PIPELINE SHALL BE CLOSED WITH WATERTIGHT PLUGS WHEN PIPE LAYING IS STOPPED AT THE CLOSE OF THE DAY'S WORK OR FOR OTHER REASONS, SUCH AS REST BREAKS OR MEAL PERIODS. THE MORE CLOSELY THE RATE OF DELIVERY IS CORRELATED TO THE RATE OF PIPE LAYING, THE LOWER THE RISK OF CONTAMINATION.
8. CHLORINATION AND FLUSHING: ALL WATER MAINS SHALL BE INSTALLED AND CHLORINATED PER PARKER WATER AND SANITATION STANDARDS AND SPECIFICATIONS. THE LINES SHALL BE CHLORINATED IN ACCORDANCE WITH ANSI/AWWA C-651-92., "DISINFECTING WATER MAINS." PARKER WATER AND SANITATION DISTRICT REQUIRES THE INITIAL DOSAGE RATE OF DISINFECTION BE AT LEAST 50 MG PER LITER. CHLORINE TABLETS SHOULD BE ADHERED TO THE TOP OF THE PIPE SECTION WITH PERMATEX NO.1 (RED). THE CHLORINATION OF ANY FINISHED PIPELINE SHALL BE DONE PRIOR TO THE HYDROSTATIC TESTING.
9. HYDROSTATIC TESTING: ALL WATER MAINS SHALL BE TESTED PER THE REQUIREMENTS OF THE PARKER WATER AND SANITATION DISTRICT STANDARDS AND SPECIFICATIONS. ALL PIPE SHALL BE FIELD PRESSURE TESTED TO A MINIMUM OF 150 PSI. ALL TESTING SHALL BE DONE IN THE PRESENCE OF A PARKER WATER AND SANITATION DISTRICT INSPECTOR. LEAKAGE FOR EACH SECTION OF PIPE BETWEEN LINES VALVES SHALL NOT EXCEED THE LIMITS SET FORTH IN THE PARKER WATER AND SANITATION DISTRICT STANDARDS AND SPECIFICATIONS.
10. VALVES IN STREETS ARE TO BE LOCATED AT PROPERTY LINE EXTENSIONS EXCEPT FOR TAPPING TEES WHERE AN ADDITIONAL VALVES SHALL BE PLACED ON THE TAPPING TEE. OTHER VALVE LOCATIONS, SUCH AS WHERE CROSS PANS EXIST, ARE SHOWN ON THE PLANS.
11. WHEN NECESSARY TO LOWER OR RAISE WATER LINES AT STORM DRAINS AND OTHER UTILITY CROSSING, A MINIMUM CLEARANCE OF 1.50 FEET SHALL BE MAINTAINED BETWEEN OUTSIDE OF PIPES.
12. THE CONTRACTOR SHALL NOTIFY THE PARKER WATER AND SANITATION DISTRICT AND THE DISTRICT ENGINEER AT LEAST 48 HOURS PRIOR TO ANY CONSTRUCTION. IF WORK IS SUSPENDED FOR ANY PERIOD OF TIME AFTER INITIAL START-UP, THE CONTRACTOR MUST NOTIFY THE DISTRICT ENGINEER 48 HOURS PRIOR TO RE-START.
13. PIPE BEDDING SHALL BE A CLEAN, WELL-GRADED SAND OR SQUEEGEE SAND IN ACCORDANCE WITH PARKER WATER AND SANITATION DISTRICT STANDARDS AND SPECIFICATIONS, LATEST REVISION.
14. THE CONTRACTOR SHALL NOTIFY THE PUBLIC UTILITY COMPANIES AND DETERMINED THE LOCATION OF ALL EXISTING UNDERGROUND UTILITIES PRIOR TO PROCEEDING WITH THE EXCAVATION. ALL WORK PERFORMED IN THE AREA OF THE PUBLIC UTILITIES SHALL BE PERFORMED ACCORDING TO THE REQUIREMENTS OF THESE AGENCIES.
15. COMPACTION OF ALL TRENCHES MUST BE ATTAINED IN ACCORDANCE WITH THE SOILS REPORTS AND COMPACTION TEST RESULTS SUBMITTED TO THE DISTRICT ENGINEER PRIOR TO PROBATIONARY ACCEPTANCE.
16. VALVE BOXES: TYLER SCREW-TYPE 6 INCHES CAST IRON VALVE BOX ASSEMBLY SERIES 6860 WITH NO. 160 OVAL BASE. CLAY AND BAILEY SCREW-TYPE 6 INCH CAST IRON VALVE BOX ASSEMBLY NO. P-108 WITH NO. 106 LARGE OVAL BASE.
17. ALL PIPE LENGTHS ARE APPROXIMATE.
18. AT LEAST FIVE (5) DAYS PRIOR TO THE START OF CONSTRUCTION, A PRE-CONSTRUCTION MEETING WILL BE HELD AT THE OFFICE OF THE DISTRICT ENGINEER AND ATTENDED BY THE CONTRACTOR AND REPRESENTATIVE OF OTHER APPROVING AGENCIES. IT WILL BE THE RESPONSIBILITY OF THE CONTRACTOR TO CONTACT THE DISTRICT ENGINEER.

SANITARY SEWER NOTES:

1. ALL SANITARY SEWER CONSTRUCTION SHALL CONFORM TO THE PARKER WATER AND SANITATION DISTRICT SPECIFICATION.
2. ALL SEWER MAINS SHALL BE PVC, ASTM D-3034, SDR 35 OR APPROVED EQUAL. ALL SEWER MAIN SIZE IS 8" IN DIAMETER UNLESS OTHERWISE NOTED.
3. SEWER LINES SHALL BE INSTALLED 5.0 FEET SOUTH OR WEST OF STREET CENTERLINE, UNLESS OTHERWISE SHOWN ON PLANS. SEWER LINES SHALL BE 10.00 FEET FROM WATER LINES EXCEPT WHEN CROSSING EACH OTHER. SEWER LINES WHICH CROSS LESS THAN 1.50 FEET VERTICALLY FROM THE WATER MAIN SHALL BE ENCASED IN CONCRETE AS PER PARKER WATER AND SANITATION DISTRICT STANDARD AND SPECIFICATIONS. USE RUBBER GASKETS FOR PVC ENCASEMENT.
4. SEWER RIM ELEVATIONS SHOWN ARE APPROPRIATE ONLY AND ARE NOT TO BE TAKEN AS FINAL ELEVATIONS. RING AND COVER SHALL BE SET IN CENTERED CONCRETE RINGS WITH RAM-NECK FOR ADJUSTMENT TO MATCH FINAL PAVEMENT ELEVATIONS.
5. THE CONTRACTOR AND SURVEY CREW SHALL VERIFY ELEVATIONS OF EXISTING SEWER LINES AND MANHOLES TO BE TIED TO PRIOR TO CONSTRUCTION OR STAKING OF SANITARY SEWER.
6. NO UNDERDRAIN SYSTEM WILL BE ALLOWED TO BE PLACED IN MAINLINE OR SEWER SERVICE TRENCHES.
7. SEWER SERVICE TEES FOR EACH UNIT SHALL BE STAKED BY A SURVEY CREW AND FURNISHED AND INSTALLED BY THE CONTRACTOR. THE CONTRACTOR SHALL FURNISH TO THE ENGINEER "AS CONSTRUCTED" LOCATION OF TEES. SEWER WYES SHALL BE USED RATHER THAN TEES.
8. ALL MANHOLES SHALL BE 48-INCHES IN DIAMETER WITH 24-INCH RING AND COVER, ECCENTRIC CONE UNLESS OTHERWISE SPECIFIED.
9. PIPE BEDDING SHALL BE CLASS "B" AND SHALL CONFORM TO ASTM C-33 OR D-448 GRADATION NO. 6 OR NO. 67.
10. AT LEAST FIVE (5) DAYS PRIOR TO THE START OF CONSTRUCTION, A PRE-CONSTRUCTION MEETING WILL BE HELD AT THE OFFICE OF THE DISTRICT ENGINEER AND ATTENDED BY THE CONTRACTOR AND REPRESENTATIVES OF THE OTHER APPROVING AGENCIES. IT WILL BE THE RESPONSIBILITY OF THE CONTRACTOR TO CONTACT THE DISTRICT ENGINEER TO SCHEDULE THIS MEETING.
11. ALL PIPE LENGTHS ARE APPROXIMATE.
12. THE CONTRACTOR SHALL HAVE IN HIS POSSESSION AT ALL TIMES ONE (1) SIGNED COPY OF THE PLANS WHICH HAVE BEEN APPROVED BY THE PARKER WATER AND SANITATION DISTRICT AND THE DISTRICT ENGINEER AND ONE (1) COPY OF THE LATEST PARKER WATER AND SANITATION DISTRICT SPECIFICATION MANUAL.
13. ALL MANHOLES SHALL HAVE SHAPED INVERTS.
14. ALL SEWER LINES SHALL BE TESTED IN ACCORDANCE WITH THE PARKER WATER AND SANITATION DISTRICT STANDARDS AND SPECIFICATIONS PRIOR TO ACCEPTANCE OR ANY CONNECTION TO AN EXISTING SEWER LINE.
15. PRIOR TO START WORK WHERE SEWER MAIN TO BE INSTALLED INTO EXISTING DISTRICT SEWER SYSTEMS. THE NEAREST MANHOLE TO THE POINT OF TIE-IN SHALL BE PLUGGED WITH A PLUMBER'S PLUG ON THE INLET SIDE BY THE CONTRACTOR. THIS PLUG SHALL REMAIN IN PLACE UNTIL FINAL ACCEPTANCE BY THE DISTRICT. ITS PURPOSE SHALL BE TO PREVENT ANY MUD, WATER OR OTHER MATERIALS FROM ENTERING THE LINE DURING CONSTRUCTION. THE CONTRACTOR SHALL BE RESPONSIBLE FOR PUMPING AND CLEANING THESE MANHOLES AND REMOVING THE PLUG WHEN SO INSTRUCTED BY THE DISTRICT.
16. PRIOR TO PROBATIONARY ACCEPTANCE WALK-THROUGH, THE CLIENT SHALL JET CLEAN THE ENTIRE SANITARY SEWER SYSTEM AND PUMP OUT AT THE PLUGGED MANHOLE.

DISTRICT ACCEPTANCE NOTES:


1. UPON COMPLETION OF SANITARY SEWER AND WATER CONSTRUCTION AND TESTING, THE DEVELOPER OR CONTRACTOR SHALL CONTACT THE DISTRICT FOR PROBATIONARY ACCEPTANCE INSPECTION. A PUNCHLIST WILL BE PROVIDED THE DEVELOPER AND CONTRACTOR UPON COMPLETION OF THE INITIAL WALK-THRU AND PROBATIONARY ACCEPTANCE WILL BE ISSUED FOLLOWING COMPLETION AND ACCEPTANCE OF THE WORK OUTLINED IN THE PUNCHLIST.
2. THE CONTRACTOR WILL BE HELD RESPONSIBLE FOR THE PROPER FUNCTIONING OF THE LINES FOR UP TO TWO (2) YEARS FROM THE DATE OF PROBATIONARY ACCEPTANCE OF THE LINES BY THE DISTRICT. ANY MALFUNCTION DURING THIS PERIOD OF GUARANTEE SHALL BE REMEDIED BY THE CONTRACTOR TO THE SATISFACTION OF THE DISTRICT ENGINEER AT NO EXPENSE TO THE DISTRICT.
3. THE DATE OF FINAL ACCEPTANCE WILL BE INDICATED IN THE CONDITIONS OF THE PROBATIONARY ACCEPTANCE LETTER. THE DEVELOPER SHALL BE RESPONSIBLE FOR CONTACTING THE DISTRICT FOR FINAL INSPECTION AND FINAL ACCEPTANCE.

BENCHMARK
DOUGLAS COUNTY CONTROL POINT KNOWN AS 1.060032, BEING A 3-1/4" ALUMINUM CAP, BEING LOCATED IN THE SOUTHWEST QUARTER OF SECTION 33, TOWNSHIP 6 SOUTH, RANGE 66 WEST OF THE SIXTH PRINCIPAL MERIDIAN, HAVING A PUBLISHED ELEVATION OF 1799.2870 METERS (5903.13 FEET) NAVD '88 DATUM.

BASIS OF BEARINGS:
THE EAST LINE OF THE NORTHEAST QUARTER OF SAID SECTION 9 BEING MONUMENTED AT THE NORTHEAST CORNER OF SAID SECTION 9 BY A 3-1/4" ALUMINUM CAP STAMPED LS 23053 AND AT THE EAST QUARTER CORNER OF SAID SECTION 9 BY A 2-1/2" ALUMINUM CAP STAMPED LS 6935 BEING CONSIDERED TO BEAR SOUTH 00°15'06" EAST, 2648.70 FEET.

PREPARED UNDER THE SUPERVISION OF

BRIAN P. WILSON
COLORADO P.E. 0050067

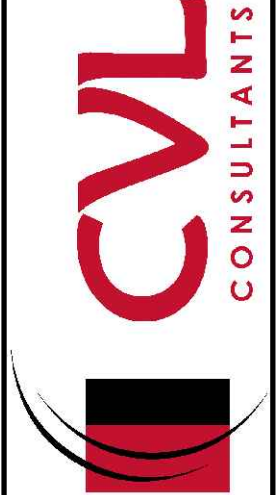SHEET NUMBER	DRAWN BY: KJD	CHECKED BY: JJJ	DATE: MAY 2017	SCALE: AS SHOWN	FILE NO: 8130283701	TRAILS AT CROWFOOT FILING 9 CONSTRUCTION DRAWINGS PARKER WATER AND SANITATION NOTES	HR 935 LLC 7353 South Alton Way CENTENNIAL, CO 80112	 10339 E. Dry Creek Rd. Denver, CO 80110 Tel: (720) 482-9526 Fax: (720) 482-9546	No.	Revisions	Date	Init.	Appr.	Date

SHEET NUMBER 3	DRAWN BY:	JLR	SCALE:			TRAILS AT CROWFOOT FILING 9 CONSTRUCTION DRAWINGS AREA UTILITY PLAN	 HR 935 LLC 7353 South Alton Way CENTENNIAL, CO 80112		10333 E. Dry Creek Rd. Suite 240 Englewood, CO 80112 Tel: (720) 482-9526 Fax: (720) 482-9546				
	CHECKED BY:	JJJ	FILE NO:										
	DATE:	MAY 2017			No.					Revisions			
			Date	Init.	Appr.								

N:\PROJECTS\SSHS RANCH\CD\ENGINEERING\SSHS SET\CD\9\DWG\PARKER WATER AND SANITATION\AREA UTILITY PLAN\DWG. BIRAWK. 2/26/2018 6:11 PM



CALL 811
TWO WORKING DAYS
BEFORE YOU DIG
UNCC 1-800-922-1987

THE TOWN OF PARKER REVIEW CONSTITUTES GENERAL COMPLIANCE WITH THE TOWN'S STANDARDS AND APPROVED VARIANCES, SUBJECT TO THESE PLANS BEING STAMPED, SIGN, AND DATED BY THE PROFESSIONAL ENGINEER OF RECORD. REVIEW BY THE TOWN DOES NOT CONSTITUTE APPROVAL OF THE PLAN DESIGN OR ACCURACY AND CORRECTNESS OF ENGINEERING CALCULATIONS. ERRORS IN THE DESIGN OR CALCULATIONS REMAIN THE RESPONSIBILITY OF THE REGISTERED PROFESSIONAL ENGINEER WHOSE STAMP AND SIGNATURE ARE AFFIXED TO THIS DOCUMENT.

THIS REVIEW DOES NOT CONSTITUTE APPROVAL OF ANY PRIVATE ON-SITE IMPROVEMENTS WHICH MAY BE SHOWN. CONSTRUCTION CANNOT COMMENCE UNTIL ALL REQUIRED DRAINAGE/TRAFFIC REPORT(S), FINAL DEVELOPMENT PLAN(S), SPECIAL REVIEW(S), GRADING PERMIT, AND/OR OTHER PERMITS ARE COMPLETE, APPROVED AND ON FILE WITH THE TOWN OF PARKER.

FIRE DEPARTMENT APPROVAL


ALL FIRE HYDRANTS SHALL BE INSTALLED ACCORDING TO WATER UTILITY STANDARDS. THE NUMBER AND LOCATIONS OF THE FIRE HYDRANTS AS SHOWN ON THE OVERALL UTILITY PLAN ARE CORRECT AS SPECIFIED BY THE TOWN OF PARKER, COMMUNITY DEVELOPMENT DEPARTMENT.

(FIRE CODE OFFICIAL OR DESIGNATED REPRESENTATIVE)

DATE

(NOTE: UNDERGROUND FIRE LINE (UFL) SUBMITTAL DOCUMENTS MUST MEET THE REQUIREMENTS OF NFPA24 WHEN SUBMITTING FOR REVIEW.)

MATCHLINE - SHEET 3

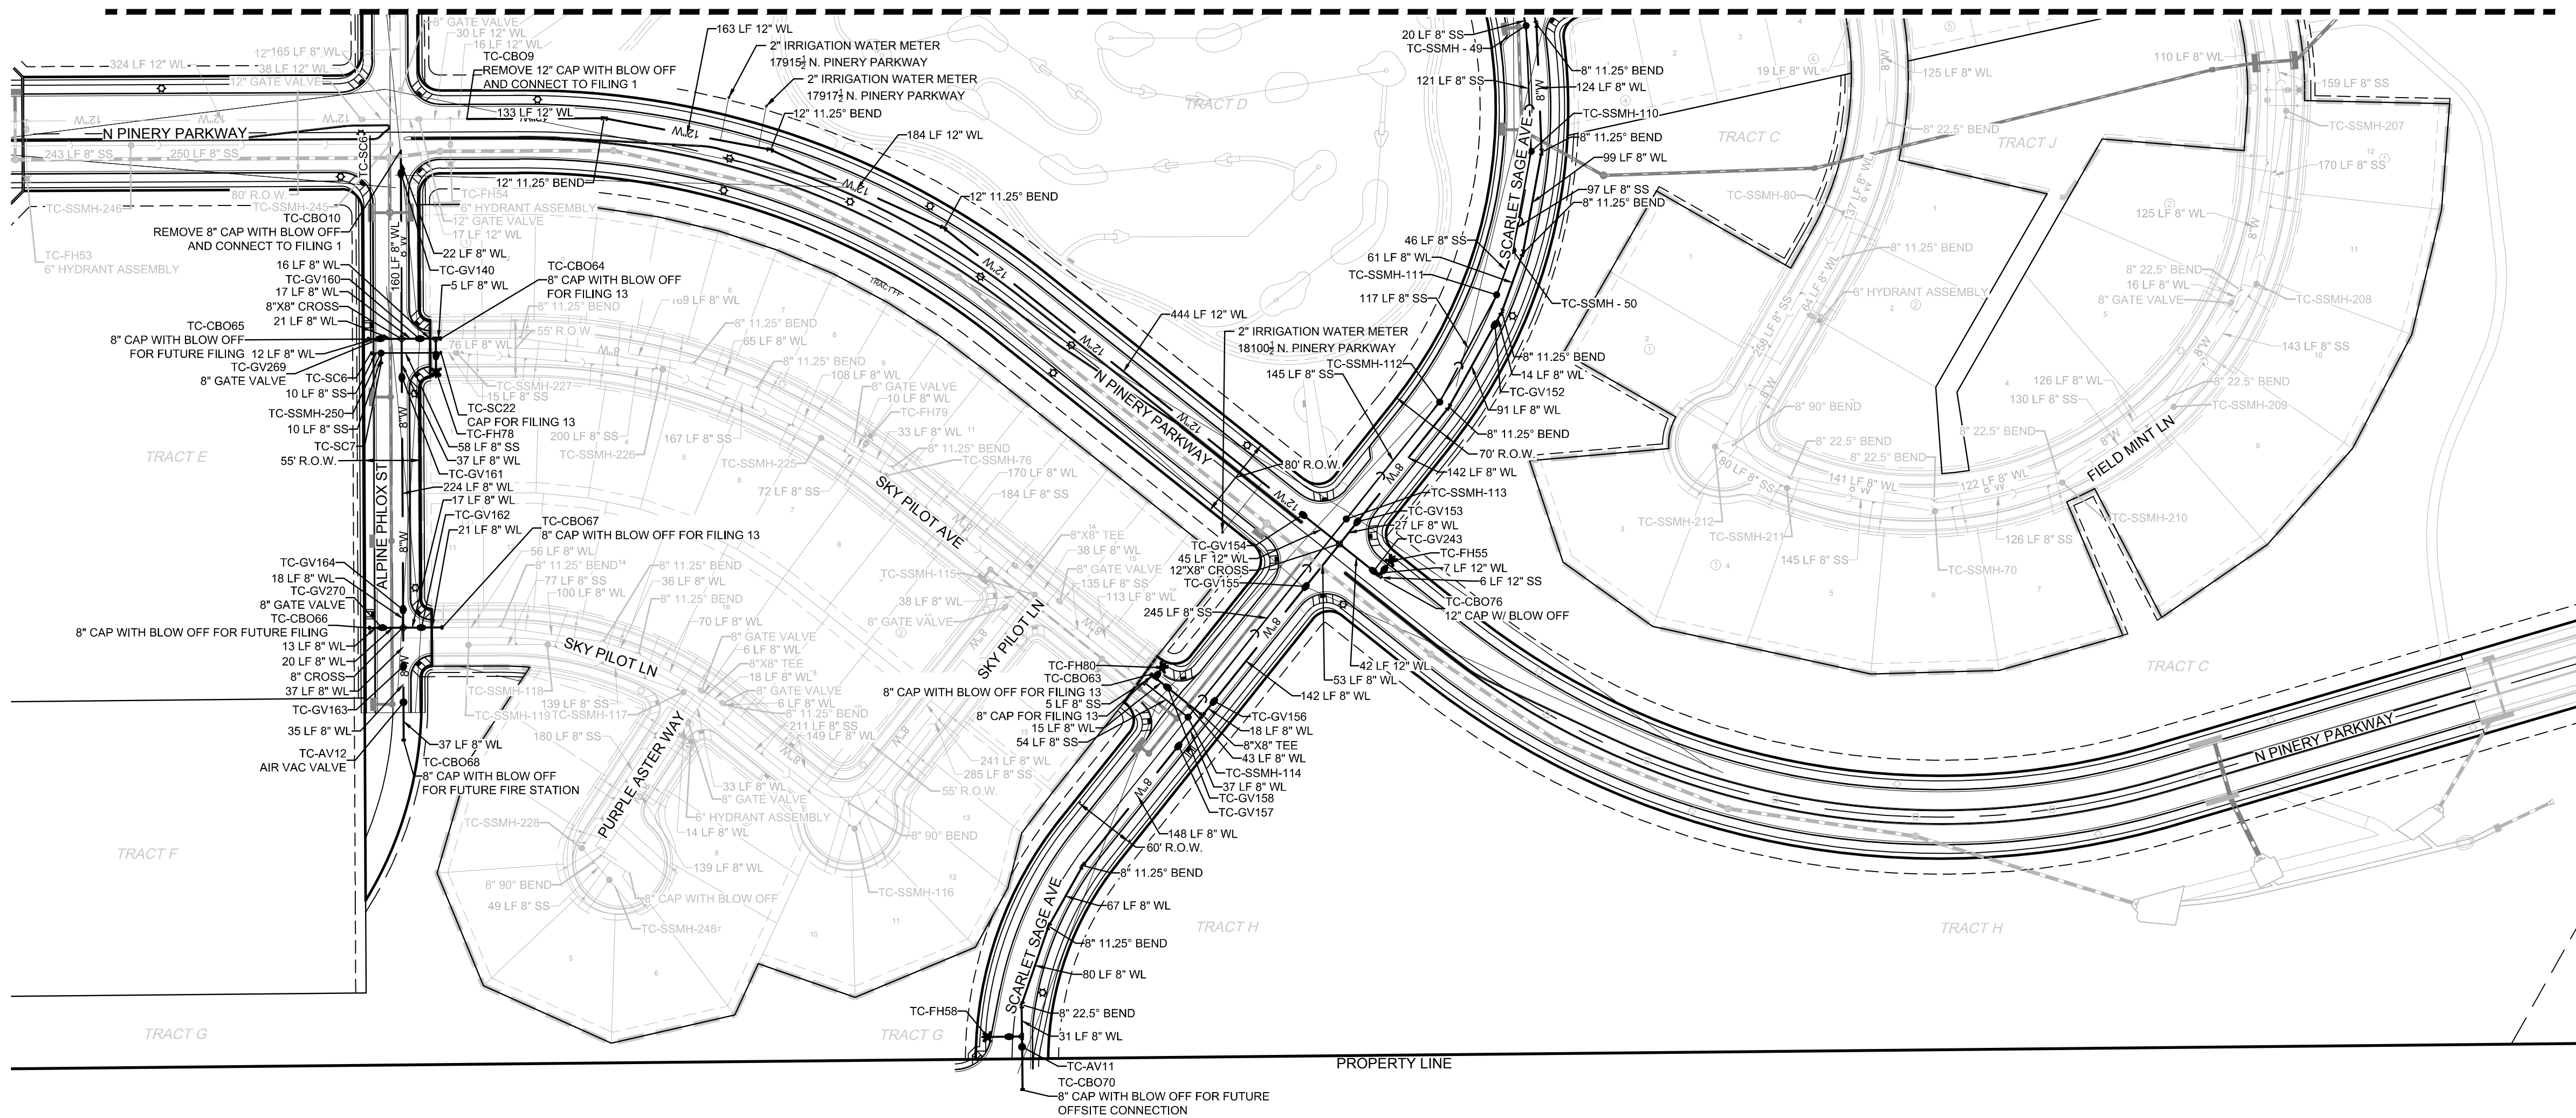

SCALE: 1" = 100'

PREPARED UNDER THE SUPERVISION OF


BRIAN P. WILSON
COLORADO P.E. 0050067

BASIS OF BEARINGS:

THE EAST LINE OF THE NORTHEAST QUARTER OF SAID SECTION 9 BEING MONUMENTED AT THE NORTHEAST CORNER OF SAID SECTION 9 BY A 3-1/4" ALUMINUM CAP STAMPED LS 23053 AND AT THE EAST QUARTER CORNER OF SAID SECTION 9 BY A 2-1/2" ALUMINUM CAP STAMPED LS 6935 BEING CONSIDERED TO BEAR SOUTH 00°15'06" EAST, 2648.70 FEET.

BENCHMARK

DOUGLAS COUNTY CONTROL POINT KNOWN AS 1.060032, BEING A 3-1/4" ALUMINUM CAP, BEING LOCATED IN THE SOUTHWEST QUARTER OF SECTION 33, TOWNSHIP 6 SOUTH, RANGE 66 WEST OF THE SIXTH PRINCIPAL MERIDIAN, HAVING A PUBLISHED ELEVATION OF 1799.2870 METERS (5903.13 FEET) NAVD '88 DATUM.

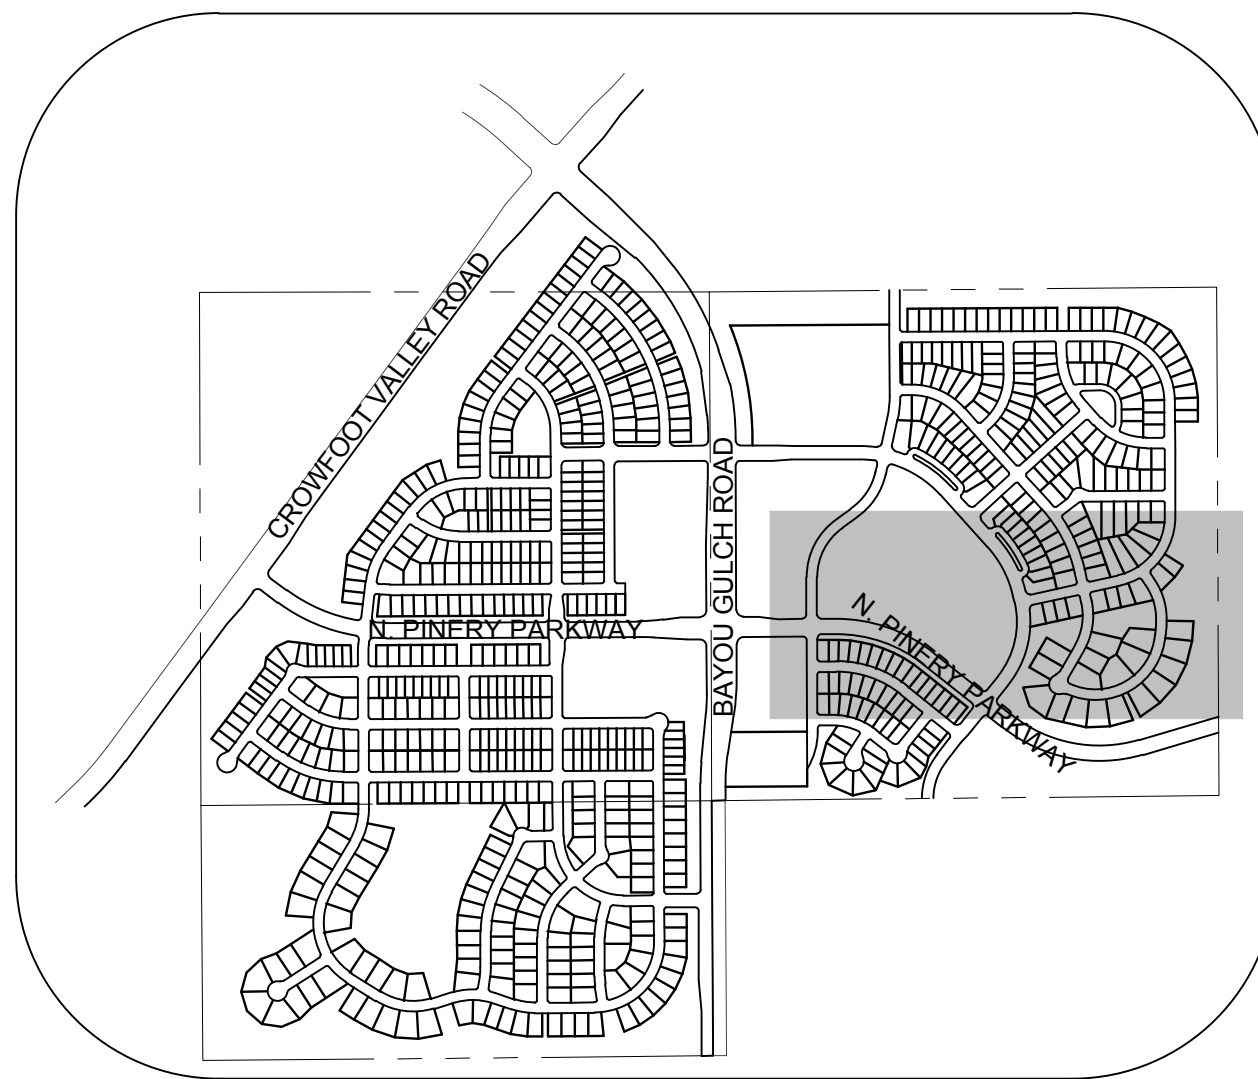

KEYMAP N.T.S. LEGEND

②	BLOCK NUMBER	△	PROPOSED RANGE POINT
Ⓐ	LOT TYPE	---	CENTERLINE
6	LOT NUMBER	---	RIGHT-OF-WAY
⊕	PROPOSED BUTTERFLY VALVE	---	PROPERTY LINE
⌈	PROPOSED CAP WITH END OF LINE BLOWOFF	---	EDGE OF PAVEMENT
⌋	PROPOSED REDUCER	→	PROPOSED DIRECTION OF FLOW
⊗	PROPOSED VALVE	1.0%	PROPOSED SLOPE & DIRECTION
⊙	PROPOSED FIRE HYDRANT	5615	EXISTING 5' CONTOUR
⊕	PROPOSED WL FITTING WITH THRUST BLOCK	5616	EXISTING 1' CONTOUR
⌋	PROPOSED FLARED END SECTION	5620	PROPOSED 5' CONTOUR
⊕	PROPOSED LOW POINT BLOW-OFF	5607	PROPOSED 1' CONTOUR
⊕	PROPOSED AIR VALVE	---	PROPOSED STORM DRAIN
⊕	FUTURE PHASE VALVE	---	PROPOSED SEWER LINE WITH MANHOLE
⊕	FUTURE FIRE HYDRANT	---	PROPOSED SEWER LATERAL
⊕	PROPOSED LIGHT POLE	---	PROPOSED WATER LINE
⊕	PROPOSED SIDEWALK	---	PROPOSED WATER LATERAL W/ METER
⊕	PROPOSED SIDEWALK RAMP	---	SECTION LINE
10.00	EXISTING ELEVATION	---	FILING BOUNDARY
10.00	PROPOSED DESIGN ELEVATION	FO	EXISTING FIBER OPTIC LINE
⊕	PROPOSED STORM DRAIN INLET	OH	EXISTING OVERHEAD POWER
⊕	PROPOSED STORM DRAIN MANHOLE	TEL	EXISTING TELEPHONE LINE

ABBREVIATIONS

AD	ANGLE DIFFERENCE	MH	MANHOLE
AV	AIR VAC RELEASE VALVE	N.T.S.	NOT TO SCALE
BVC	BEGIN VERTICAL CURVE	PVC	POLYVINYL CHLORIDE
BVP	BEGIN VERTICAL PROFILE	PVI	PT. OF VERTICAL INTERSECTION
CBO	CAP WITH BLOW OFF	PVT	POINT OF VERTICAL TANGENT
CRR	CURB RETURN RADIUS	RCBC	REINFORCED CONCRETE BOX CULVERT
EL	ELEVATION	RCP	REINFORCED CONCRETE PIPE
EP	EDGE OF PAVEMENT	ROW	RIGHT OF WAY
EVC	END VERTICAL CURVE	SC	SANITARY CAP
EVP	END VERTICAL PROFILE	SD	STORM DRAIN
FG	FINISHED GROUND	SL	SECTION LINE
FH	FIRE HYDRANT	SS	SANITARY SEWER
FL	FLOW LINE	STA	STATION
GV	GATE VALVE	T.O.P.	TOP OF PIPE
HCR	HANDICAP CURB RAMP	UE	UTILITY EASEMENT
HP	HIGH POINT	VC	VERTICAL CURVE
INV	INVERT	WL	WATER LINE
K	CURVATURE COEFFICIENT	WLC	WATER LINE CONNECTION
LF	LINEAR FEET	WSE	WATER SURFACE ELEVATION

THE DISTRICT INSPECTOR MUST BE NOTIFIED AT LEAST 48 HOURS PRIOR TO START OF CONSTRUCTION. CALL PARKER WATER AND SANITATION DISTRICT AT 303-841-4627. THE DISTRICT WILL PROVIDE PERIODIC INSPECTIONS OF THE WORK. 24 HOUR NOTICE TO THE INSPECTOR IS REQUIRED FOR SCHEDULE INSPECTIONS. ANY WORK ACCOMPLISHED WITHOUT THE APPROVAL OF THE INSPECTOR WILL BE SUBJECT TO REJECTION.


REVIEWED FOR CONFORMANCE TO PARKER WATER AND SANITATION DISTRICT STANDARDS.

BY: (DISTRICT REPRESENTATIVE) DATE

APPROVED FOR CONSTRUCTION:
PARKER WATER AND SANITATION DISTRICT

BY: (DISTRICT ENGINEER) DATE

10333 E. Dry Creek Rd.
Englewood, CO 80110
Tel: (720) 482-9526
Fax: (720) 482-9546

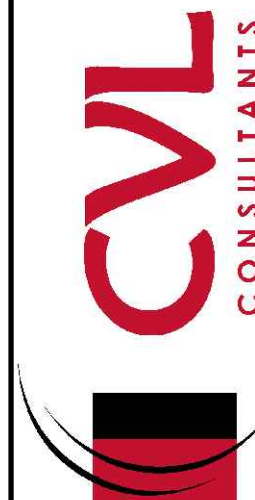


HR 935 LLC
7353 South Alton Way
CENTENNIAL, CO 80112

TRAILS AT CROWFOOT
FILING 9 CONSTRUCTION DRAWINGS
AREA UTILITY PLAN



SCALE: AS SHOWN
FILE NO: 8130283701

DRAWN BY: JLR
CHECKED BY: JJJ
DATE: MAY 2017

SHEET NUMBER
4

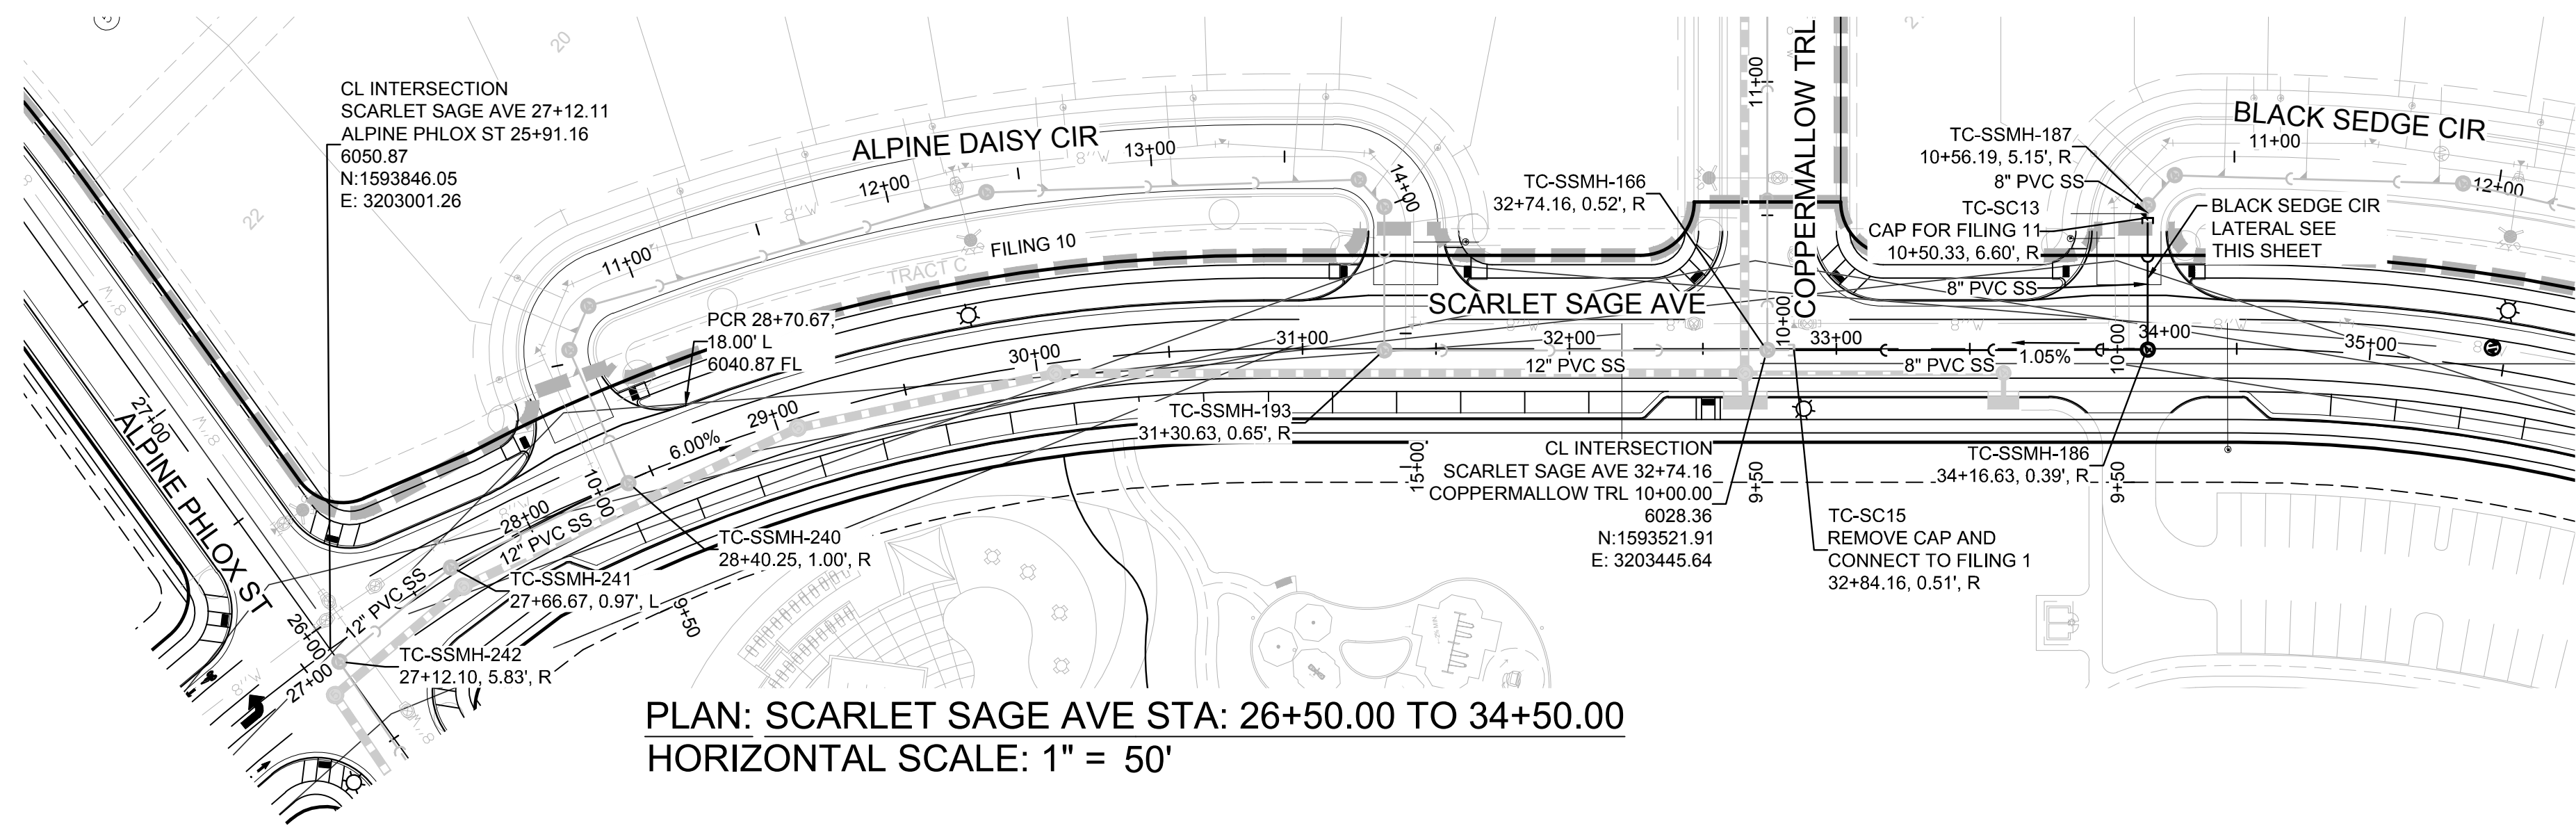

PLAN: SCARLET SAGE AVE STA: 26+50.00 TO 34+50.00
HORIZONTAL SCALE: 1" = 50'

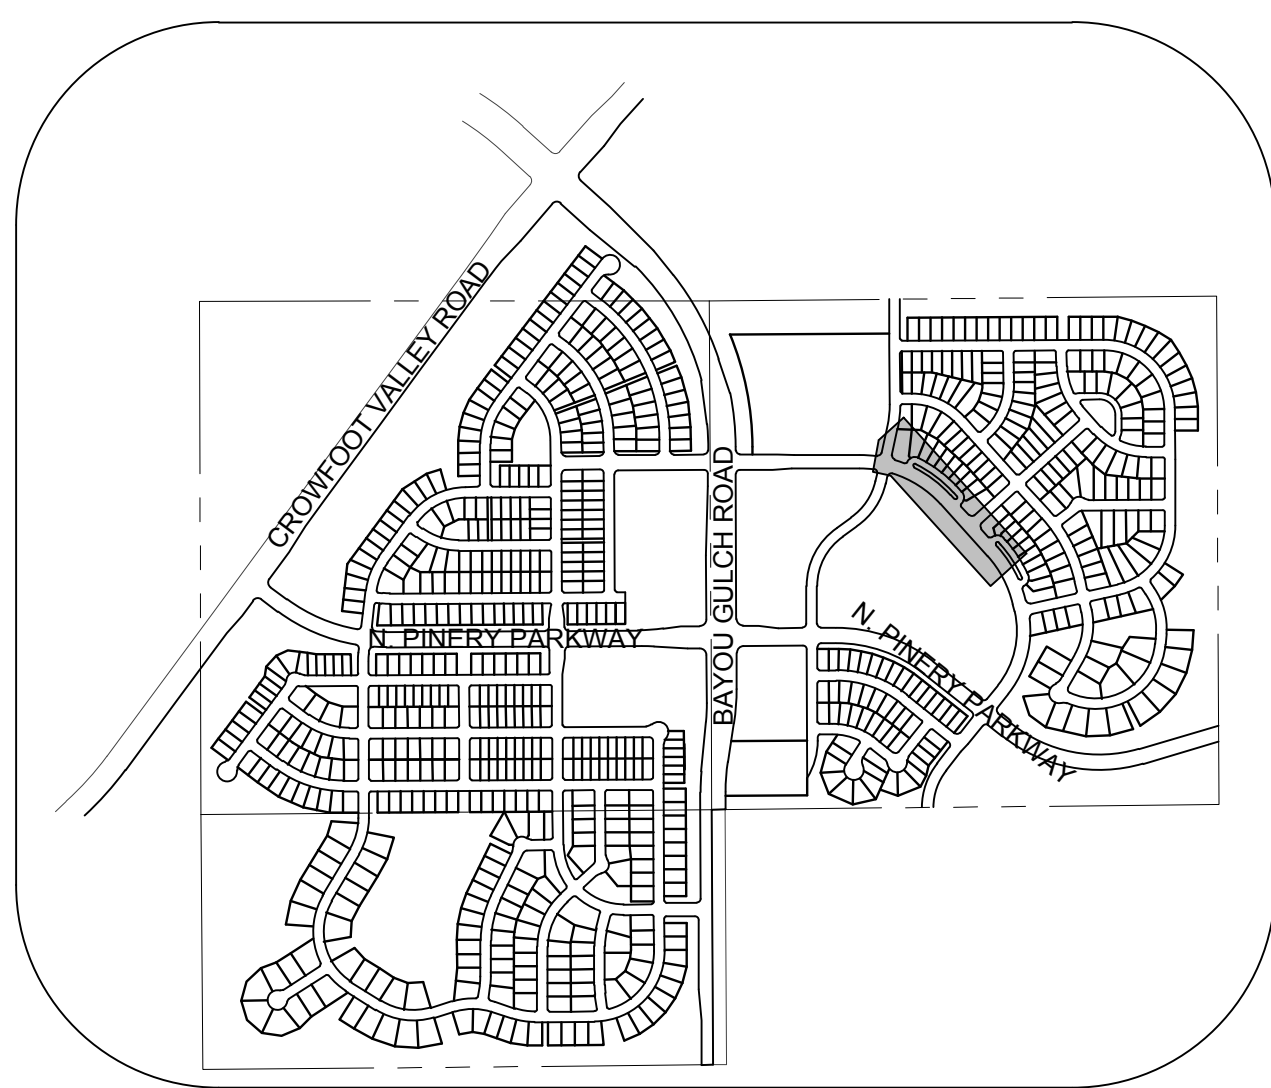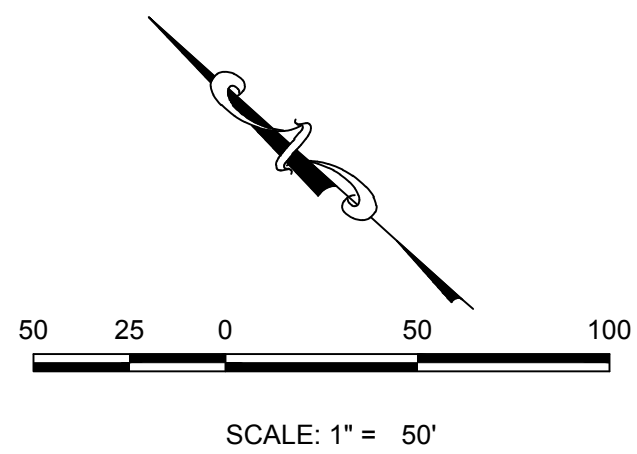


KEYMAP
N.T.S.
LEGEND


- | | | | |
|-------|---------------------------------------|------|----------------------------------|
| ② | BLOCK NUMBER | △ | PROPOSED RANGE POINT |
| Ⓐ | LOT TYPE | --- | CENTERLINE |
| 6 | LOT NUMBER | --- | RIGHT-OF-WAY |
| ⊗ | PROPOSED BUTTERFLY VALVE | --- | PROPERTY LINE |
| ⌋ | PROPOSED CAP WITH END OF LINE BLOWOFF | --- | EDGE OF PAVEMENT |
| ⌋ | PROPOSED REDUCER | → | PROPOSED DIRECTION OF FLOW |
| ⊗ | PROPOSED VALVE | 1.0% | PROPOSED SLOPE & DIRECTION |
| ⌋ | PROPOSED FIRE HYDRANT | --- | EXISTING 5' CONTOUR |
| ⌋ | PROPOSED WL FITTING WITH THRUST BLOCK | --- | EXISTING 1' CONTOUR |
| ⌋ | PROPOSED FLARED END SECTION | --- | PROPOSED 5' CONTOUR |
| ⊗ | PROPOSED LOW POINT BLOW-OFF | --- | PROPOSED 1' CONTOUR |
| ⊗ | PROPOSED AIR VALVE | --- | PROPOSED STORM DRAIN |
| ⊗ | FUTURE PHASE VALVE | --- | PROPOSED SEWER LINE WITH MANHOLE |
| ⊗ | FUTURE FIRE HYDRANT | --- | PROPOSED SEWER LATERAL |
| ⊗ | PROPOSED LIGHT POLE | --- | PROPOSED WATER LINE |
| ⊗ | PROPOSED SIDEWALK | --- | PROPOSED WATER LATERAL W/ METER |
| ⊗ | PROPOSED SIDEWALK RAMP | --- | SECTION LINE |
| 10.00 | EXISTING ELEVATION | --- | FILING BOUNDARY |
| 10.00 | PROPOSED DESIGN ELEVATION | --- | EXISTING FIBER OPTIC LINE |
| ⊗ | PROPOSED STORM DRAIN INLET | --- | EXISTING OVERHEAD POWER |
| ⊗ | PROPOSED STORM DRAIN MANHOLE | --- | EXISTING TELEPHONE LINE |

ABBREVIATIONS

- | | | | |
|-----|------------------------|--------|---------------------------------|
| AD | ANGLE DIFFERENCE | MH | MANHOLE |
| AV | AIR VAC RELEASE VALVE | N.T.S. | NOT TO SCALE |
| BVC | BEGIN VERTICAL CURVE | PVC | POLYVINYL CHLORIDE |
| BVP | BEGIN VERTICAL PROFILE | PVI | PT. OF VERTICAL INTERSECTION |
| CBO | CAP WITH BLOW OFF | PVT | POINT OF VERTICAL TANGENT |
| CRR | CURB RETURN RADIUS | RCBC | REINFORCED CONCRETE BOX CULVERT |
| EL | ELEVATION | RCP | REINFORCED CONCRETE PIPE |
| EP | EDGE OF PAVEMENT | ROW | RIGHT OF WAY |
| EVC | END VERTICAL CURVE | SC | SANITARY CAP |
| EVP | END VERTICAL PROFILE | SD | STORM DRAIN |
| FG | FINISHED GROUND | SL | SECTION LINE |
| FH | FIRE HYDRANT | SS | SANITARY SEWER |
| FL | FLOW LINE | STA | STATION |
| GV | GATE VALVE | T.O.P. | TOP OF PIPE |
| HCR | HANDICAP CURB RAMP | UE | UTILITY EASEMENT |
| HP | HIGH POINT | VC | VERTICAL CURVE |
| INV | INVERT | WL | WATER LINE |
| K | CURVATURE COEFFICIENT | WLC | WATER LINE CONNECTION |
| LF | LINEAR FEET | WSE | WATER SURFACE ELEVATION |

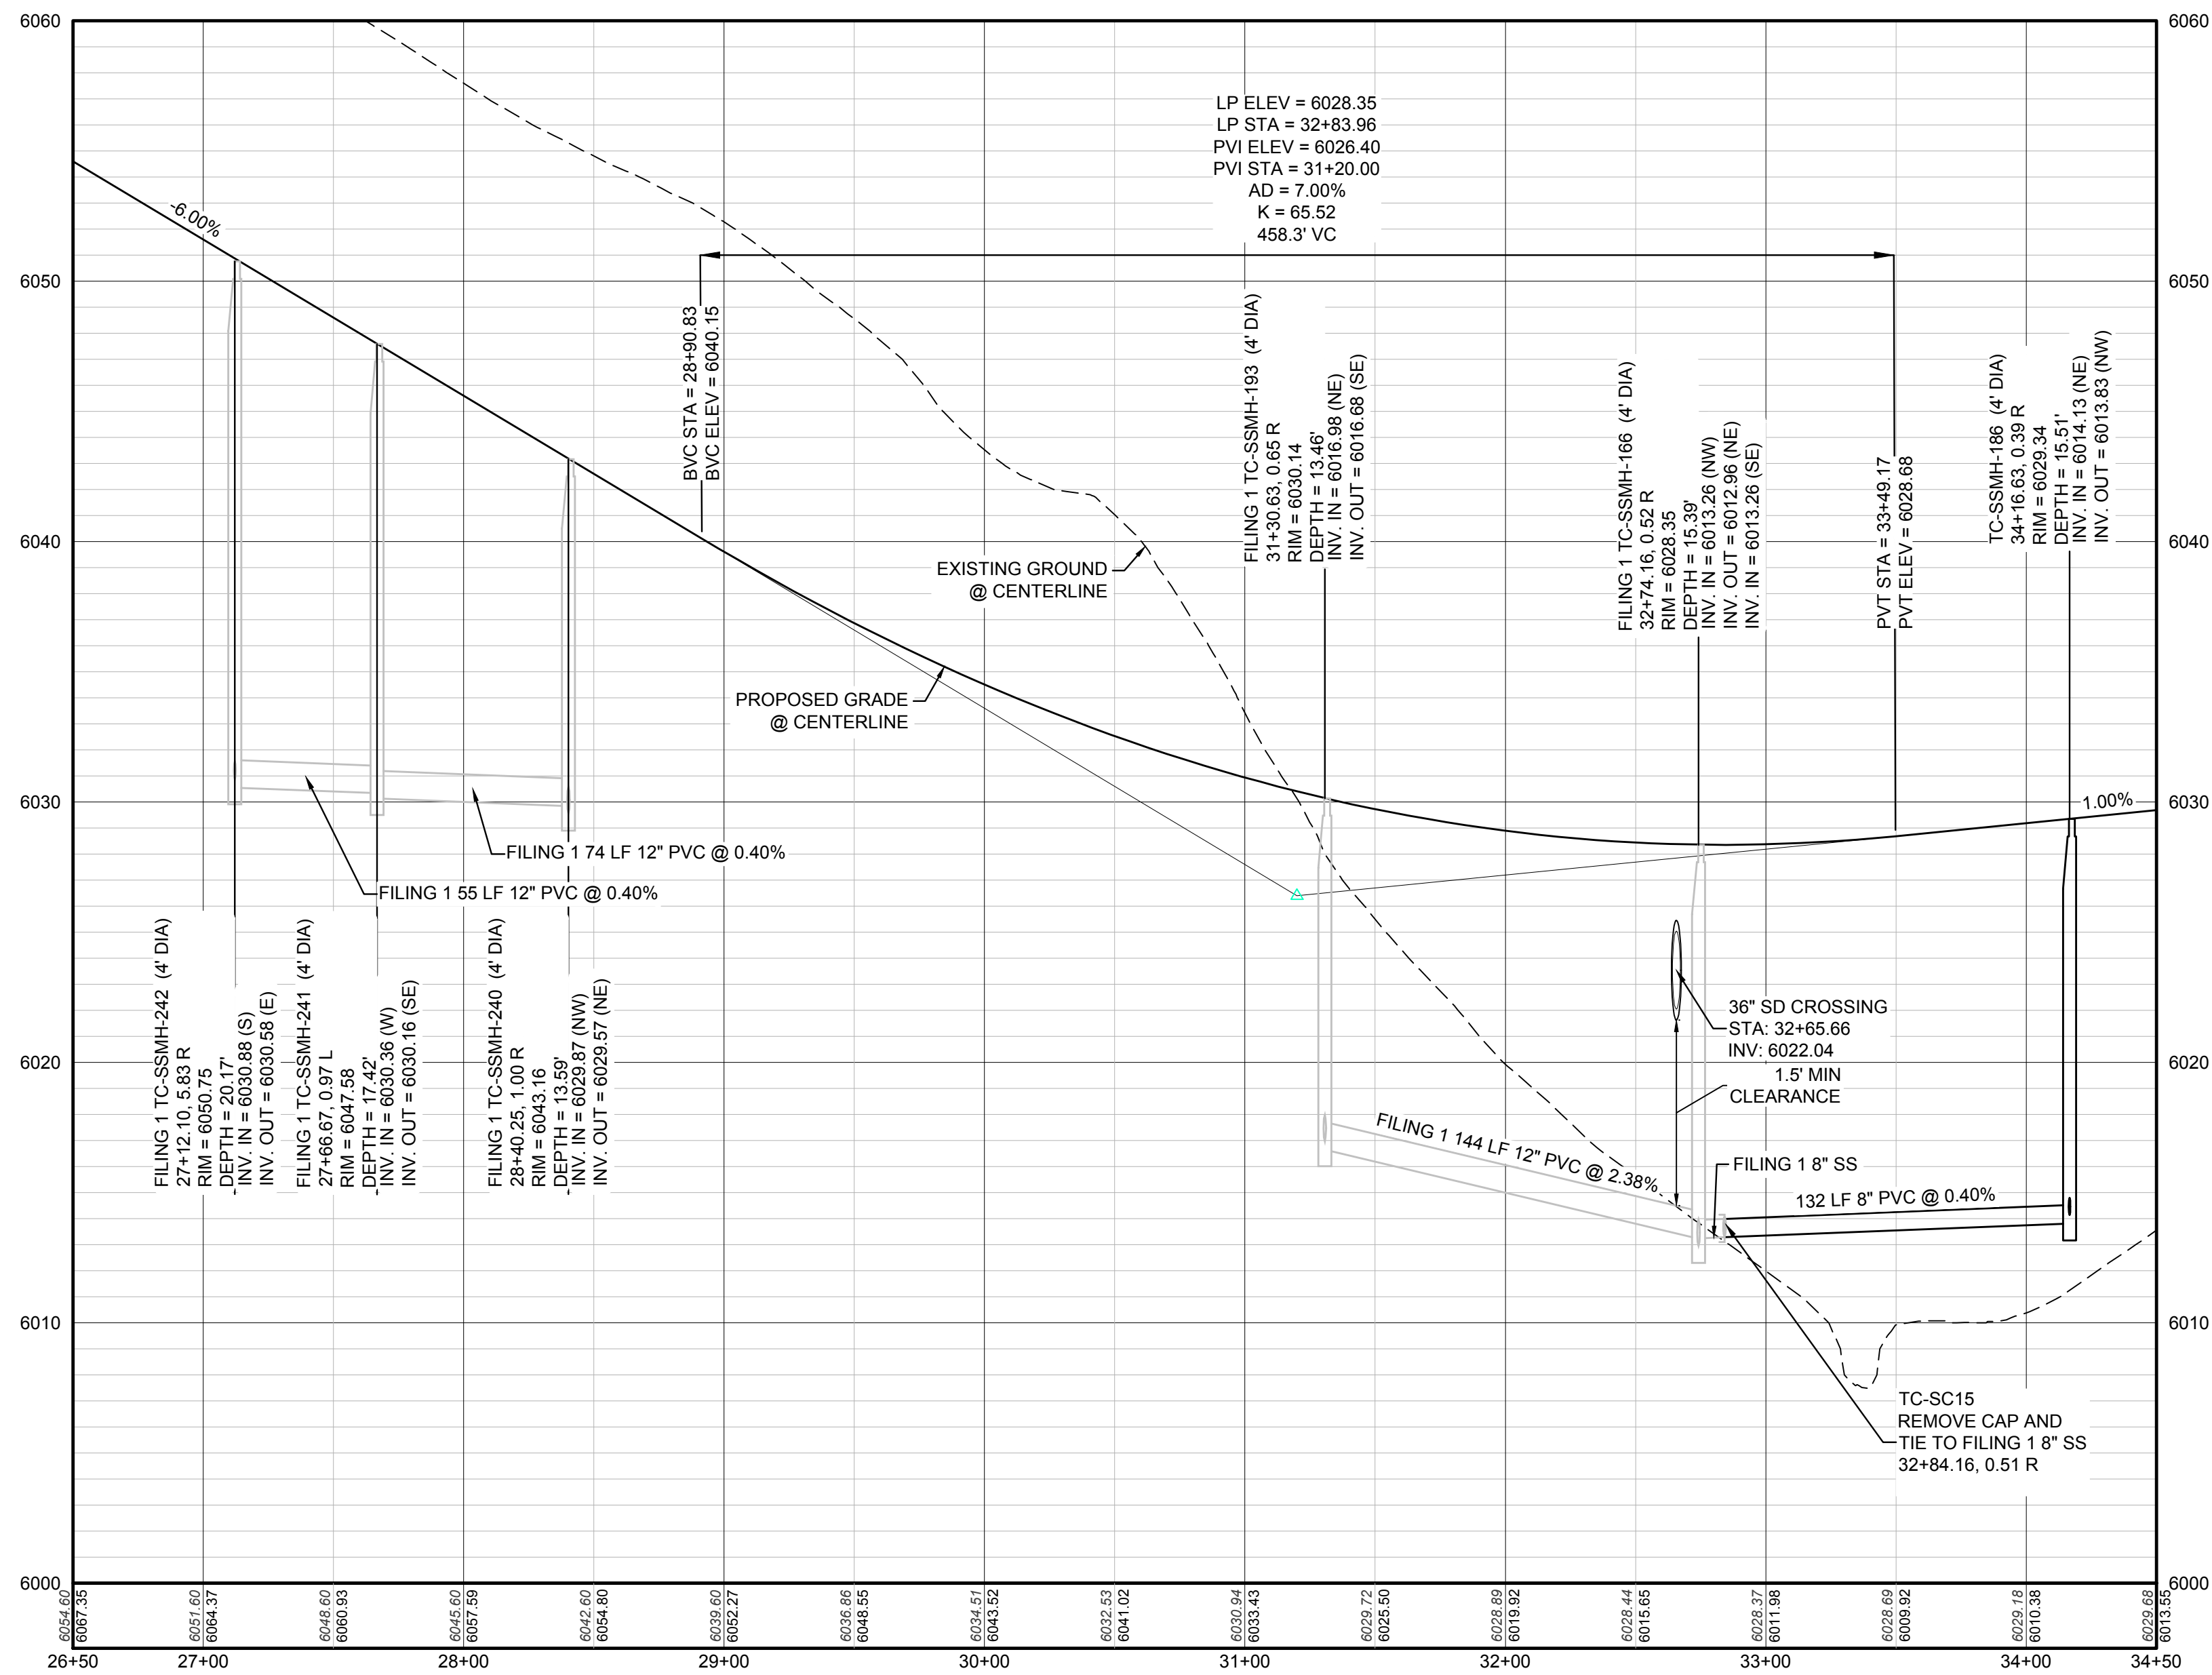

PROFILE: SCARLET SAGE AVE STA: 26+50.00 TO 34+50.00
HORIZONTAL: 1" = 50'
VERTICAL: 1" = 5'

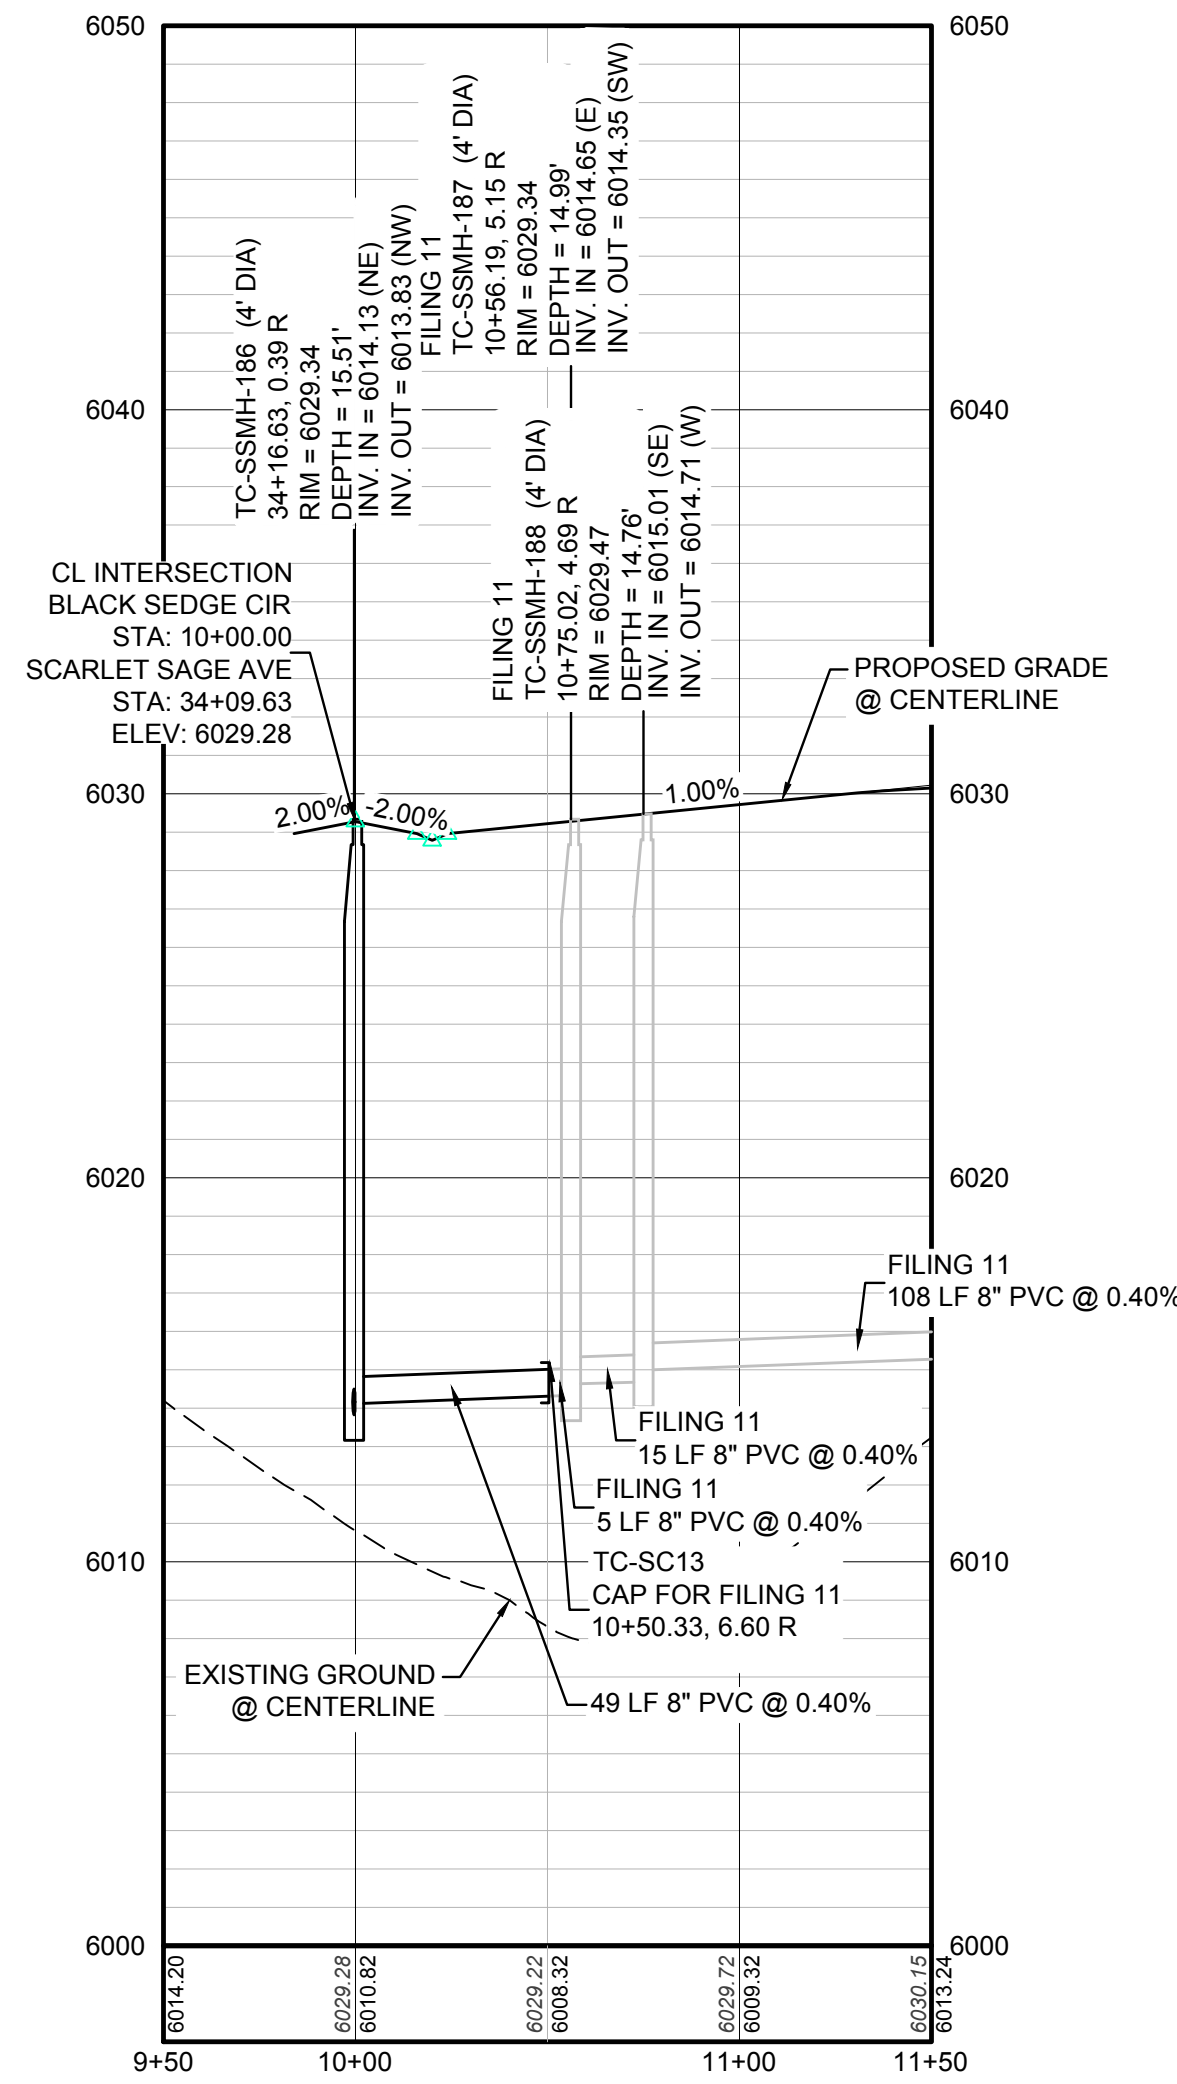

PROFILE: BLACK SEDGE CIR STA: 9+50.00 TO 11+50.00
HORIZONTAL: 1" = 50'
VERTICAL: 1" = 5'

PREPARED UNDER THE SUPERVISION OF

BRIAN P. WILSON
COLORADO P.E. 0050067

BENCHMARK
DOUGLAS COUNTY CONTROL POINT KNOWN AS 1.060032, BEING A 3-1/4" ALUMINUM CAP, BEING LOCATED IN THE SOUTHWEST QUARTER OF SECTION 33, TOWNSHIP 6 SOUTH, RANGE 66 WEST OF THE SIXTH PRINCIPAL MERIDIAN, HAVING A PUBLISHED ELEVATION OF 1799.2870 METERS (5903.13 FEET) NAVD '88 DATUM.

BASIS OF BEARINGS:
THE EAST LINE OF THE NORTHEAST QUARTER OF SAID SECTION 9 BEING MONUMENTED AT THE NORTHEAST CORNER OF SAID SECTION 9 BY A 3-1/4" ALUMINUM CAP STAMPED LS 23053 AND AT THE EAST QUARTER CORNER OF SAID SECTION 9 BY A 2-1/2" ALUMINUM CAP STAMPED LS 6935 BEING CONSIDERED TO BEAR SOUTH 00°15'06" EAST, 2648.70 FEET.

N:\PROJECTS\SSHS RANCH\CD\ENGINEERING\SSHS SET\CD\SSHP\PARKER WATER AND SANITATION\SANITARY PLAN AND PROFILE\9 SCARLET SAGE AVE SANITARY.DWG, BRIANW, 2/26/2019 6:16 PM


CALL 811
TWO WORKING DAYS
BEFORE YOU DIG
UNCC 1-800-922-1987
UTILITY NOTIFICATION
CENTER OF COLORADO

SHEET NUMBER	DRAWN BY: KJD	CHECKED BY: JJJ	DATE: MAY 2017	SCALE:	AS SHOWN	FILE NO: 8130283701	Revisions	No.	Date	Init.	Appr.	Date
				TRAILS AT CROWFOOT								
				FILING 9 CONSTRUCTION DRAWINGS								
				SANITARY SEWER PLAN AND PROFILE								
SCARLET SAGE AVE		HR 935 LLC		7353 South Alton Way CENTENNIAL, CO 80112		10333 E. Dry Creek Rd. Suite 110 Englewood, CO 80110 Tel: (720) 482-9526 Fax: (720) 482-9546		CVL CONSULTANTS				

N:\PROJECTS\SSHS BANCHADO\ENGINEERING\SSHS SETS\CD\SD\SP\PARKER WATER AND SANITATION\SANITARY PLAN AND PROFILE\9 SCARLET SAGE AVE SANITARY DWG, BRIANW, 2/26/2019 6:16 PM



CALL 811
TWO WORKING DAYS
BEFORE YOU DIG
UNCC 1-800-922-1987

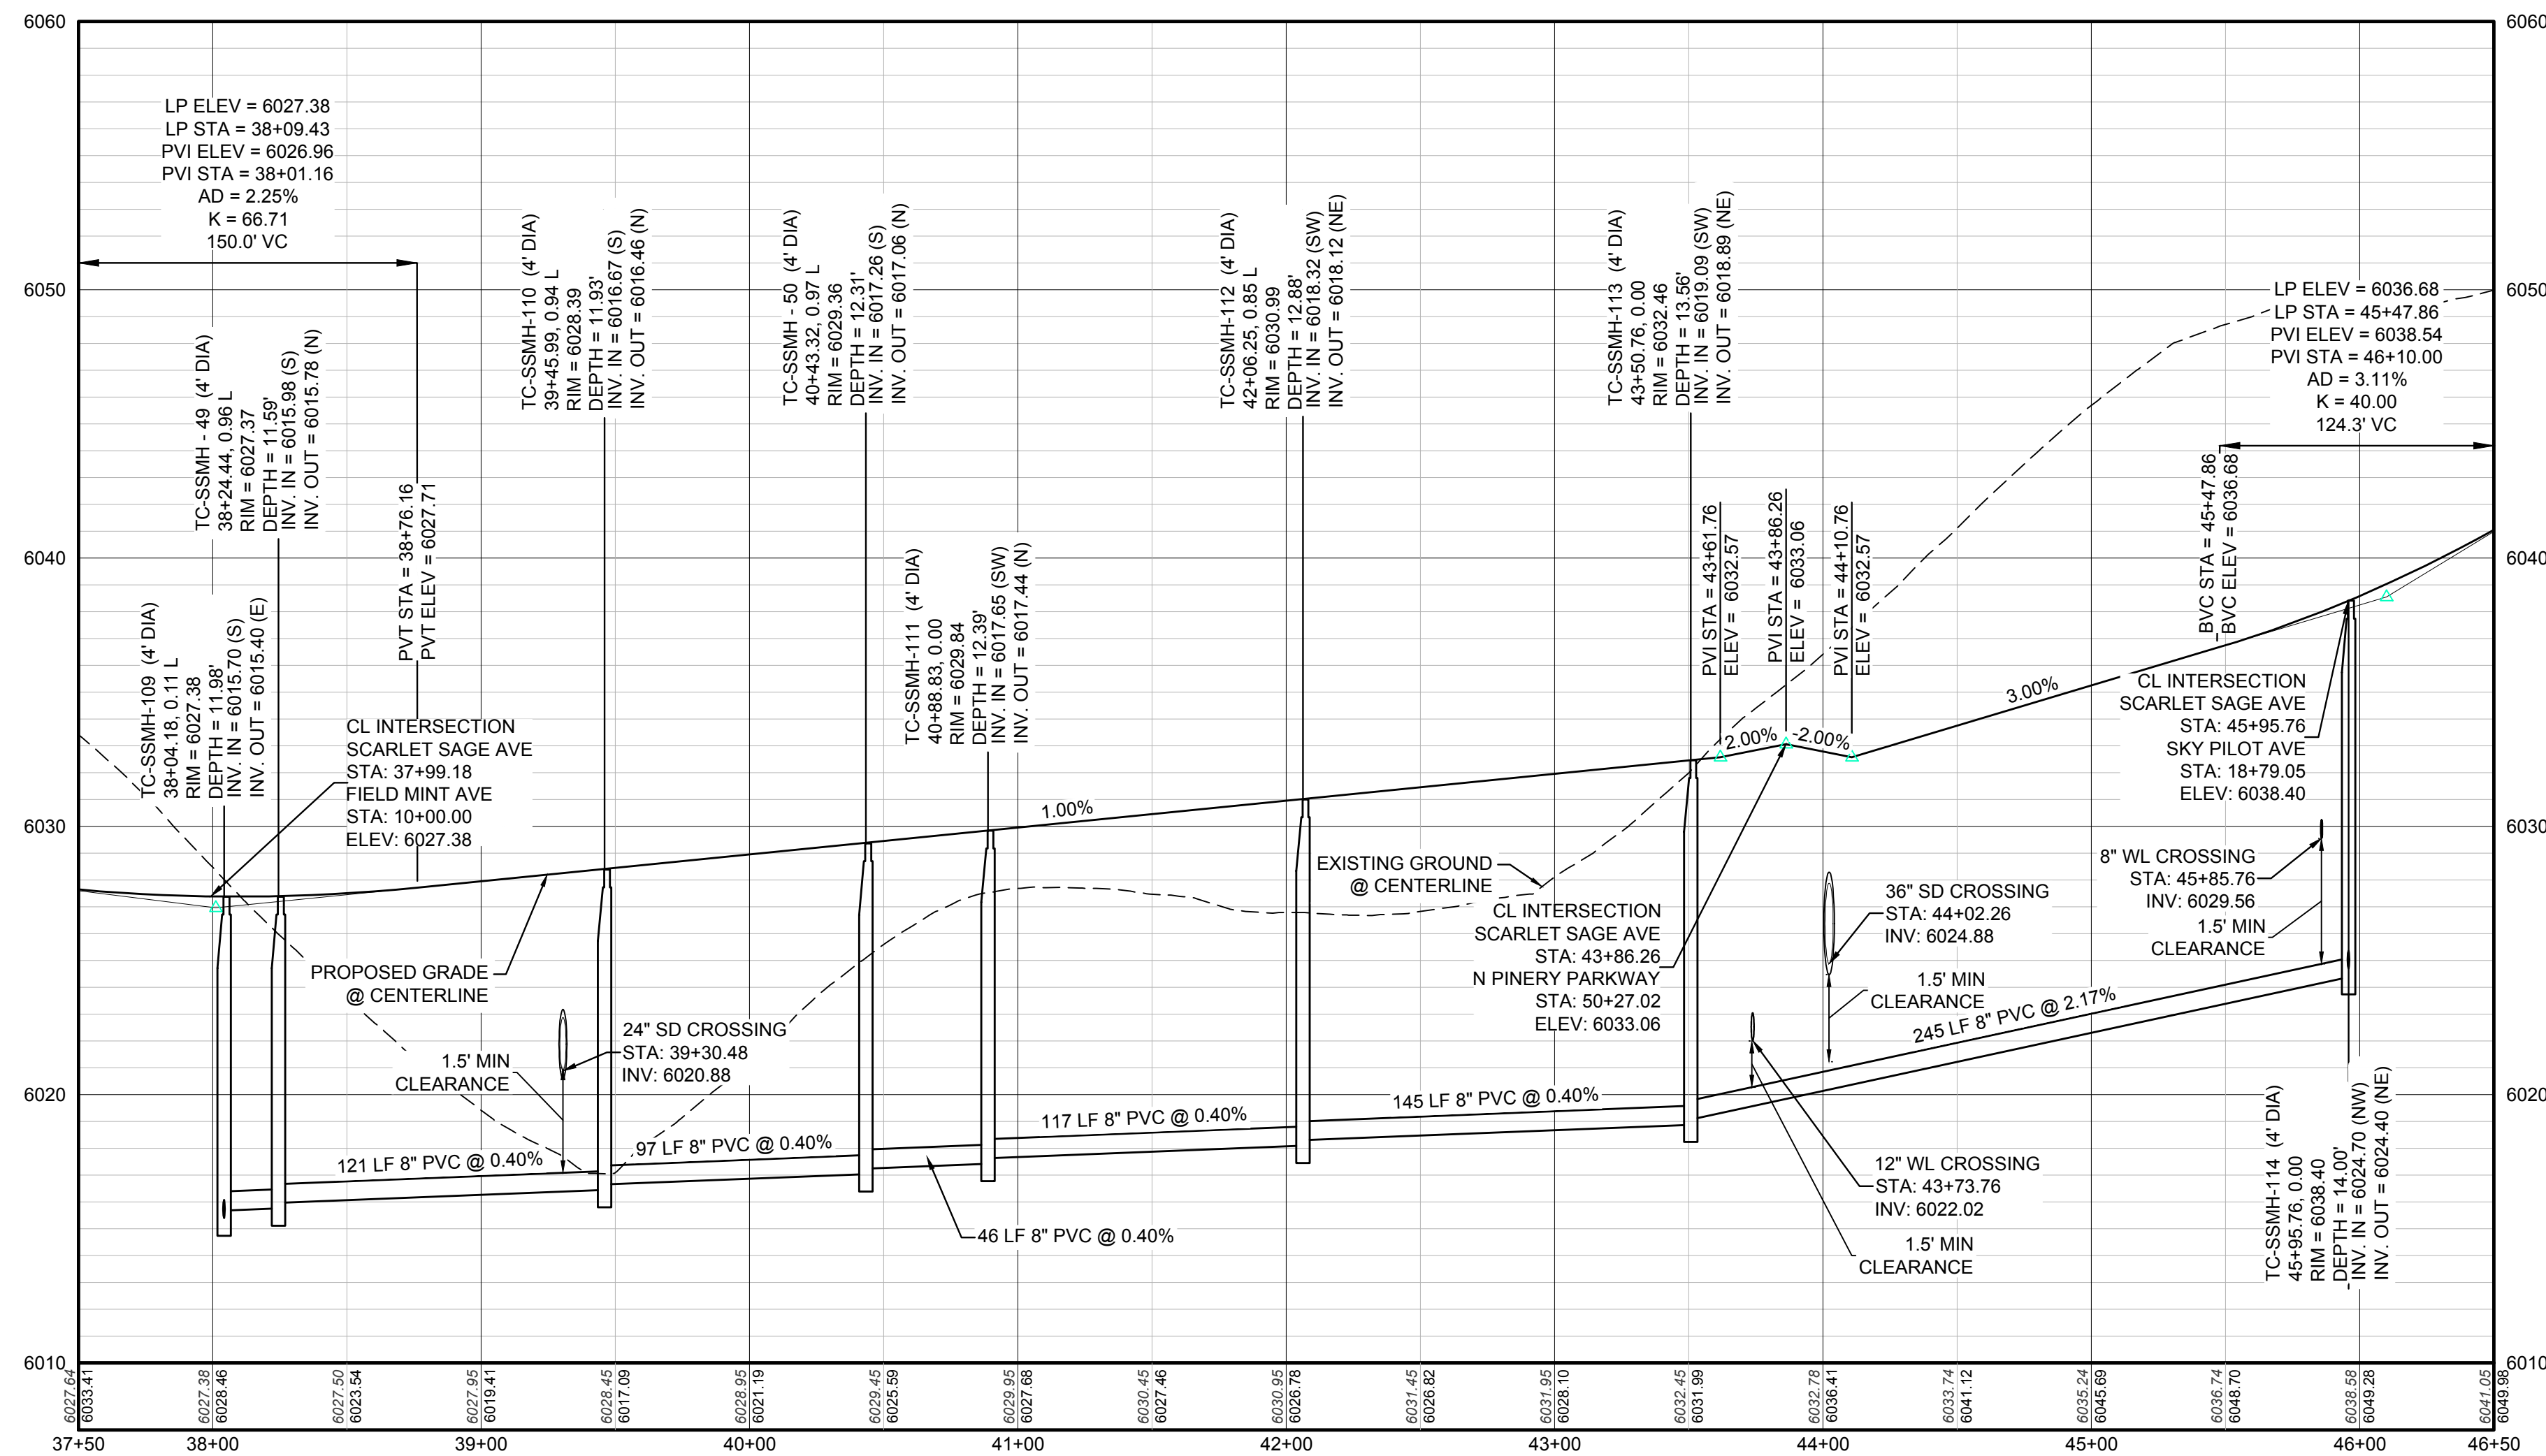


PROFILE: SCARLET SAGE AVE STA: 37+50.00 TO 46+50.00
HORIZONTAL: 1" = 50'
VERTICAL: 1" = 5'

BENCHMARK
DOUGLAS COUNTY CONTROL POINT KNOWN AS 1.060032, BEING A 3-1/4" ALUMINUM CAP, BEING LOCATED IN THE SOUTHWEST QUARTER OF SECTION 33, TOWNSHIP 6 SOUTH, RANGE 66 WEST OF THE SIXTH PRINCIPAL MERIDIAN, HAVING A PUBLISHED ELEVATION OF 1799.2870 METERS (5903.13 FEET) NAVD '88 DATUM.

BASIS OF BEARINGS:
THE EAST LINE OF THE NORTHEAST QUARTER OF SAID SECTION 9 BEING MONUMENTED AT THE NORTHEAST CORNER OF SAID SECTION 9 BY A 3-1/4" ALUMINUM CAP STAMPED LS 23053 AND AT THE EAST QUARTER CORNER OF SAID SECTION 9 BY A 2-1/2" ALUMINUM CAP STAMPED LS 6935 BEING CONSIDERED TO BEAR SOUTH 00°15'06" EAST, 2648.70 FEET.

PREPARED UNDER THE
SUPERVISION OF

BRIAN P. WILSON
COLORADO P.E. 0050067

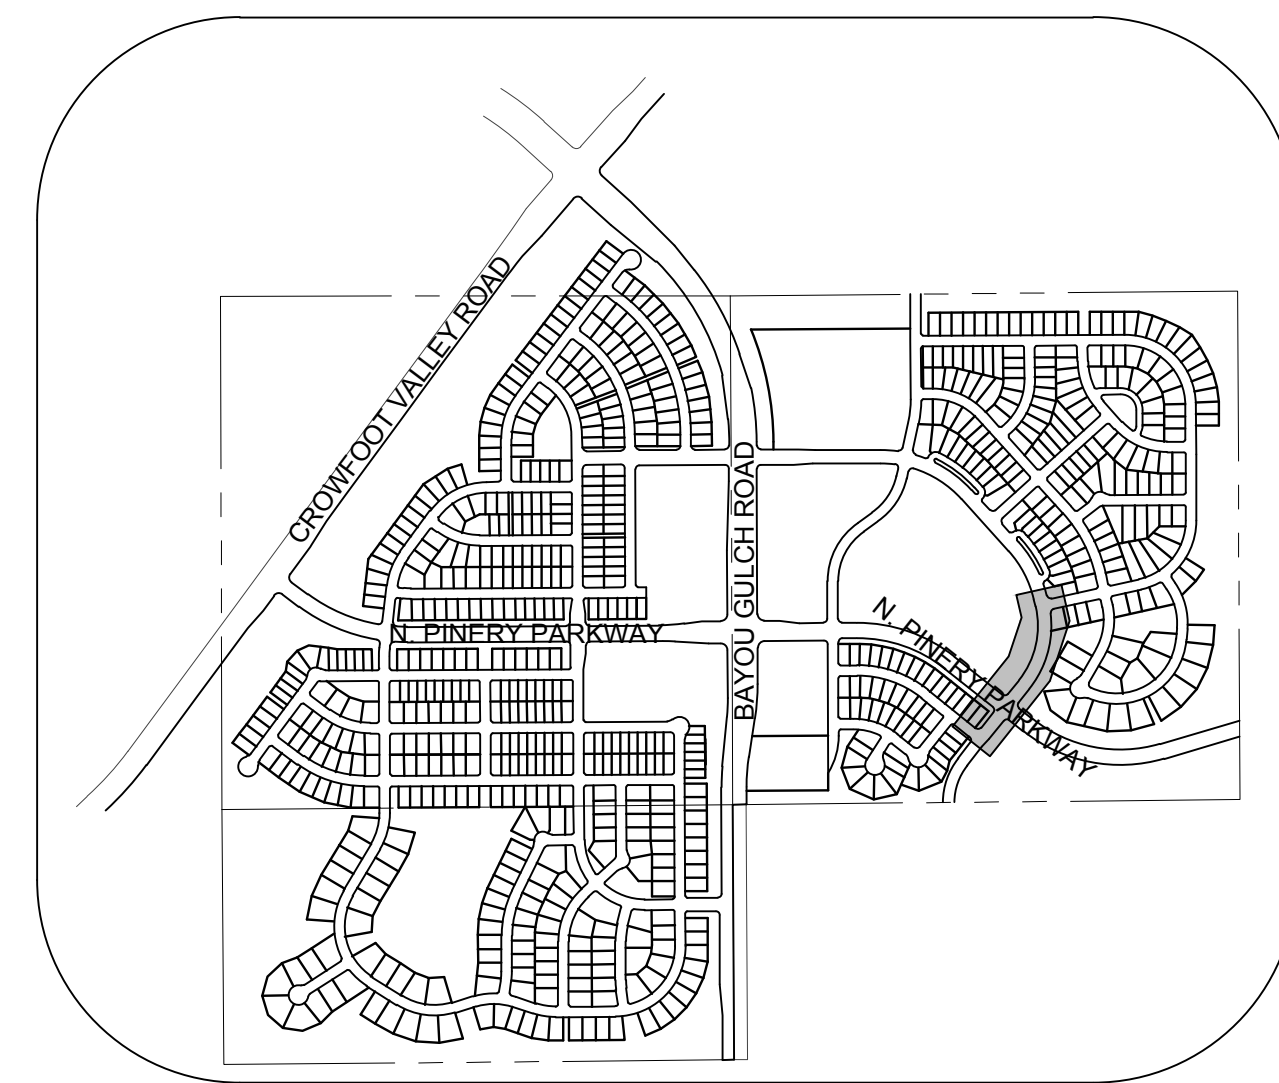

KEYMAP
N.T.S.
LEGEND

②	BLOCK NUMBER	△	PROPOSED RANGE POINT
Ⓐ	LOT TYPE	---	CENTERLINE
6	LOT NUMBER	---	RIGHT-OF-WAY
⊗	PROPOSED BUTTERFLY VALVE	---	PROPERTY LINE
⌋	PROPOSED CAP WITH END OF LINE BLOWOFF	---	EDGE OF PAVEMENT
⌋	PROPOSED REDUCER	→	PROPOSED DIRECTION OF FLOW
⊗	PROPOSED VALVE	1.0%	PROPOSED SLOPE & DIRECTION
⌋	PROPOSED FIRE HYDRANT	---	EXISTING 5' CONTOUR
⌋	PROPOSED WL FITTING WITH THRUST BLOCK	---	EXISTING 1' CONTOUR
⌋	PROPOSED FLARED END SECTION	---	PROPOSED 5' CONTOUR
⊗	PROPOSED LOW POINT BLOW-OFF	---	PROPOSED 1' CONTOUR
⊗	PROPOSED AIR VALVE	---	PROPOSED STORM DRAIN
⊗	FUTURE PHASE VALVE	---	PROPOSED SEWER LINE WITH MANHOLE
⊗	FUTURE FIRE HYDRANT	---	PROPOSED SEWER LATERAL
⊗	PROPOSED LIGHT POLE	---	PROPOSED WATER LINE
⊗	PROPOSED SIDEWALK	---	PROPOSED WATER LATERAL W/ METER
⊗	PROPOSED SIDEWALK RAMP	---	SECTION LINE
10.00	EXISTING ELEVATION	---	FILING BOUNDARY
10.00	PROPOSED DESIGN ELEVATION	---	EXISTING FIBER
⊗	PROPOSED STORM DRAIN INLET	---	OPTIC LINE
⊗	PROPOSED STORM DRAIN MANHOLE	---	EXISTING OVERHEAD POWER
⊗		---	EXISTING TELEPHONE LINE

ABBREVIATIONS

AD	ANGLE DIFFERENCE	MH	MANHOLE
AV	AIR VAC RELEASE VALVE	N.T.S.	NOT TO SCALE
BVC	BEGIN VERTICAL CURVE	PVC	POLYVINYL CHLORIDE
BVP	BEGIN VERTICAL PROFILE	PVI	PT. OF VERTICAL INTERSECTION
CBO	CAP WITH BLOW OFF	PVT	POINT OF VERTICAL TANGENT
CRR	CURB RETURN RADIUS	RCBC	REINFORCED CONCRETE BOX CULVERT
EL	ELEVATION	RCP	REINFORCED CONCRETE PIPE
EP	EDGE OF PAVEMENT	ROW	RIGHT OF WAY
EVC	END VERTICAL CURVE	SC	SANITARY CAP
EVP	END VERTICAL PROFILE	SD	STORM DRAIN
FG	FINISHED GROUND	SL	SECTION LINE
FH	FIRE HYDRANT	SS	SANITARY SEWER
FL	FLOW LINE	STA	STATION
GV	GATE VALVE	T.O.P.	TOP OF PIPE
HCR	HANDICAP CURB RAMP	UE	UTILITY EASEMENT
HP	HIGH POINT	VC	VERTICAL CURVE
INV	INVERT	WL	WATER LINE
K	CURVATURE COEFFICIENT	WLC	WATER LINE CONNECTION
LF	LINEAR FEET	WSE	WATER SURFACE ELEVATION

10333 E. Dry Creek Rd.
Englewood, CO 80110
Tel: (720) 482-9526
Fax: (720) 482-9548

CVL
CONSULTANTS

HR 935 LLC
7353 South Alton Way
CENTENNIAL, CO 80112

TRAILS AT CROWFOOT
FILING 9 CONSTRUCTION DRAWINGS
SANITARY SEWER PLAN AND PROFILE
SCARLET SAGE AVE

SCALE:
AS SHOWN

DRAWN BY:
KJD

CHECKED BY:
JLJ

DATE:
MAY 2017


FILE NO:
8130283701

SHEET NUMBER
6

Revisions
No. Date Init. Appr. Date


N:\PROJECTS\SSR\BANCROFT\ENGINEERING\SSR\BANCROFT\WATER AND SANITATION\SANITARY PLAN AND PROFILE\9 SCARLET SAGE AVE SANITARY DWG, BRIANW, 2/26/2019 6:16 PM

SEE PLAN VIEW SHEET 6

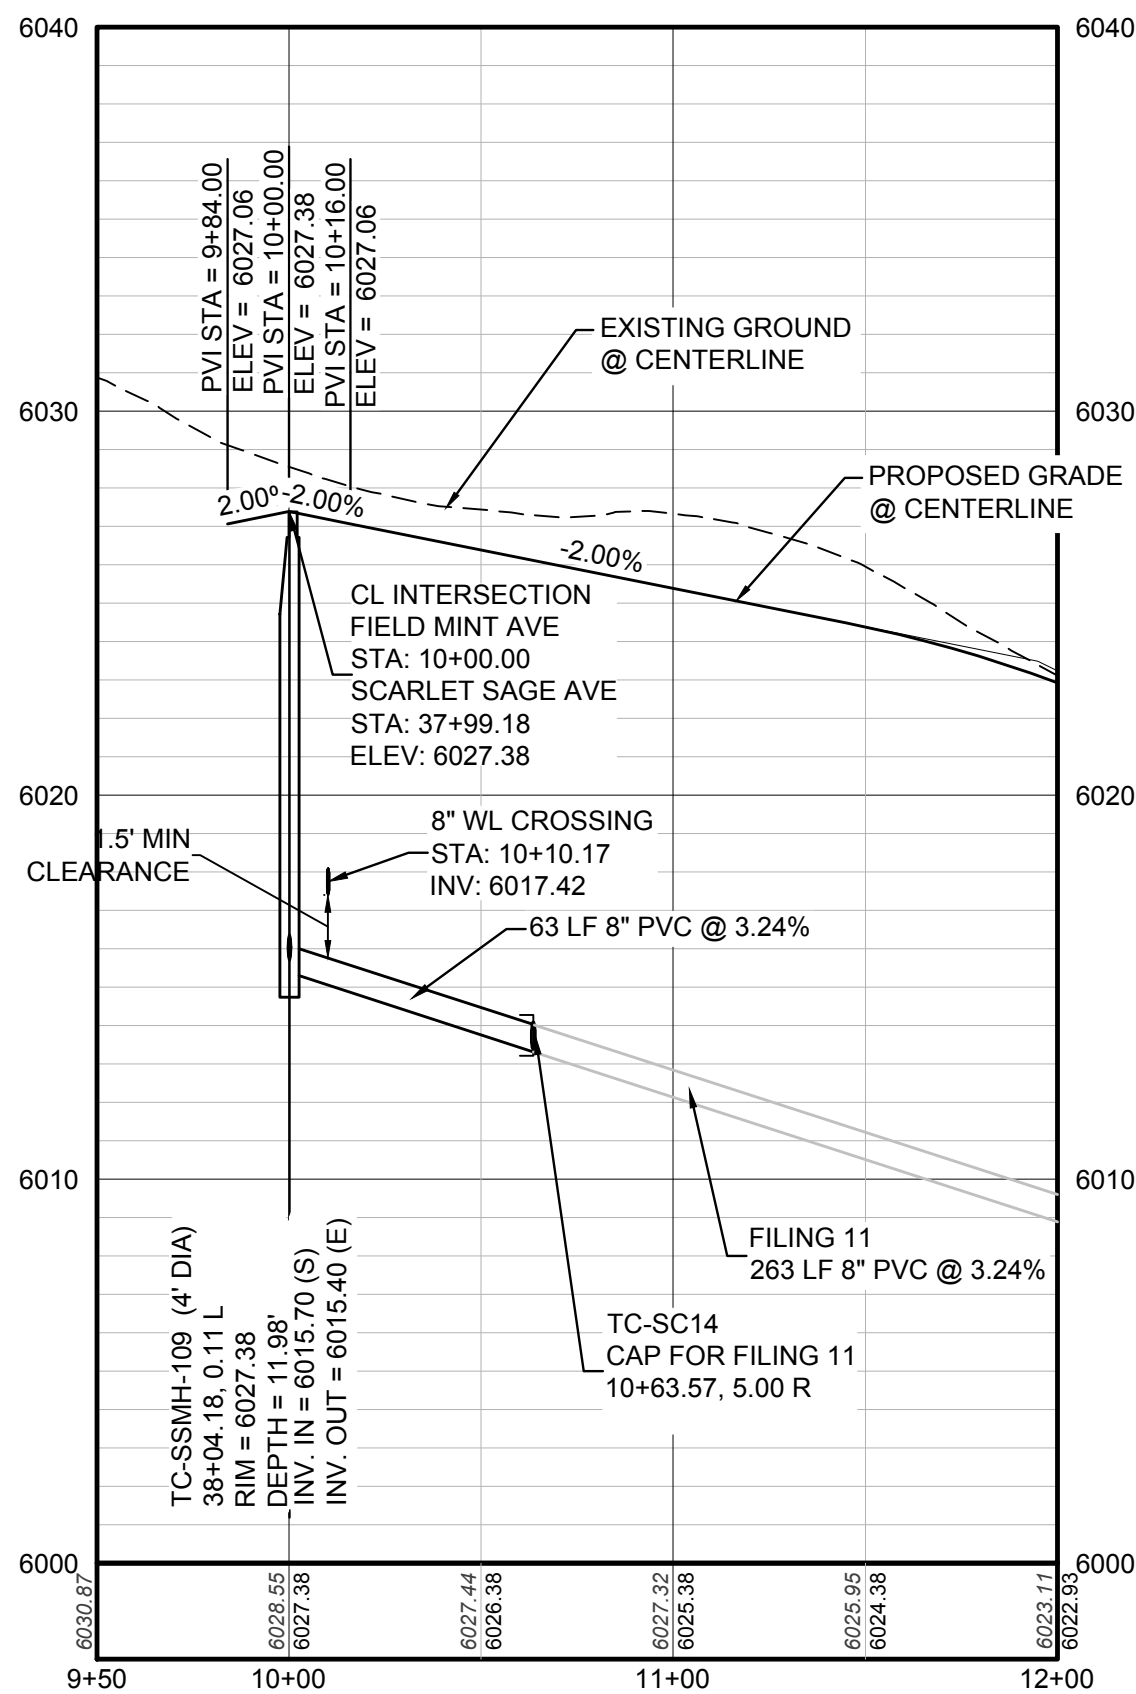


PROFILE: FIELD MINT AVE STA: 9+50.00 TO 12+00.00
HORIZONTAL: 1" = 50'
VERTICAL: 1" = 5'


SEE PLAN VIEW SHEET 6

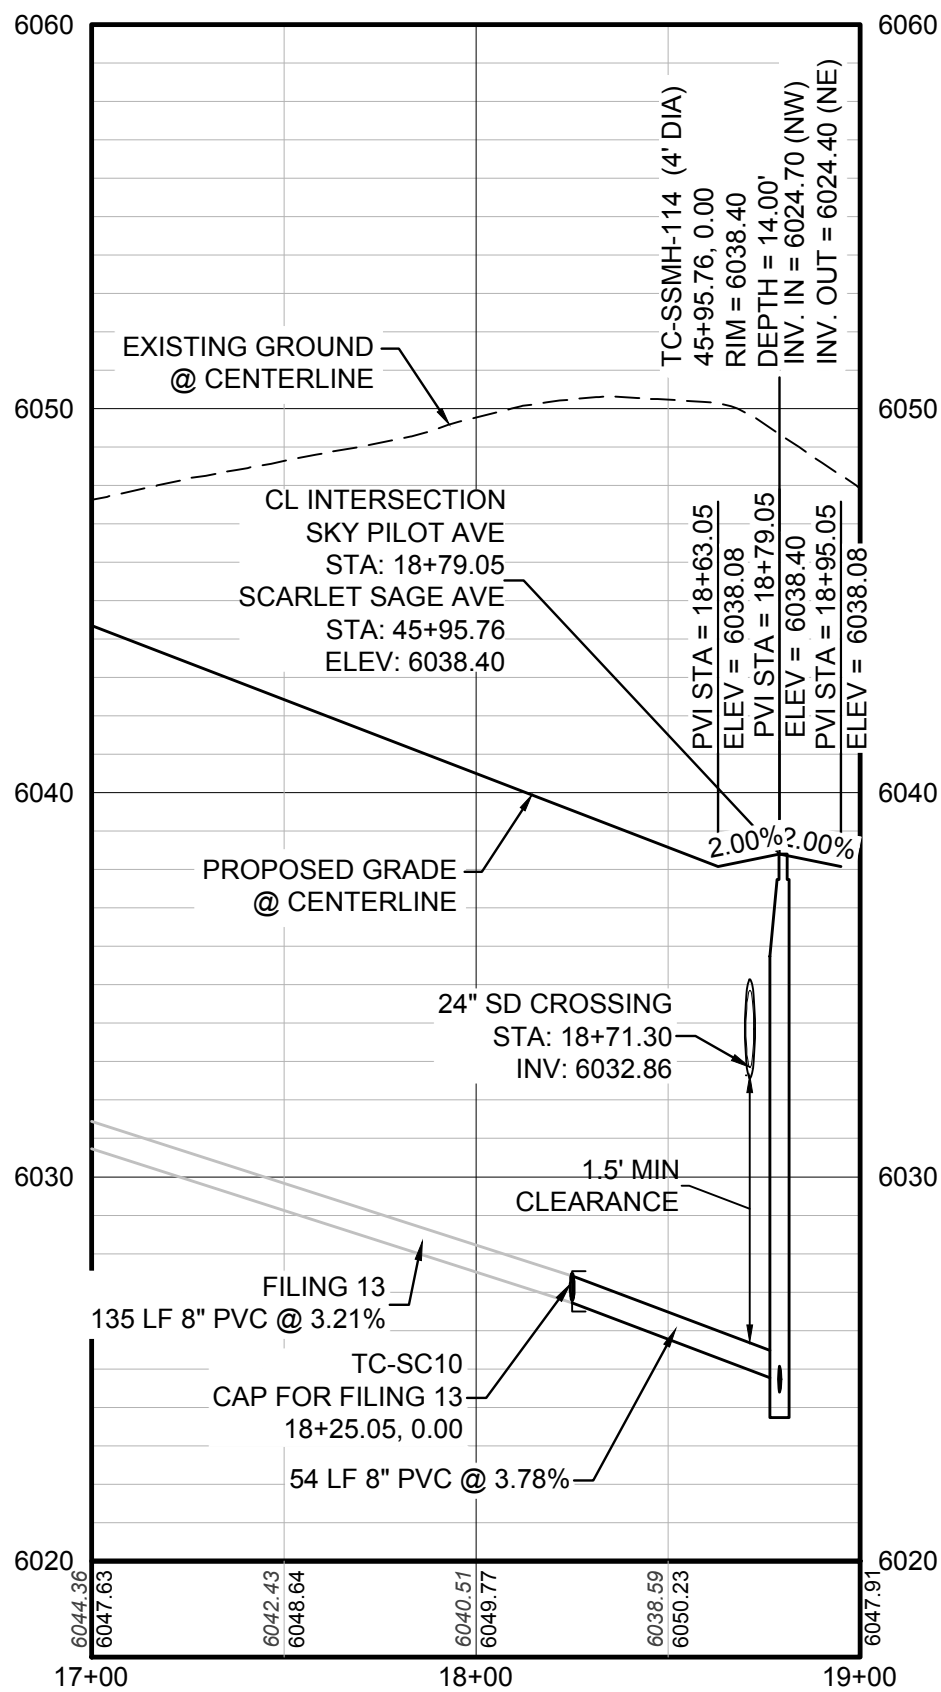


PROFILE: SKY PILOT AVE STA: 17+00.00 TO 19+00.00
HORIZONTAL: 1" = 50'
VERTICAL: 1" = 5'

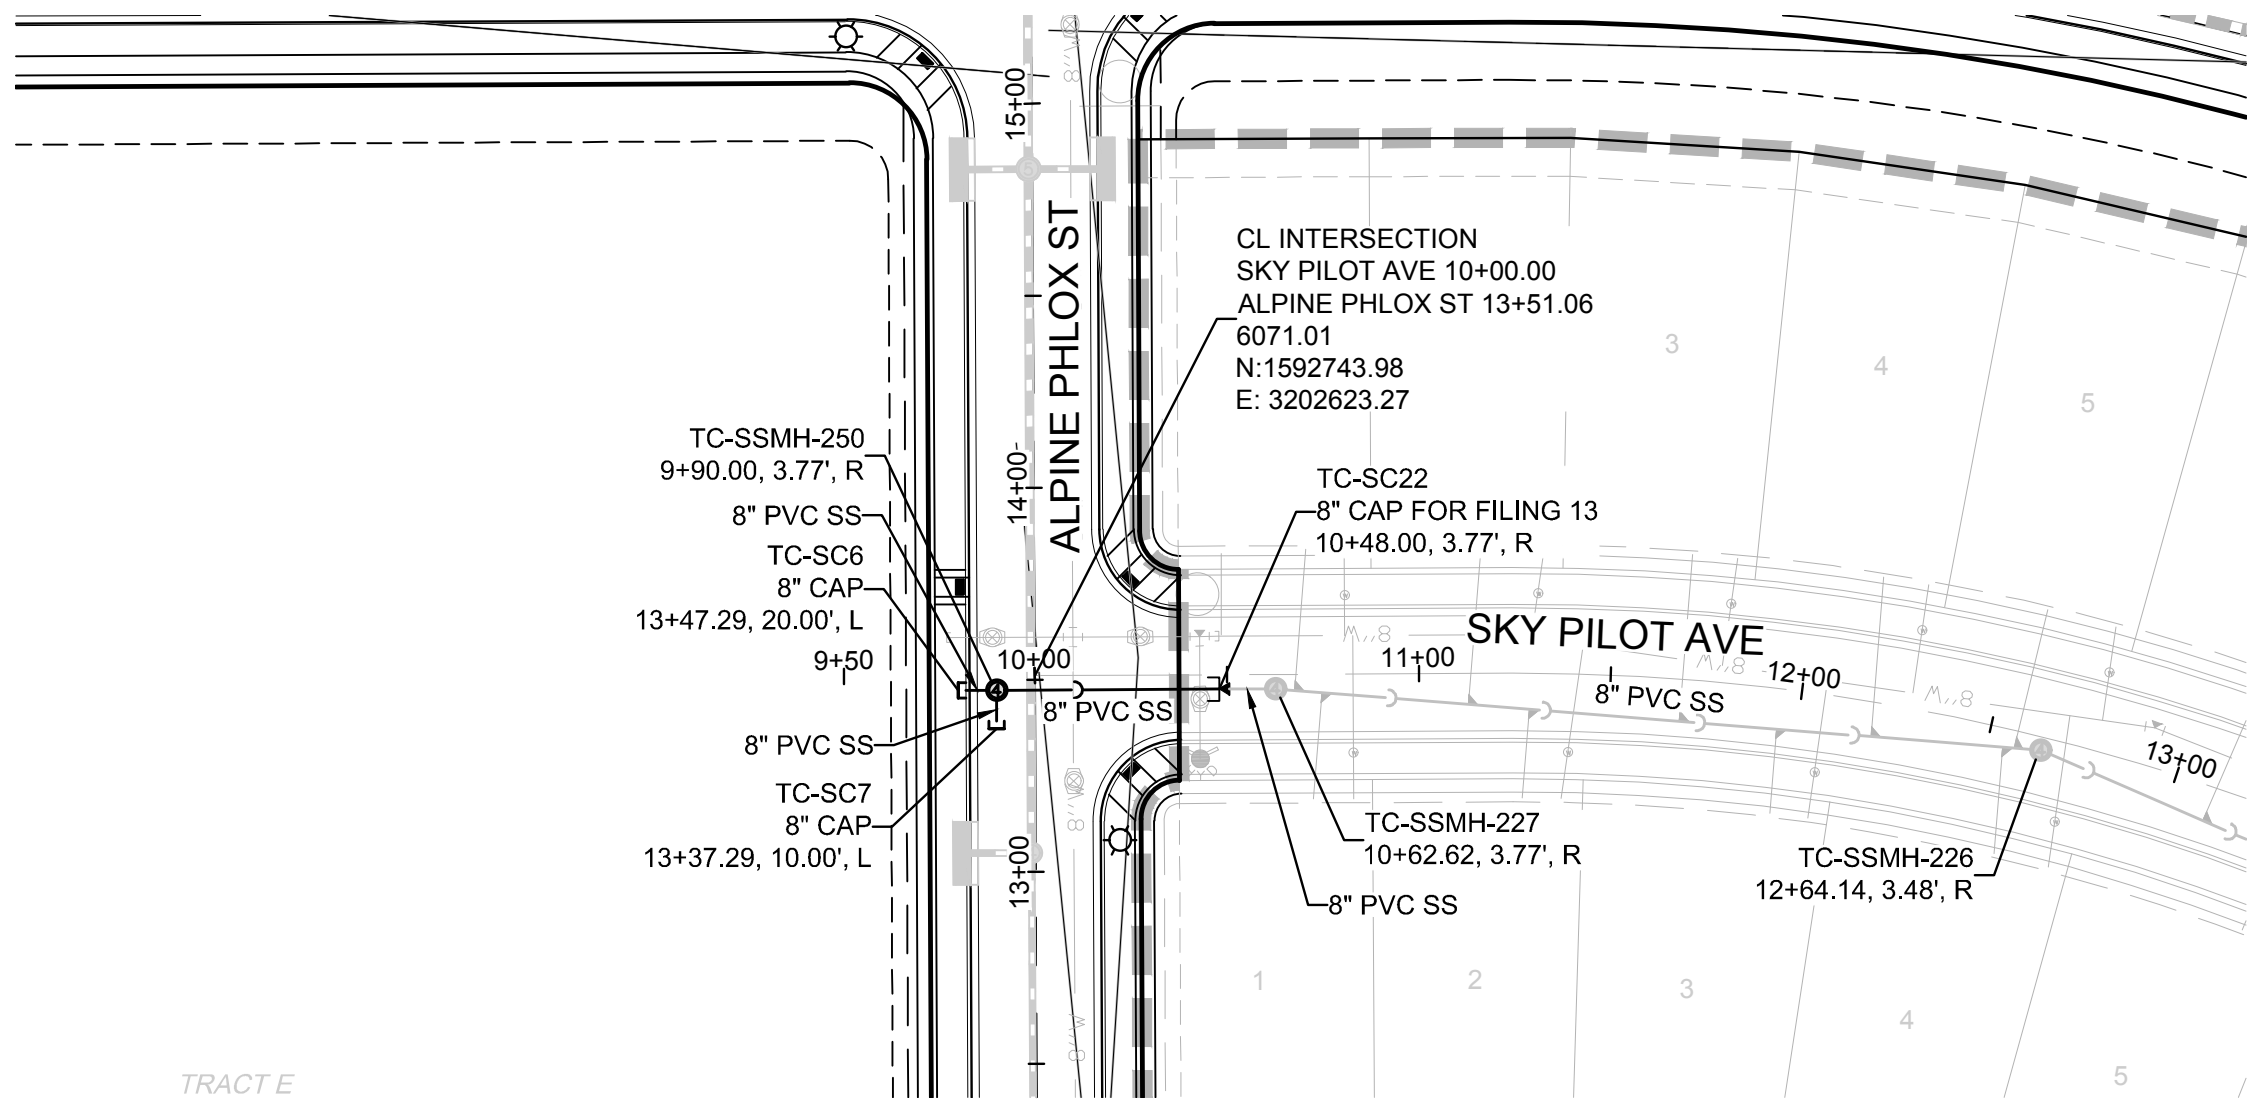


PLAN: SKY PILOT AVE STA: 9+50.00 TO 13+00.00
HORIZONTAL SCALE: 1" = 50'

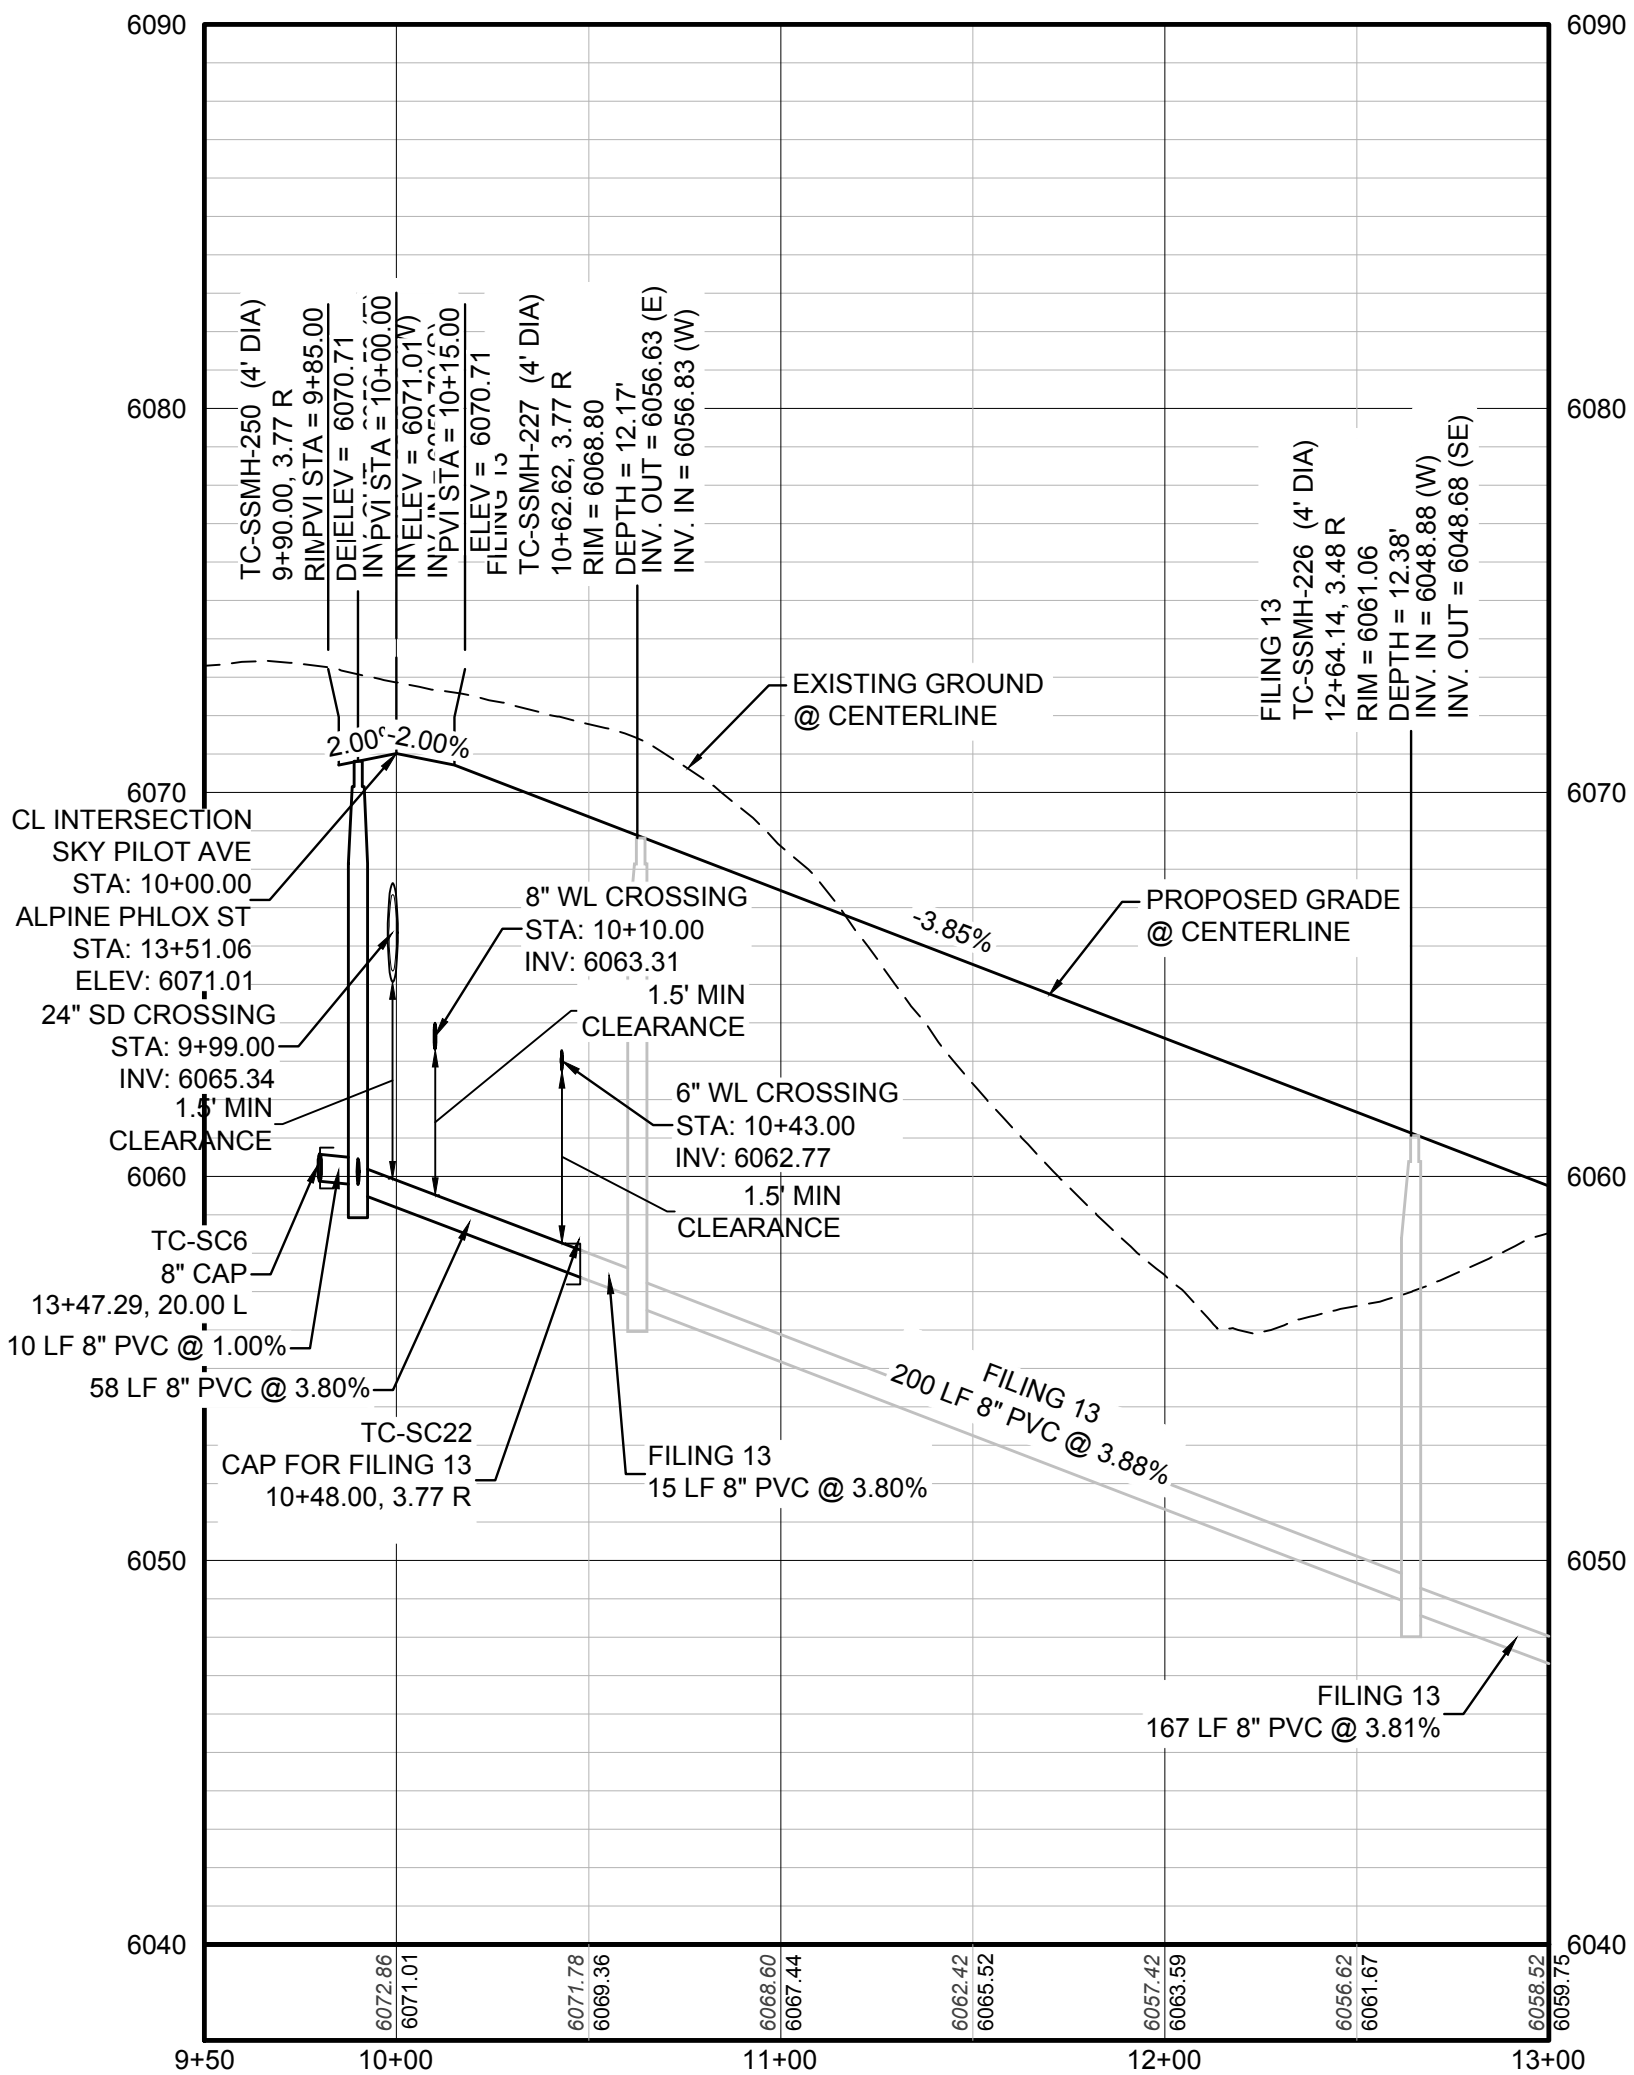

PROFILE: SKY PILOT AVE STA: 9+50.00 TO 13+00.00
HORIZONTAL: 1" = 50'
VERTICAL: 1" = 5'

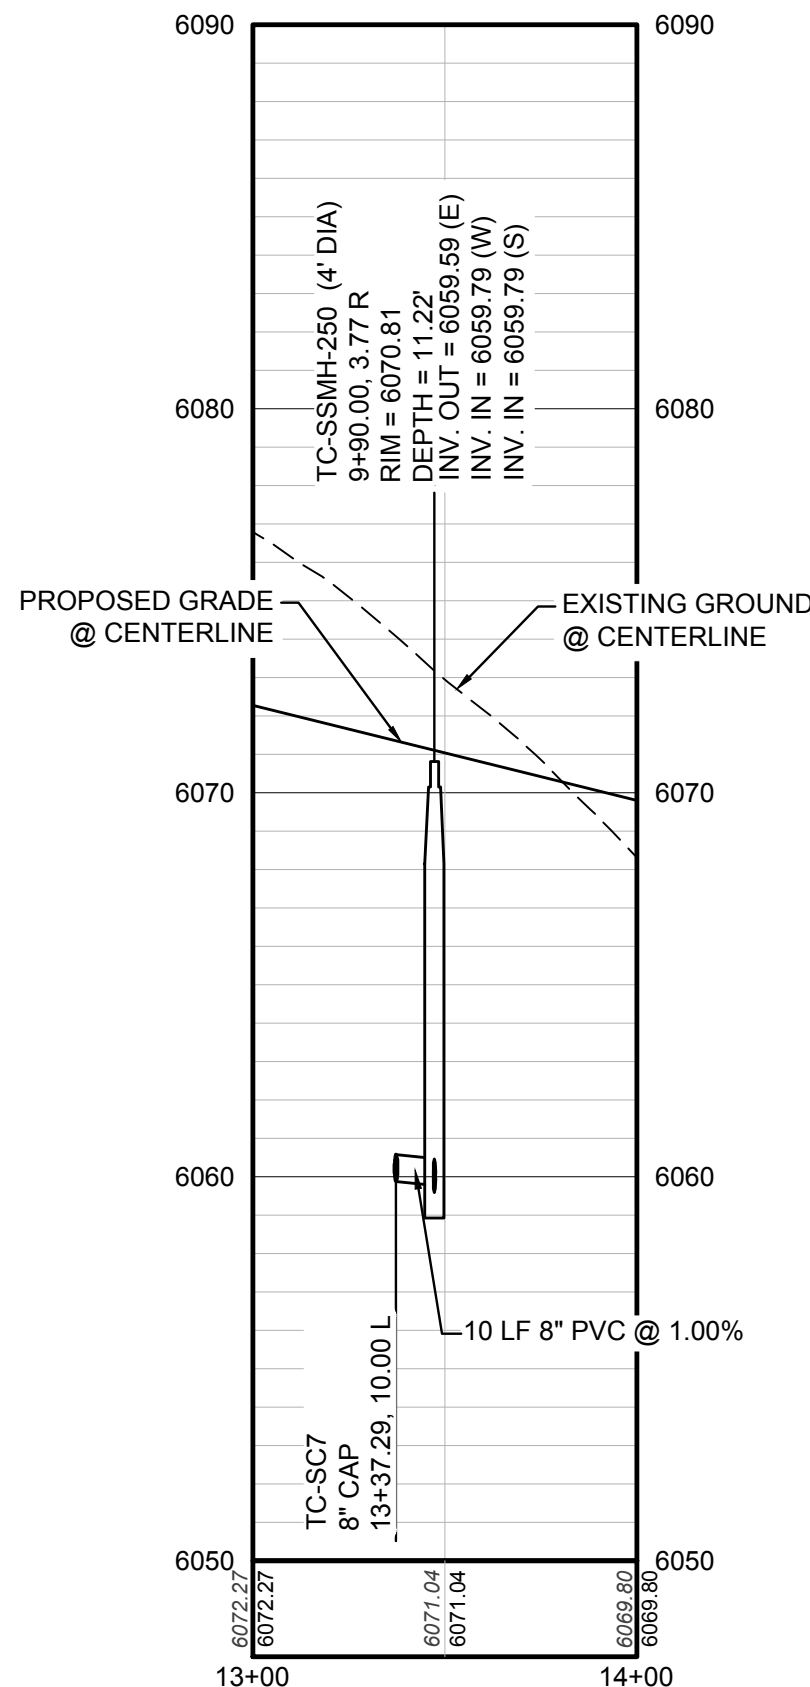

PROFILE: ALPINE PHLOX ST STA: 13+00.00 TO 14+00.00
HORIZONTAL: 1" = 50'
VERTICAL: 1" = 5'

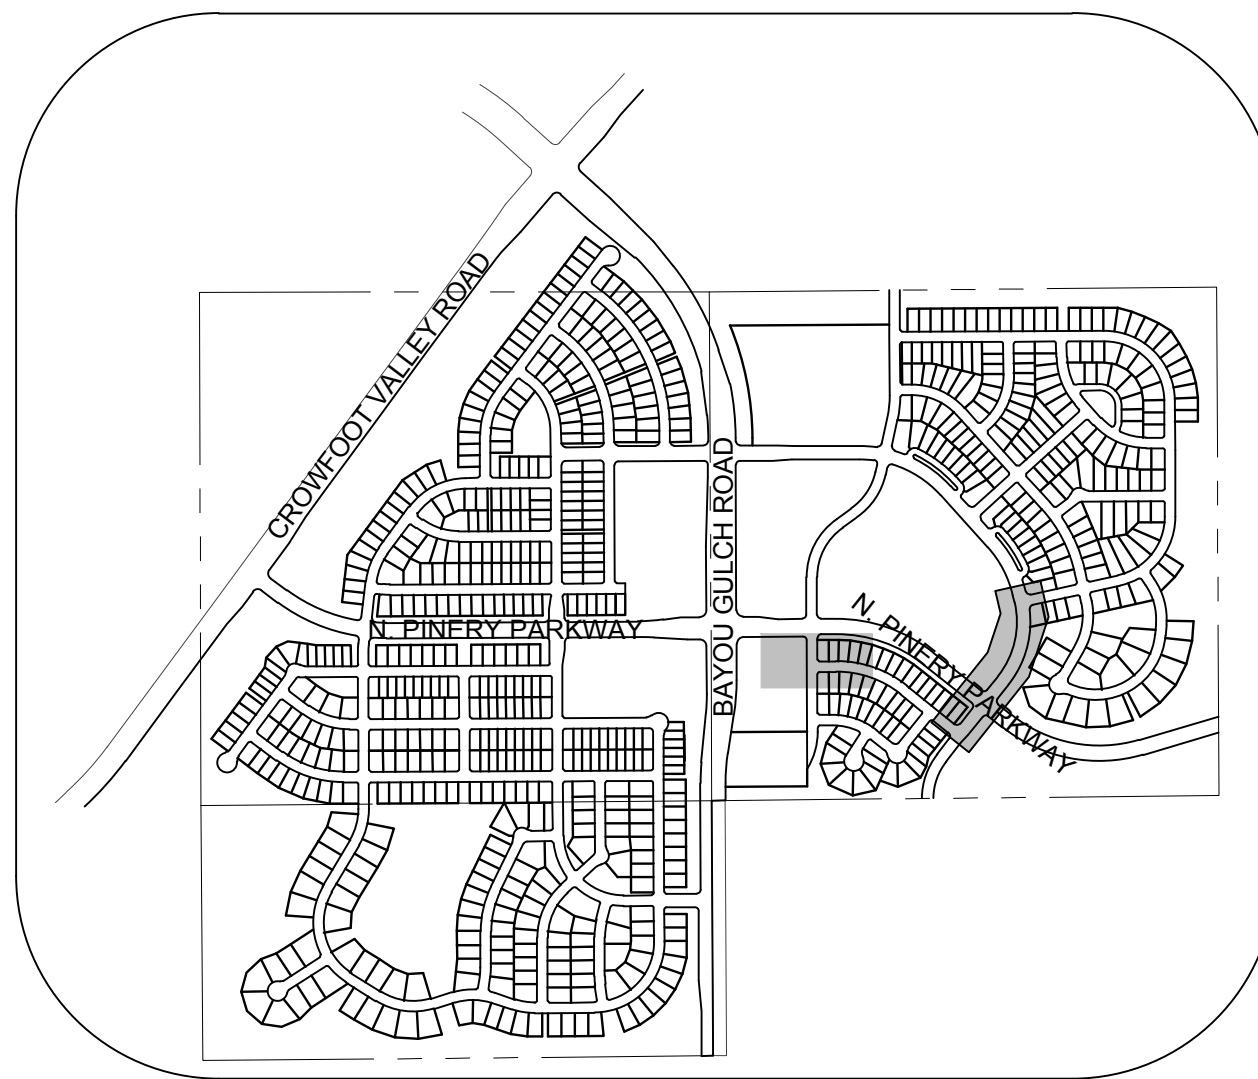

KEYMAP
N.T.S.
LEGEND

②	BLOCK NUMBER	△	PROPOSED RANGE POINT
Ⓐ	LOT TYPE	---	CENTERLINE
6	LOT NUMBER	---	RIGHT-OF-WAY
⊗	PROPOSED BUTTERFLY VALVE	---	PROPERTY LINE
⌋	PROPOSED CAP WITH END OF LINE BLOWOFF	---	EDGE OF PAVEMENT
⌋	PROPOSED REDUCER	→	PROPOSED DIRECTION OF FLOW
⊗	PROPOSED VALVE	1.0%	PROPOSED SLOPE & DIRECTION
⌋	PROPOSED FIRE HYDRANT	5615	EXISTING 5' CONTOUR
⌋	PROPOSED WL FITTING WITH THRUST BLOCK	5616	EXISTING 1' CONTOUR
⌋	PROPOSED FLARED END SECTION	5620	PROPOSED 5' CONTOUR
⊗	PROPOSED LOW POINT BLOW-OFF	5607	PROPOSED 1' CONTOUR
⊗	PROPOSED AIR VALVE	---	PROPOSED STORM DRAIN
⊗	FUTURE PHASE VALVE	---	PROPOSED SEWER LINE WITH MANHOLE
⊗	FUTURE FIRE HYDRANT	---	PROPOSED SEWER LATERAL
⊗	PROPOSED LIGHT POLE	---	PROPOSED WATER LINE
⌋	PROPOSED SIDEWALK	---	PROPOSED WATER LATERAL W/ METER
⌋	PROPOSED SIDEWALK RAMP	---	SECTION LINE
10.00	EXISTING ELEVATION	---	FILING BOUNDARY
10.00	PROPOSED DESIGN ELEVATION	---	EXISTING FIBER
⊗	PROPOSED STORM DRAIN INLET	---	EXISTING OVERHEAD POWER
⊗	PROPOSED STORM DRAIN MANHOLE	---	EXISTING TELEPHONE LINE

ABBREVIATIONS

AD	ANGLE DIFFERENCE	MH	MANHOLE
AV	AIR VAC RELEASE VALVE	N.T.S.	NOT TO SCALE
BVC	BEGIN VERTICAL CURVE	PVC	POLYVINYL CHLORIDE
BVP	BEGIN VERTICAL PROFILE	PVI	PT. OF VERTICAL INTERSECTION
CBO	CAP WITH BLOW OFF	PVT	POINT OF VERTICAL TANGENT
CRR	CURB RETURN RADIUS	RCBC	REINFORCED CONCRETE BOX CULVERT
EL	ELEVATION	RCP	REINFORCED CONCRETE PIPE
EP	EDGE OF PAVEMENT	ROW	RIGHT OF WAY
EVC	END VERTICAL CURVE	SC	SANITARY CAP
EVP	END VERTICAL PROFILE	SD	STORM DRAIN
FG	FINISHED GROUND	SL	SECTION LINE
FH	FIRE HYDRANT	SS	SANITARY SEWER
FL	FLOW LINE	STA	STATION
GV	GATE VALVE	T.O.P.	TOP OF PIPE
HCR	HANDICAP CURB RAMP	UE	UTILITY EASEMENT
HP	HIGH POINT	VC	VERTICAL CURVE
INV	INVERT	WL	WATER LINE
K	CURVATURE COEFFICIENT	WLC	WATER LINE CONNECTION
LF	LINEAR FEET	WSE	WATER SURFACE ELEVATION


BENCHMARK
DOUGLAS COUNTY CONTROL POINT KNOWN AS 1.060032, BEING A 3-1/4" ALUMINUM CAP, BEING LOCATED IN THE SOUTHWEST QUARTER OF SECTION 33, TOWNSHIP 6 SOUTH, RANGE 66 WEST OF THE SIXTH PRINCIPAL MERIDIAN, HAVING A PUBLISHED ELEVATION OF 1799.2870 METERS (5903.13 FEET) NAVD '88 DATUM.

BASIS OF BEARINGS:
THE EAST LINE OF THE NORTHEAST QUARTER OF SAID SECTION 9 BEING MONUMENTED AT THE NORTHEAST CORNER OF SAID SECTION 9 BY A 3-1/4" ALUMINUM CAP STAMPED LS 23053 AND AT THE EAST QUARTER CORNER OF SAID SECTION 9 BY A 2-1/2" ALUMINUM CAP STAMPED LS 6935 BEING CONSIDERED TO BEAR SOUTH 00°15'06" EAST, 2648.70 FEET.

PREPARED UNDER THE SUPERVISION OF

BRIAN P. WILSON
COLORADO P.E. 0050067

10333 E. Dry Creek Rd.
Englewood, CO 80150
Tel: (720) 482-9526
Fax: (720) 482-9548

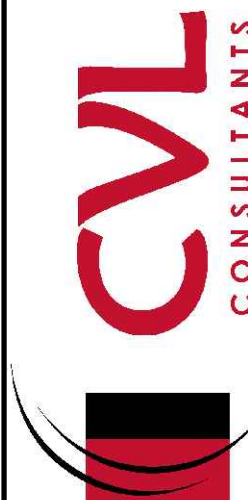


HR 935 LLC
7353 South Alton Way
CENTENNIAL, CO 80112

TRAILS AT CROWFOOT
FILING 9 CONSTRUCTION DRAWINGS
SANITARY SEWER PLAN AND PROFILE
SCARLET SAGE AVE LATERALS

SCALE: K/D
AS SHOWN
FILE NO: 8130283701
DATE: MAY 2017

SHEET NUMBER
7

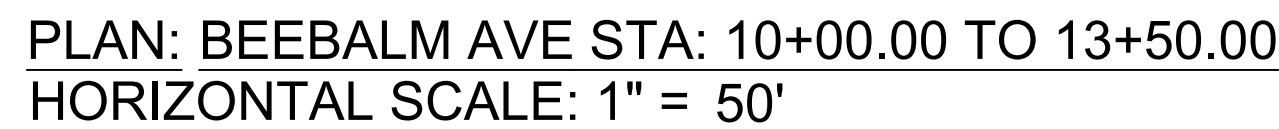

ABBREVIATIONS

AD	ANGLE DIFFERENCE	MH	MANHOLE
AV	AIR VAC RELEASE VALVE	N.T.S	NOT TO SCALE
BVC	BEGIN VERTICAL CURVE	PVC	POLYVINYL CHLORIDE
BVP	BEGIN VERTICAL PROFILE	PVI	PT. OF VERTICAL INTERSECTION
CBO	CAP WITH BLOW OFF	PVT	POINT OF VERTICAL TANGENT
CRR	CURB RETURN RADIUS	RCB	REINFORCED CONCRETE BOX CULVERT
EL	ELEVATION	RCP	REINFORCED CONCRETE PIPE
EP	EDGE OF PAVEMENT	ROW	RIGHT OF WAY
EVC	END VERTICAL CURVE	SC	SANITARY CAP
EVP	END VERTICAL PROFILE	SD	STORM DRAIN
FG	FINISHED GROUND	SL	SECTION LINE
FH	FIRE HYDRANT	SS	SANITARY SEWER
FL	FLOW LINE	STA	STATION
GV	GATE VALVE	T.O.P	TOP OF PIPE
HCR	HANDICAP CURB RAMP	UE	UTILITY EASEMENT
HP	HIGH POINT	VC	VERTICAL CURVE
INV	INVERT	WL	WATER LINE
K	CURVATURE COEFFICIENT	WLC	WATER LINE CONNECTION
LF	LINEAR FEET	WSE	WATER SURFACE ELEVATION

SHEET NUMBER

8

PREPARED UNDER THE
SUPERVISION OF

BRIAN P. WILSON
COLORADO P.E. 0050067

INSPECTION POLICY:

1. ALL SERVICE INSPECTIONS MUST BE SCHEDULED WITH THE DISTRICT OFFICE AT LEAST 24 HOURS IN ADVANCE OF THE REQUESTED INSPECTION.
2. IF THE CONTRACTOR IS NOT READY FOR INSPECTION WHEN THE INSPECTOR ARRIVES AT THE SITE, A RE-INSPECTION WILL HAVE TO BE SCHEDULED IN ACCORDANCE WITH NOTE 1 ABOVE AND A RE-INSPECTION FEE CHARGED.
3. SHOULD THE SERVICE LINES BE DAMAGED BY LATER CONSTRUCTION, AN INSPECTION OF THE REPAIR WILL BE REQUIRED IN ACCORDANCE WITH NOTES 1 AND 2 ABOVE.
4. THE CONTRACTOR SHALL LEAVE ALL PIPE AND FITTINGS EXPOSED FOR THE INSPECTOR TO OBSERVE. INSPECTORS WILL NOT ENTER ANY EXCAVATIONS TO CHECK MATERIALS. THE TOP LAYER OF BEDDING CAN BE ADDED AFTER THE INSPECTION HAS BEEN COMPLETED.
5. ALL EXCAVATIONS SHALL BE IN ACCORDANCE WITH OSHA STANDARDS.
6. LOTS WITHOUT BUILDING ADDRESSES OR LOT AND BLOCK NUMBERS BEFORE DISTRICT INSPECTION OR METER SET WILL FAIL AUTOMATICALLY.
7. CONTRACTOR MUST BE PRESENT AT TIME OF INSPECTION UNLESS COORDINATED WITH DISTRICT INSPECTOR.


INSTALLATION NOTES:

SEWER


1. ACCEPTABLE PIPE MATERIALS ARE TO BE SDR 35 PVC PIPE, ABS PIPE AND PVC SCHD 40 PIPE. APPROVED BEDDING IS TO BE SQUEEGEE.
2. NO-HUB CLAMPS SHALL BE USED TO JOIN 2 MALE PIPE ENDS WITH A MAXIMUM DEFLECTION OF 3'.
3. MINIMUM GRADE SHALL BE 2%.
4. INSTALLATION SHALL INCLUDE NO MORE THAN 3 BENDS. 90° BENDS ARE NOT ALLOWED. SOLVENT WELDED PIPE WILL NOT BE ALLOWED.
5. CLEAN-OUTS SHALL BE INSTALLED AT 100' INTERVALS AND EVERY CHANGE IN DIRECTION. CLEAN-OUTS ARE NOT REQUIRED FOR SERVICES LESS THAN 100' UNLESS THERE ARE CHANGES IN DIRECTION. PROVIDE DUAL CLEAN-OUT WITHIN 5 FEET OF FOUNDATION.
6. STRESSING OF THE PIPE BETWEEN FITTINGS WILL NOT BE ALLOWED.
7. SEWER SERVICE LINE SHALL NOT BE LOCATED UNDER CONCRETE SURFACE.
8. ALL SERVICES WILL BE PERMANENTLY MARKED ON CURB FACE AS FOLLOWS:
"X" FOR SANITARY SEWER SERVICE
"V" FOR WATER SERVICES

PARKER WATER & SANITATION DISTRICT	
DISTRICT POLICIES & INSTALLATION NOTES FOR SEWER SERVICES	
SCALE: NONE	DATE: 2/96
APPROVED: PVR	01/02 10/16
DIRECTOR OF ENGINEERING	1/16

SHEET S1.1

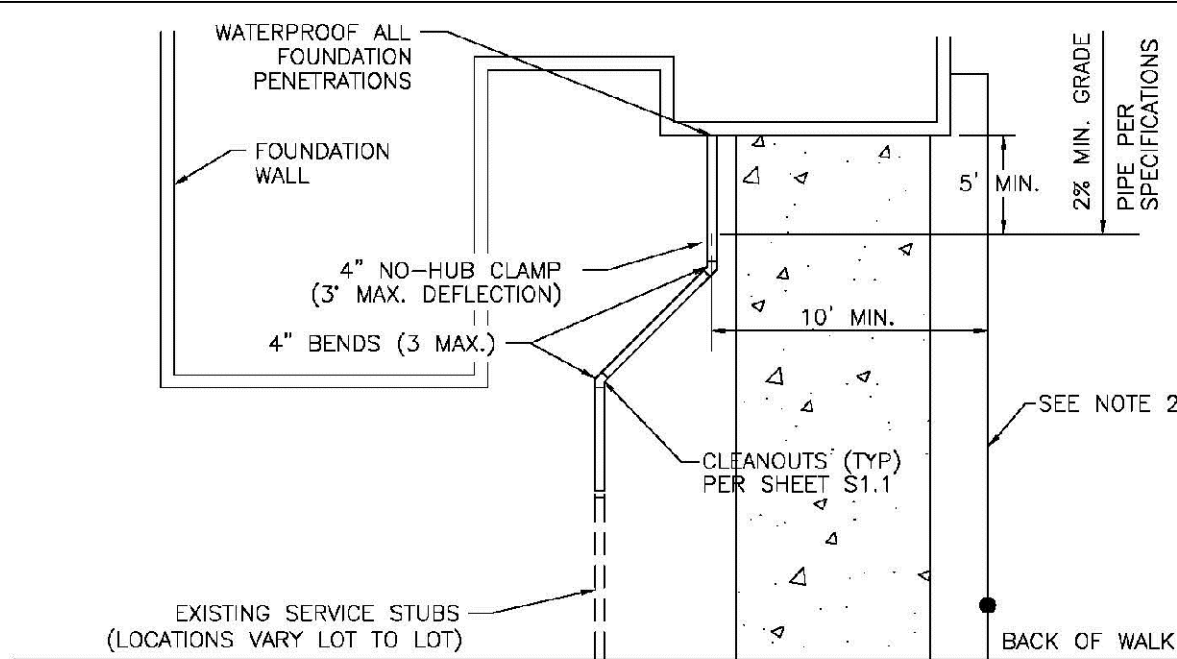

TYPICAL SERVICES PLAN VIEW

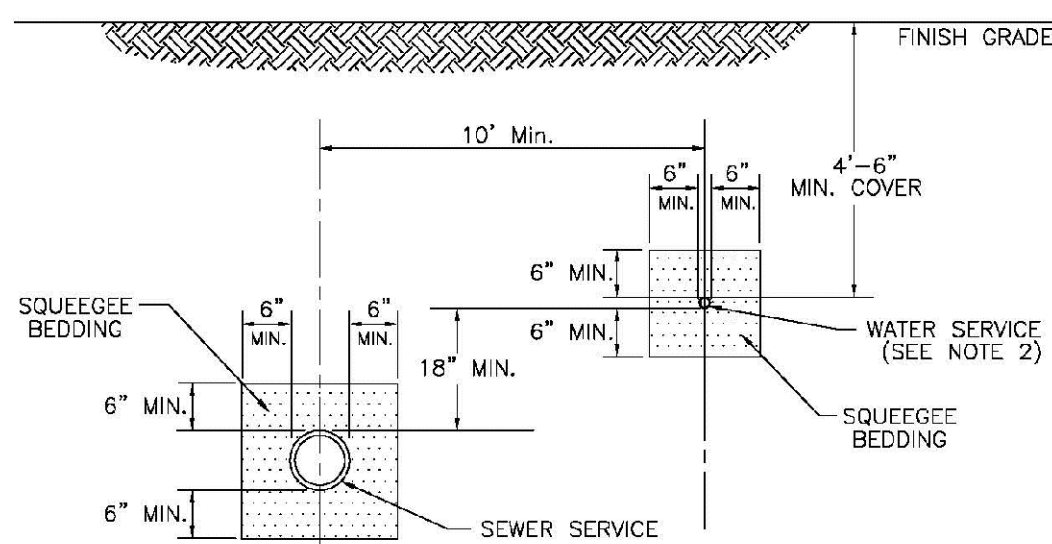


TYPICAL SERVICES SECTION

- NOTE:
1. SEE SHEET S1.1 FOR DISTRICT POLICIES AND INSTALLATION NOTES.
 2. TYPICAL WATER SERVICES SHOWN ON SHEET W1.2 IN WATER DETAILS.

PARKER WATER & SANITATION DISTRICT	
TYPICAL SEWER SERVICES	
SCALE: NONE	DATE: 2/96
APPROVED: PVR	2/00 01/02 01/16 10/16
DIRECTOR OF ENGINEERING	


SHEET S1.2

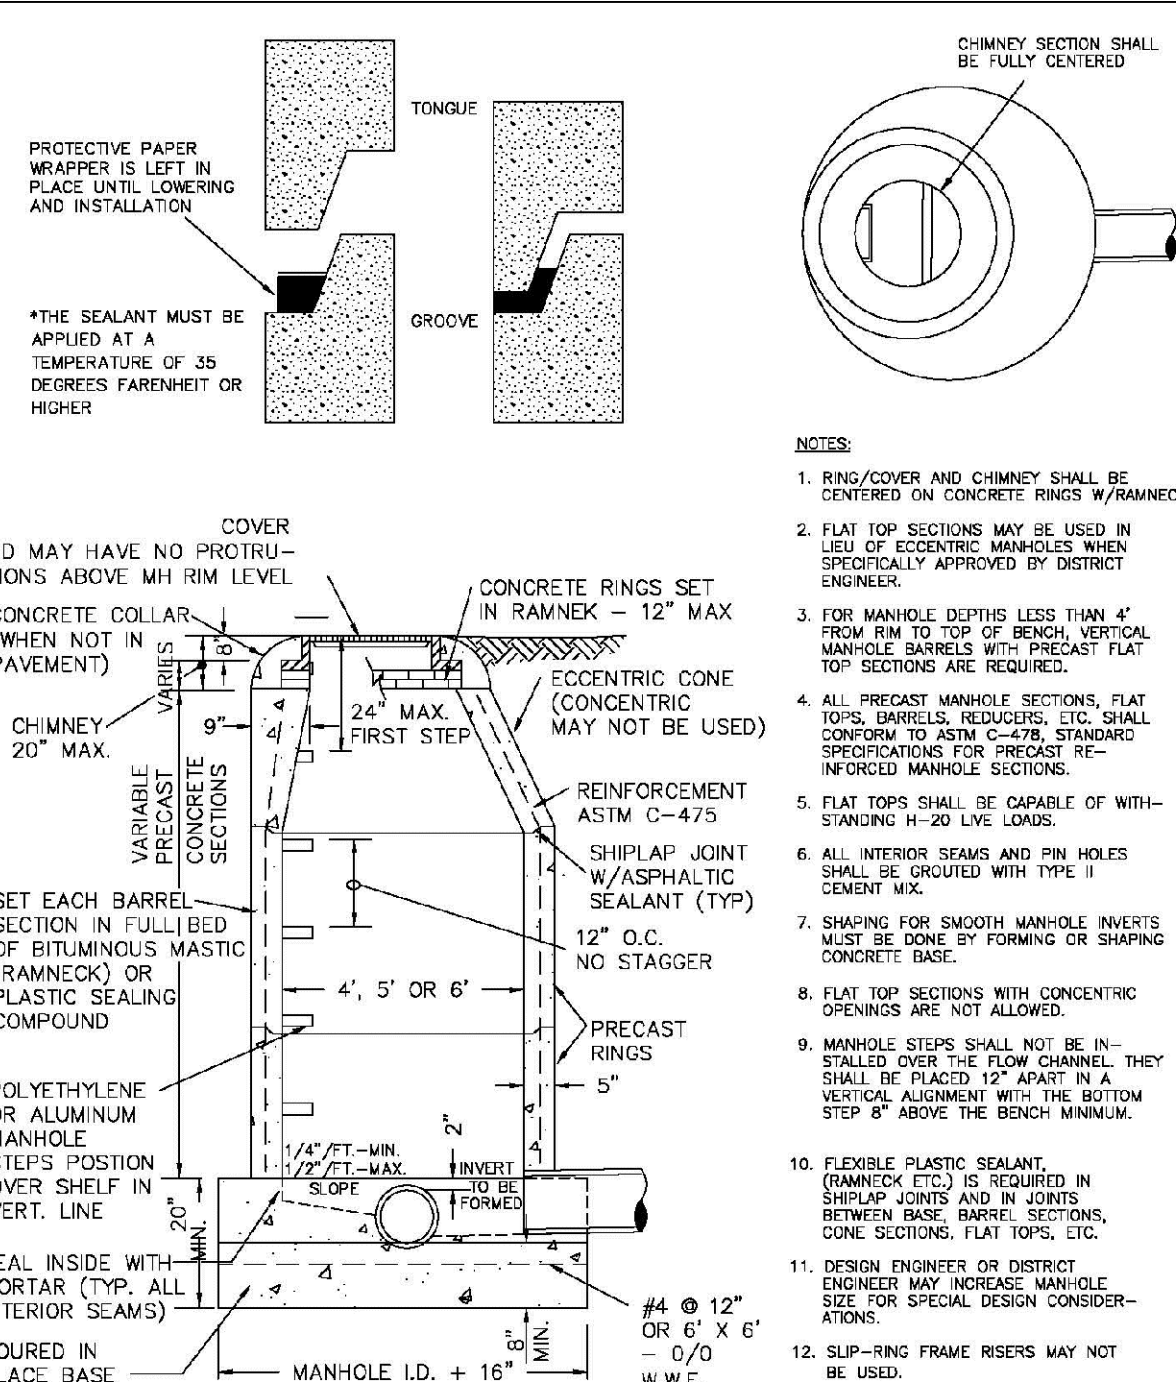

PARKER WATER & SANITATION DISTRICT
PRECAST MANHOLE
ECCENTRIC CONE

SCALE: NONE	DATE: 2/96
APPROVED: PVR	4/01 01/02 1/16 1/18
DIRECTOR OF ENGINEERING	


SHEET S3.1

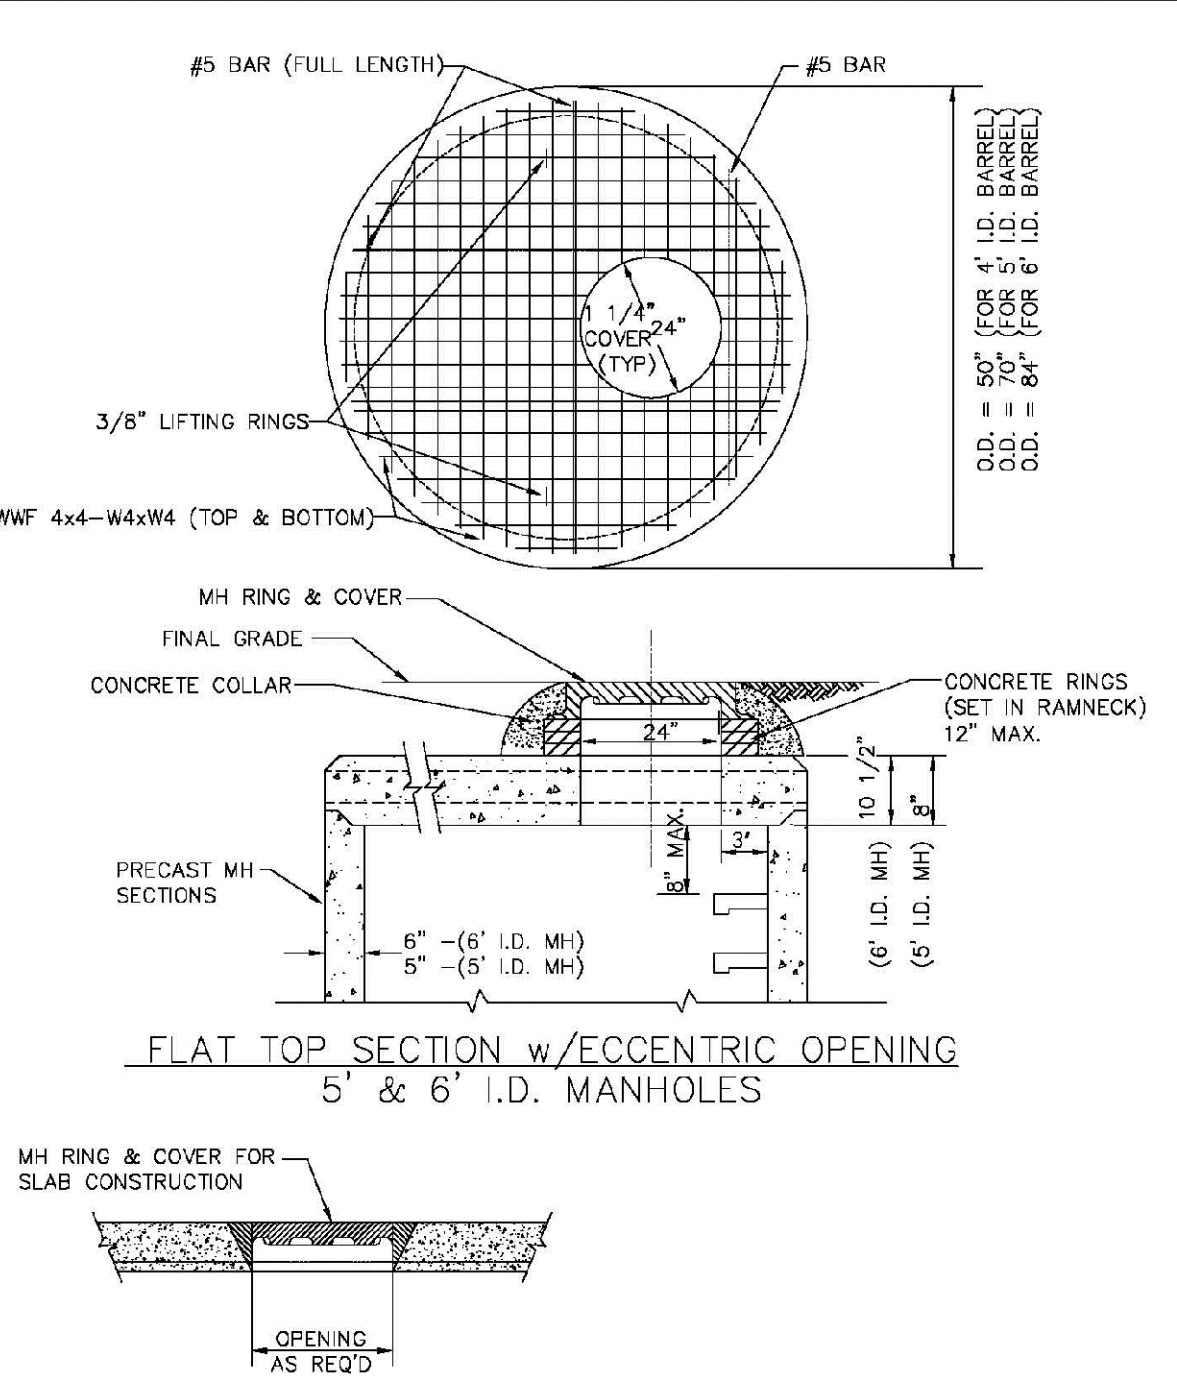

PARKER WATER & SANITATION DISTRICT
PRECAST MANHOLE - 5' & 6' I.D.
WITH ECCENTRIC CONE

SCALE: NONE	DATE: 2/96
APPROVED: PVR	01/02 01/16 10/16
DIRECTOR OF ENGINEERING	


SHEET S3.3

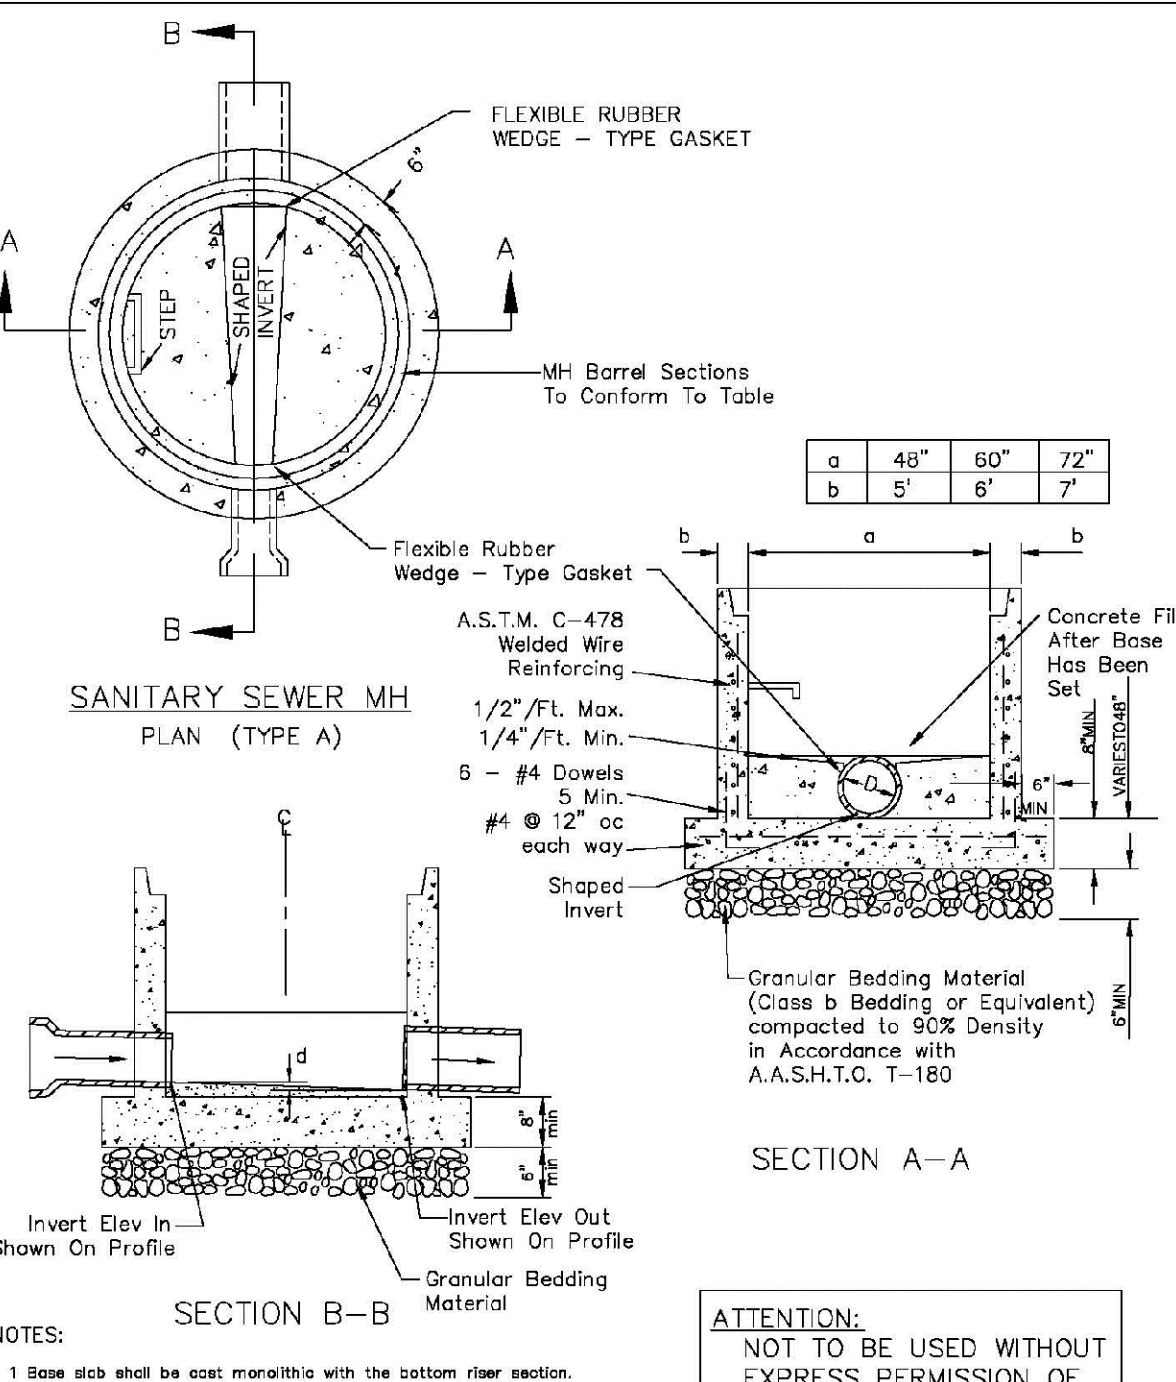

PARKER WATER & SANITATION DISTRICT
PRECAST MANHOLE
BASE DETAIL

SCALE: NONE	DATE: 2/96
APPROVED: PVR	01/02 10/16
DIRECTOR OF ENGINEERING	

SHEET S3.4

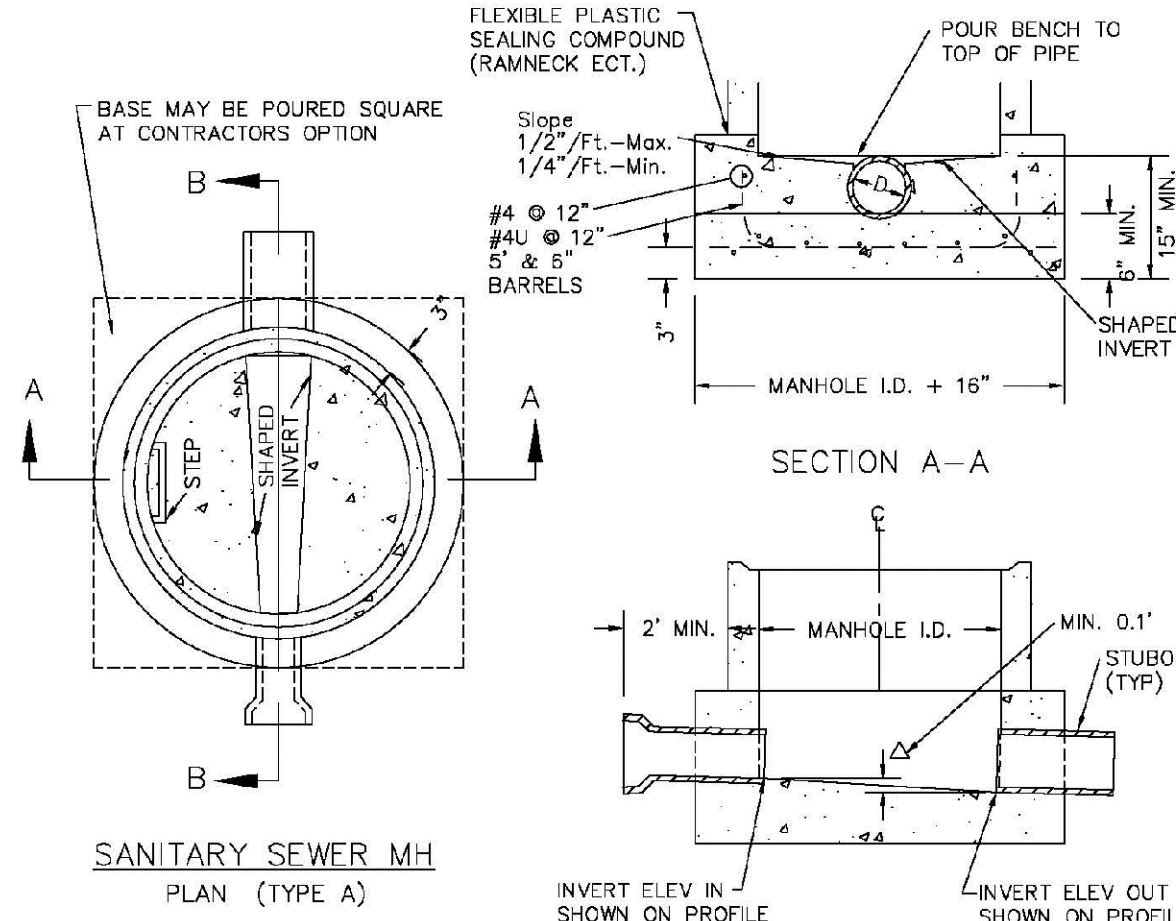


SANITARY SEWER MH
PLAN (TYPE A)

SECTION A-A

- NOTES:
1. Manhole barrel min. thickness to be 5".
 2. Shaping for smooth manhole inverts may be done by forming or shaping with cement mortar (San. Sewer).
 3. The manhole steps shall conform to District Standards and Specifications.
 4. Precast sections to conform to A.S.T.M. C-478.
 5. All dead-end manholes, that call out a stub out, shall be thru at 0.40% minimum slope.
 6. Stub outs shall extend 2'-0" minimum past manhole O.D. and be satisfactorily plugged.
 7. Reinforcing in base required for manhole.
 8. Slope of bench = 1/2" / FT. - Max. 1/4" / FT. - Min.
 9. Δ = Invert drop thru MH (If Δ > 18", outside drop MH required). Min. 0.1" for all straight through MH and 0.2" for all angled MH.

PARKER WATER & SANITATION DISTRICT	
CAST-IN-PLACE MANHOLE BASE DETAIL	
SCALE: NONE	DATE: 2/96
APPROVED: PVR	01/02 01/16 10/16
DIRECTOR OF ENGINEERING	


SHEET S3.5

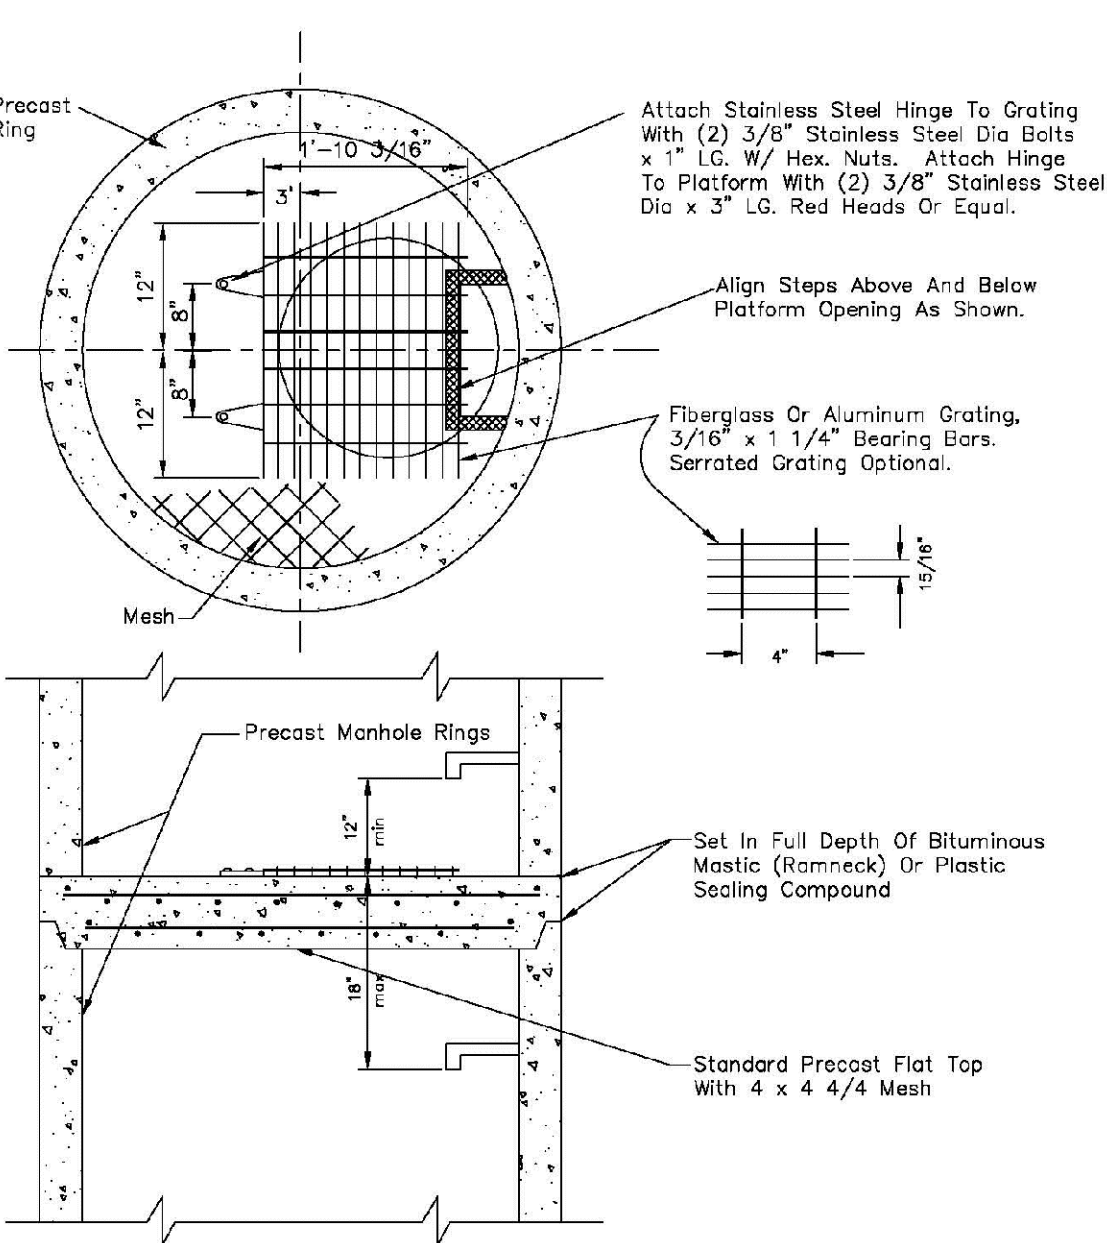

PARKER WATER & SANITATION DISTRICT
INTERMEDIATE PLATFORM FOR
MANHOLES OVER 20' DEPTH

SCALE: NONE	DATE: 2/96
APPROVED: PVR	2/00 01/16 10/16
DIRECTOR OF ENGINEERING	


SHEET S3.6

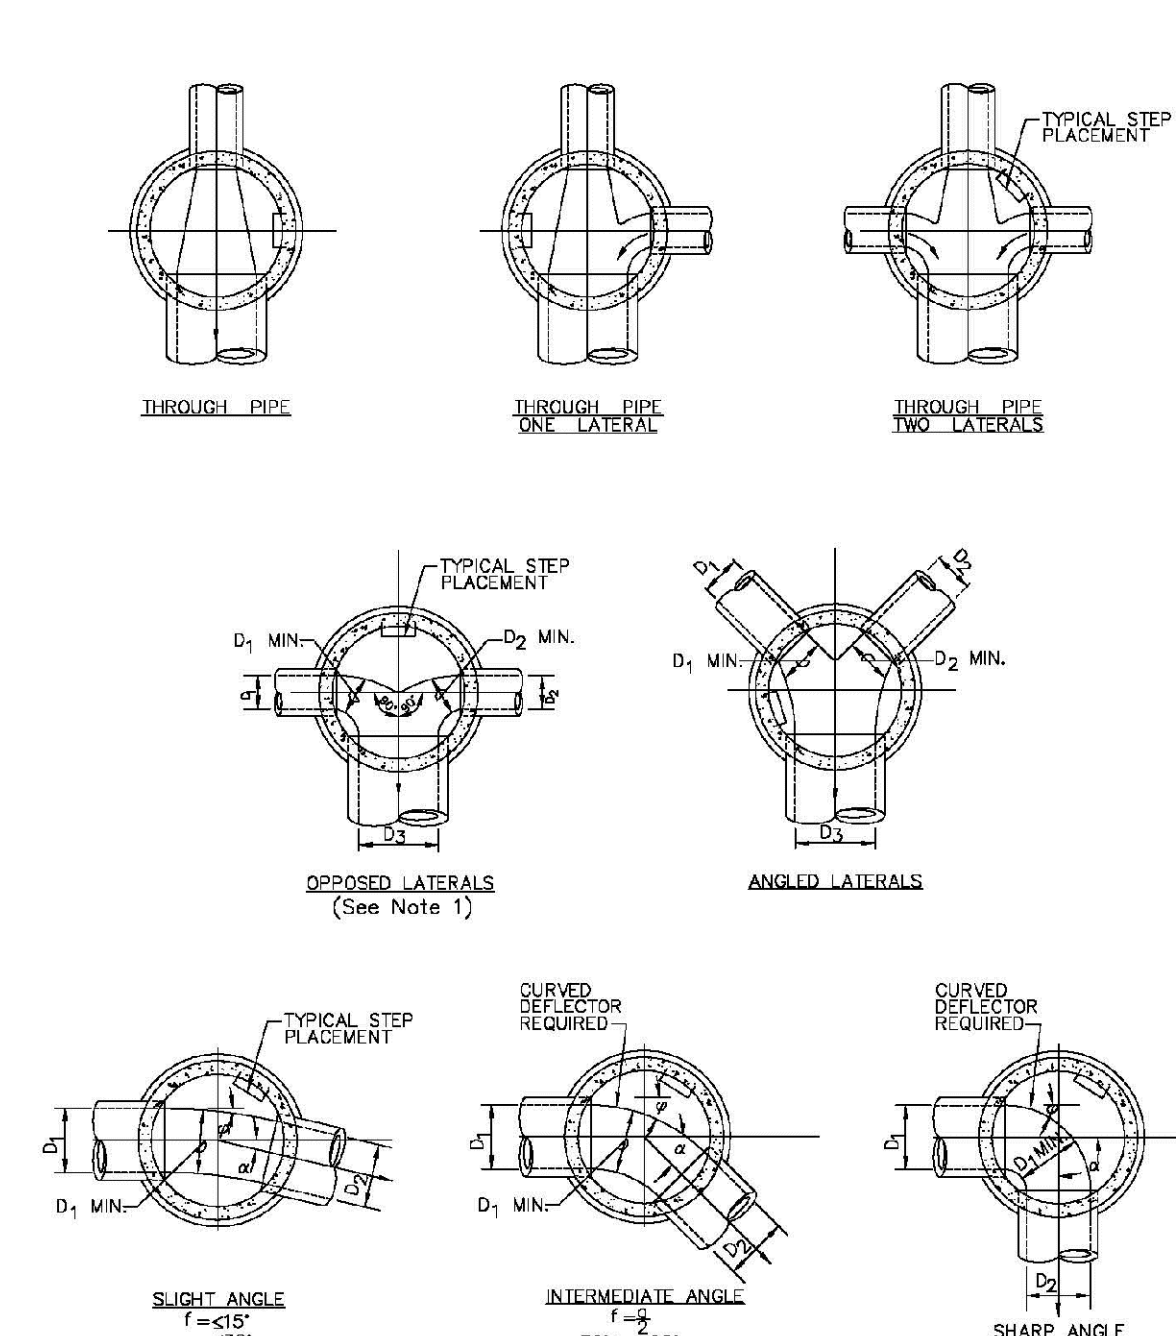

PARKER WATER & SANITATION DISTRICT
TYPICAL BASE
CHANNELIZATION DETAILS

SCALE: NONE	DATE: 2/96
APPROVED: PVR	01/16 10/16
DIRECTOR OF ENGINEERING	

SHEET S3.7

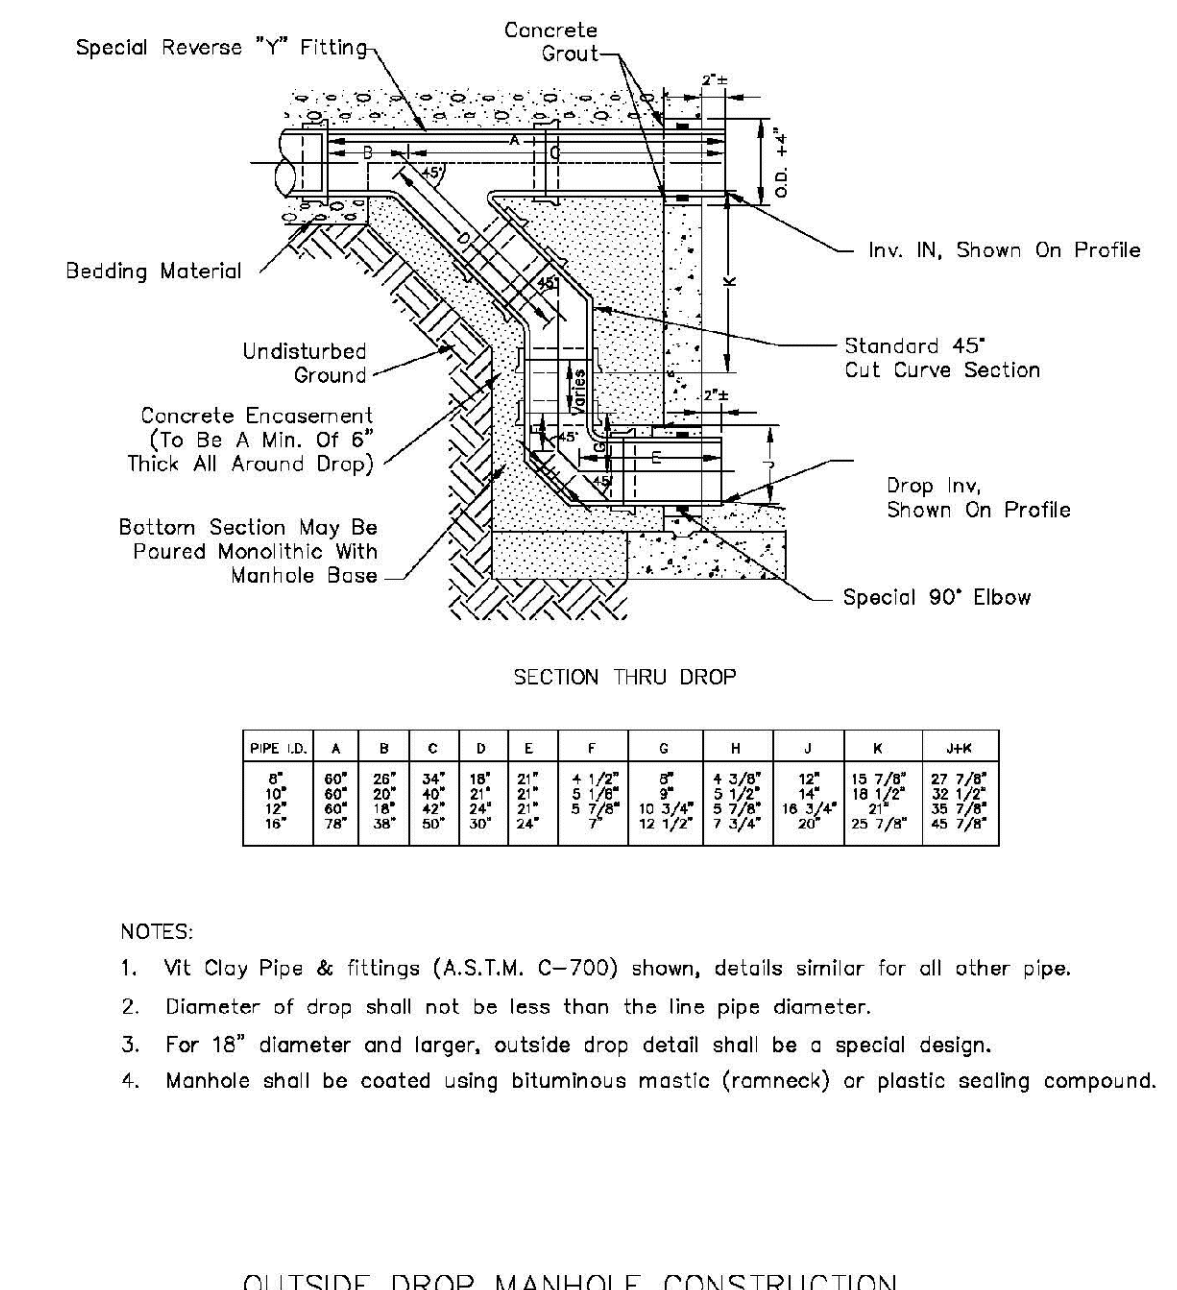


OUTSIDE DROP MANHOLE CONSTRUCTION

PARKER WATER & SANITATION DISTRICT
OUTSIDE DROP MANHOLE
CONSTRUCTION

SCALE: NONE	DATE: 2/96
APPROVED: PVR	01/16 10/16
DIRECTOR OF ENGINEERING	

SHEET S3.8

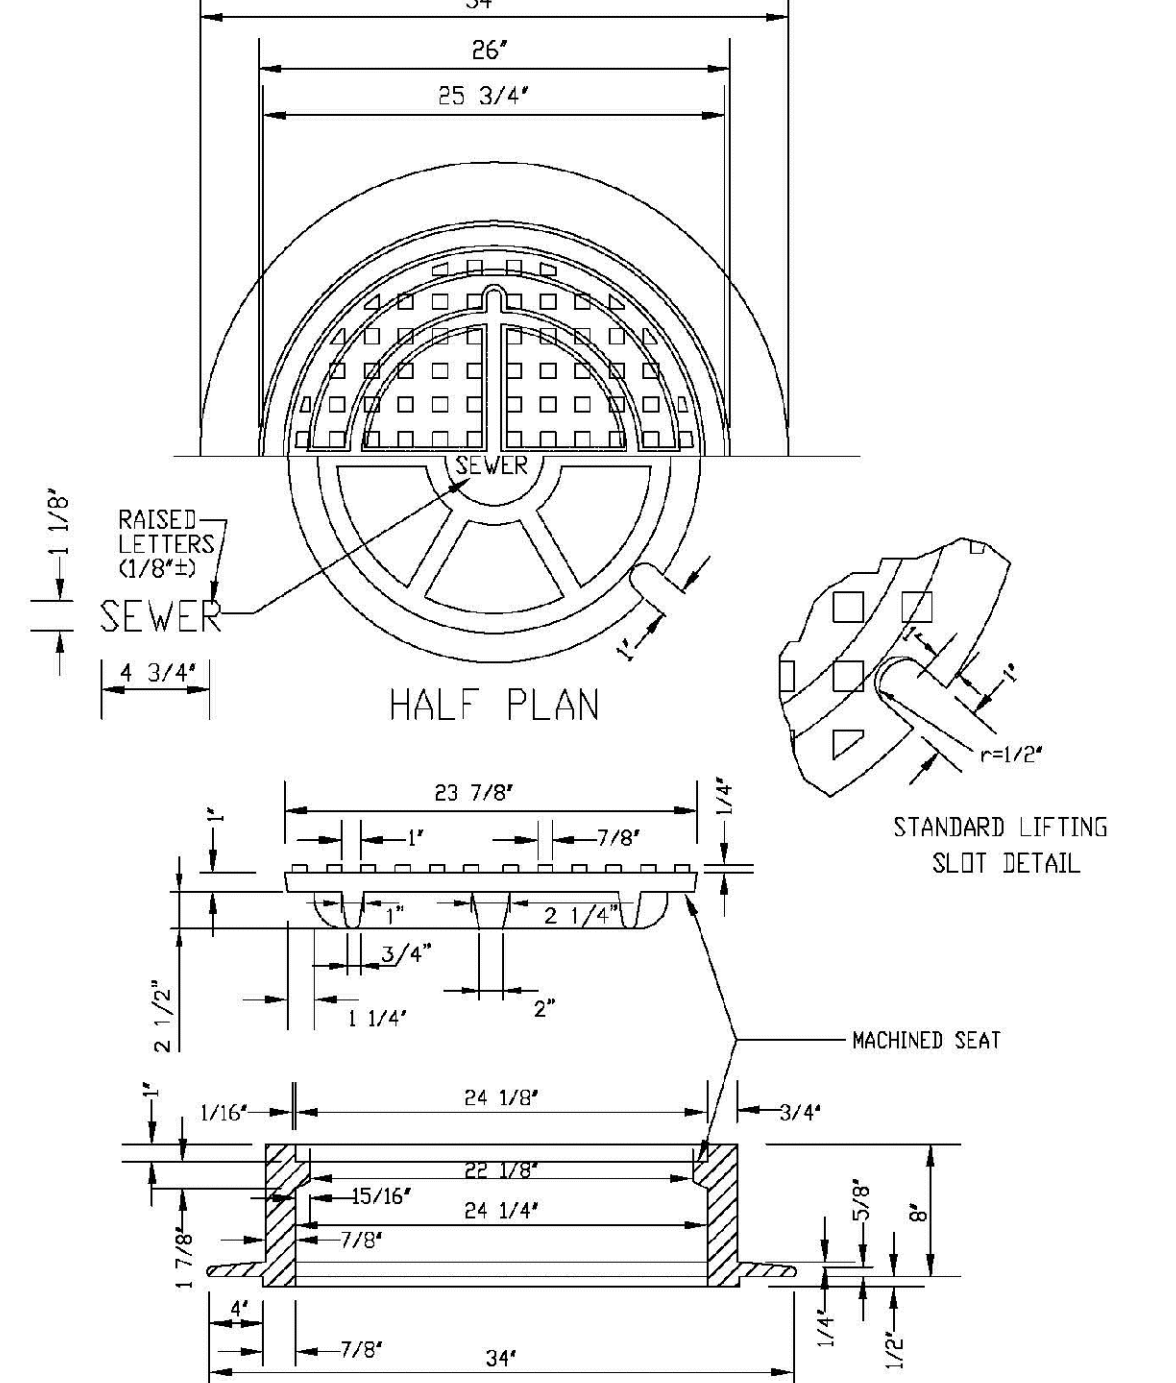

PARKER WATER & SANITATION DISTRICT
24\"/>

SCALE: NONE	DATE: 2/96
APPROVED: PVR	01/16 10/16
DIRECTOR OF ENGINEERING	

SHEET S3.9

SHEET S3.10

SHEET S3.1


SHEET S3.12

SHEET S3.1

SHEET S4.1


	10333 E. Dry Creek Rd.							
	Suite 240							
	Englewood, CO 80112							
	Tel: (720) 462-9526							
	Fax: (720) 462-9546							
No.	Revisions	Date	Init.	Appr.	Date			

SHEET NUMBER 10	DRAWN BY:	UF	SCALE: AS SHOWN	TRAILS AT CROWFOOT FILING 9 CONSTRUCTION DRAWINGS SANITARY SEWER DETAILS	HR 935 LLC 7353 South Alton Way CENTENNIAL, CO 80112	
	CHECKED BY:	JJ				FILE NO:
	DATE:	MAY 2017				8130283701

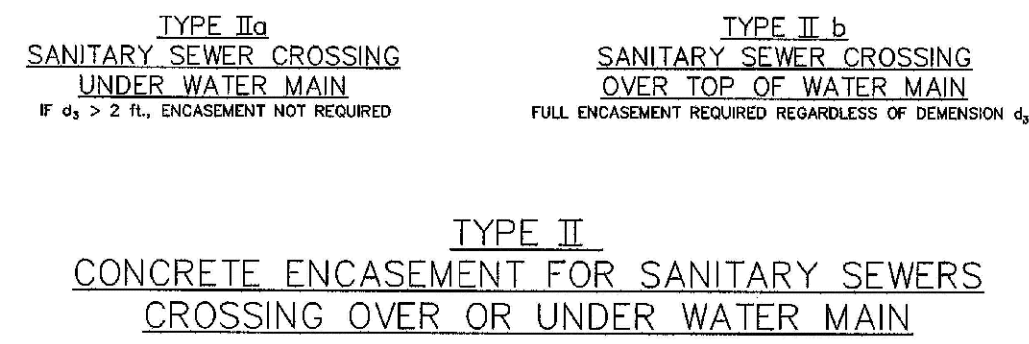

5. WATER MAINS AND GAS $\leq 24"$ ($\leq 4' \leq 18"$)
 - (a) TYPE 1 IS REQUIRED FOR SANITARY SERVICES CROSSING OVER WATER MAINS AND GAS.
 - (b) TYPE 2 IS REQUIRED FOR SANITARY SERVICES CROSSING OVER GAS.
 - (c) EXCEPT FOR UNUSUAL CIRCUMSTANCES, WATER MAIN CROSSINGS OR WHERE UNSTABLE SOIL CONDITIONS ARE ENCOUNTERED, TYPE 2 SHALL BE USED. MINIMUM WALL THICKNESS SHALL BE 12".
 - (d) IF THE SANITARY SERVICE IS REPLACED OR CONSTRUCTED OVER EXISTING WATER MAINS OR GAS (C-15), CONCRETE ENCASEMENT MAY NOT BE REQUIRED.
5. FILTER MATERIAL BETWEEN CONDITS TO BE:
 - (a) APPROVED COMPOSSIBLE MATERIAL, SUCH AS STYROMAX, ETC. $d_2 \leq d_1 \leq 5"$.
 - (b) COMPACTED CLASS "B" BEDDING IF d_1 & $d_2 > 6"$.
 - (c) TYPE 2 FOR RIGID ENCASEMENT PLUS CONCRETE OR UNDISTURBED SOIL.
6. SHORING OR SHEETING, IF USED, TO BE CUT OFF AT TOP OF TRENCH.
7. THESE ENCASEMENT DETAILS MAY ALSO BE APPLICABLE FOR CERTAIN OTHER THAN STORM OR SANITARY SERVICE INSTALLATIONS.
8. IN CERTAIN SITUATIONS WHERE CONDUIT DIAMETER D_1 IS GREATER THAN 36", THE PERMISSIBLE SERVICE INSTALLATIONS MAY ALSO BE REQUIRED. IF REQUIRED, SUPPORTS SHALL BE DESIGNED AND DETAIL SEPARATELY ON PLAN AND PROFILE DRAWINGS.

 2008 REVISION SHEET 7



CONCRETE TO BE CAST AGAINST UNDISTURBED SOIL OR SHORING. EXPOSED SURFACES SHALL BE PROTECTED TO PREVENT CRACKING. REINFORCEMENT IS POURED SEPARATELY, AND A HIGH LAYER OF SAND OR MORTAR SHALL BE PLACED BETWEEN REINFORCEMENT LAYERS TO PREVENT CRACKING.

2. LENGTH OF REINFORCEMENT FOR:

- (a) TYPE I OR II REINFORCEMENT SHALL EXTEND FULL LENGTH WITHIN EXCAVATED FOR PROPOSED SEWER AND OUT TO 10 FEET EACH SIDE OF WATER MAIN.
- (b) TYPE III REINFORCEMENT NOTED ON PLAN/PROFILE DRAWINGS: TYPE I & II REINFORCEMENTS NEED NOT BE REINFORCED. REINFORCEMENT IF REQUIRED, SHALL BE PLACED IN ACCORDANCE WITH THE REINFORCEMENT DRAWING.
- (c) TYPE I, II, OR III REINFORCEMENTS ARE REQUIRED UNDER FOLLOWING CONDITIONS:
 - TYPE I: TYPE III IF $d \leq 16"$ OR $d \geq 120"$ EXCEPT FOR SANITARY SEWER CROSSING OVER TOP OF WATER MAIN.
 - TYPE II: TYPE III FOR SPANS EXCEEDING 10 FEET AND FOR WATER MAINS WITH MAINS AND $d \leq 24"$ OR $d \leq 16"$.
 - TYPE III: TYPE III FOR SPANS EXCEEDING 10 FEET AND FOR WATER MAINS CROSSING OVER TOP OF WATER MAINS, REGARDLESS OF DIMENSION d .

3. REINFORCEMENT SHALL BE PLACED IN ACCORDANCE WITH THE REINFORCEMENT DRAWING, OR WHERE UNFAVORABLE SOIL CONDITIONS ARE ENCOUNTERED, TYPE I OR II REINFORCEMENT SHALL BE USED.

(d) REINFORCEMENT SHALL BE PLACED ON TOP OF CONSTRUCTED OF DUCTILE IRON PIPE (AWWA C-150 OR C-151), CONCRETE

2016 REVISION SHEET S4.8




2016 REVISION SHEET S4.9



2016 REVISION SHEET S4.10



2016 REVISION SHEET S4.12

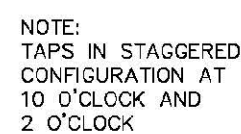

DOMESTIC SEWER TAPPING DETAIL

2016 REVISION SHEET S4.13




- 2016 REVISION SHEET S4.14

N:\PROJECTS\SSR\BANCROFT\ENGINEERING\SSR\BANCROFT\WATER AND SANITATION\WATER PLAN AND PROFILE\9 SCARLET SAGE AVENUE WATER.DWG, BRAWW, 2/26/2018 6:27 PM




CALL 811
TWO WORKING DAYS
BEFORE YOU DIG
UNCC 1-800-922-1987

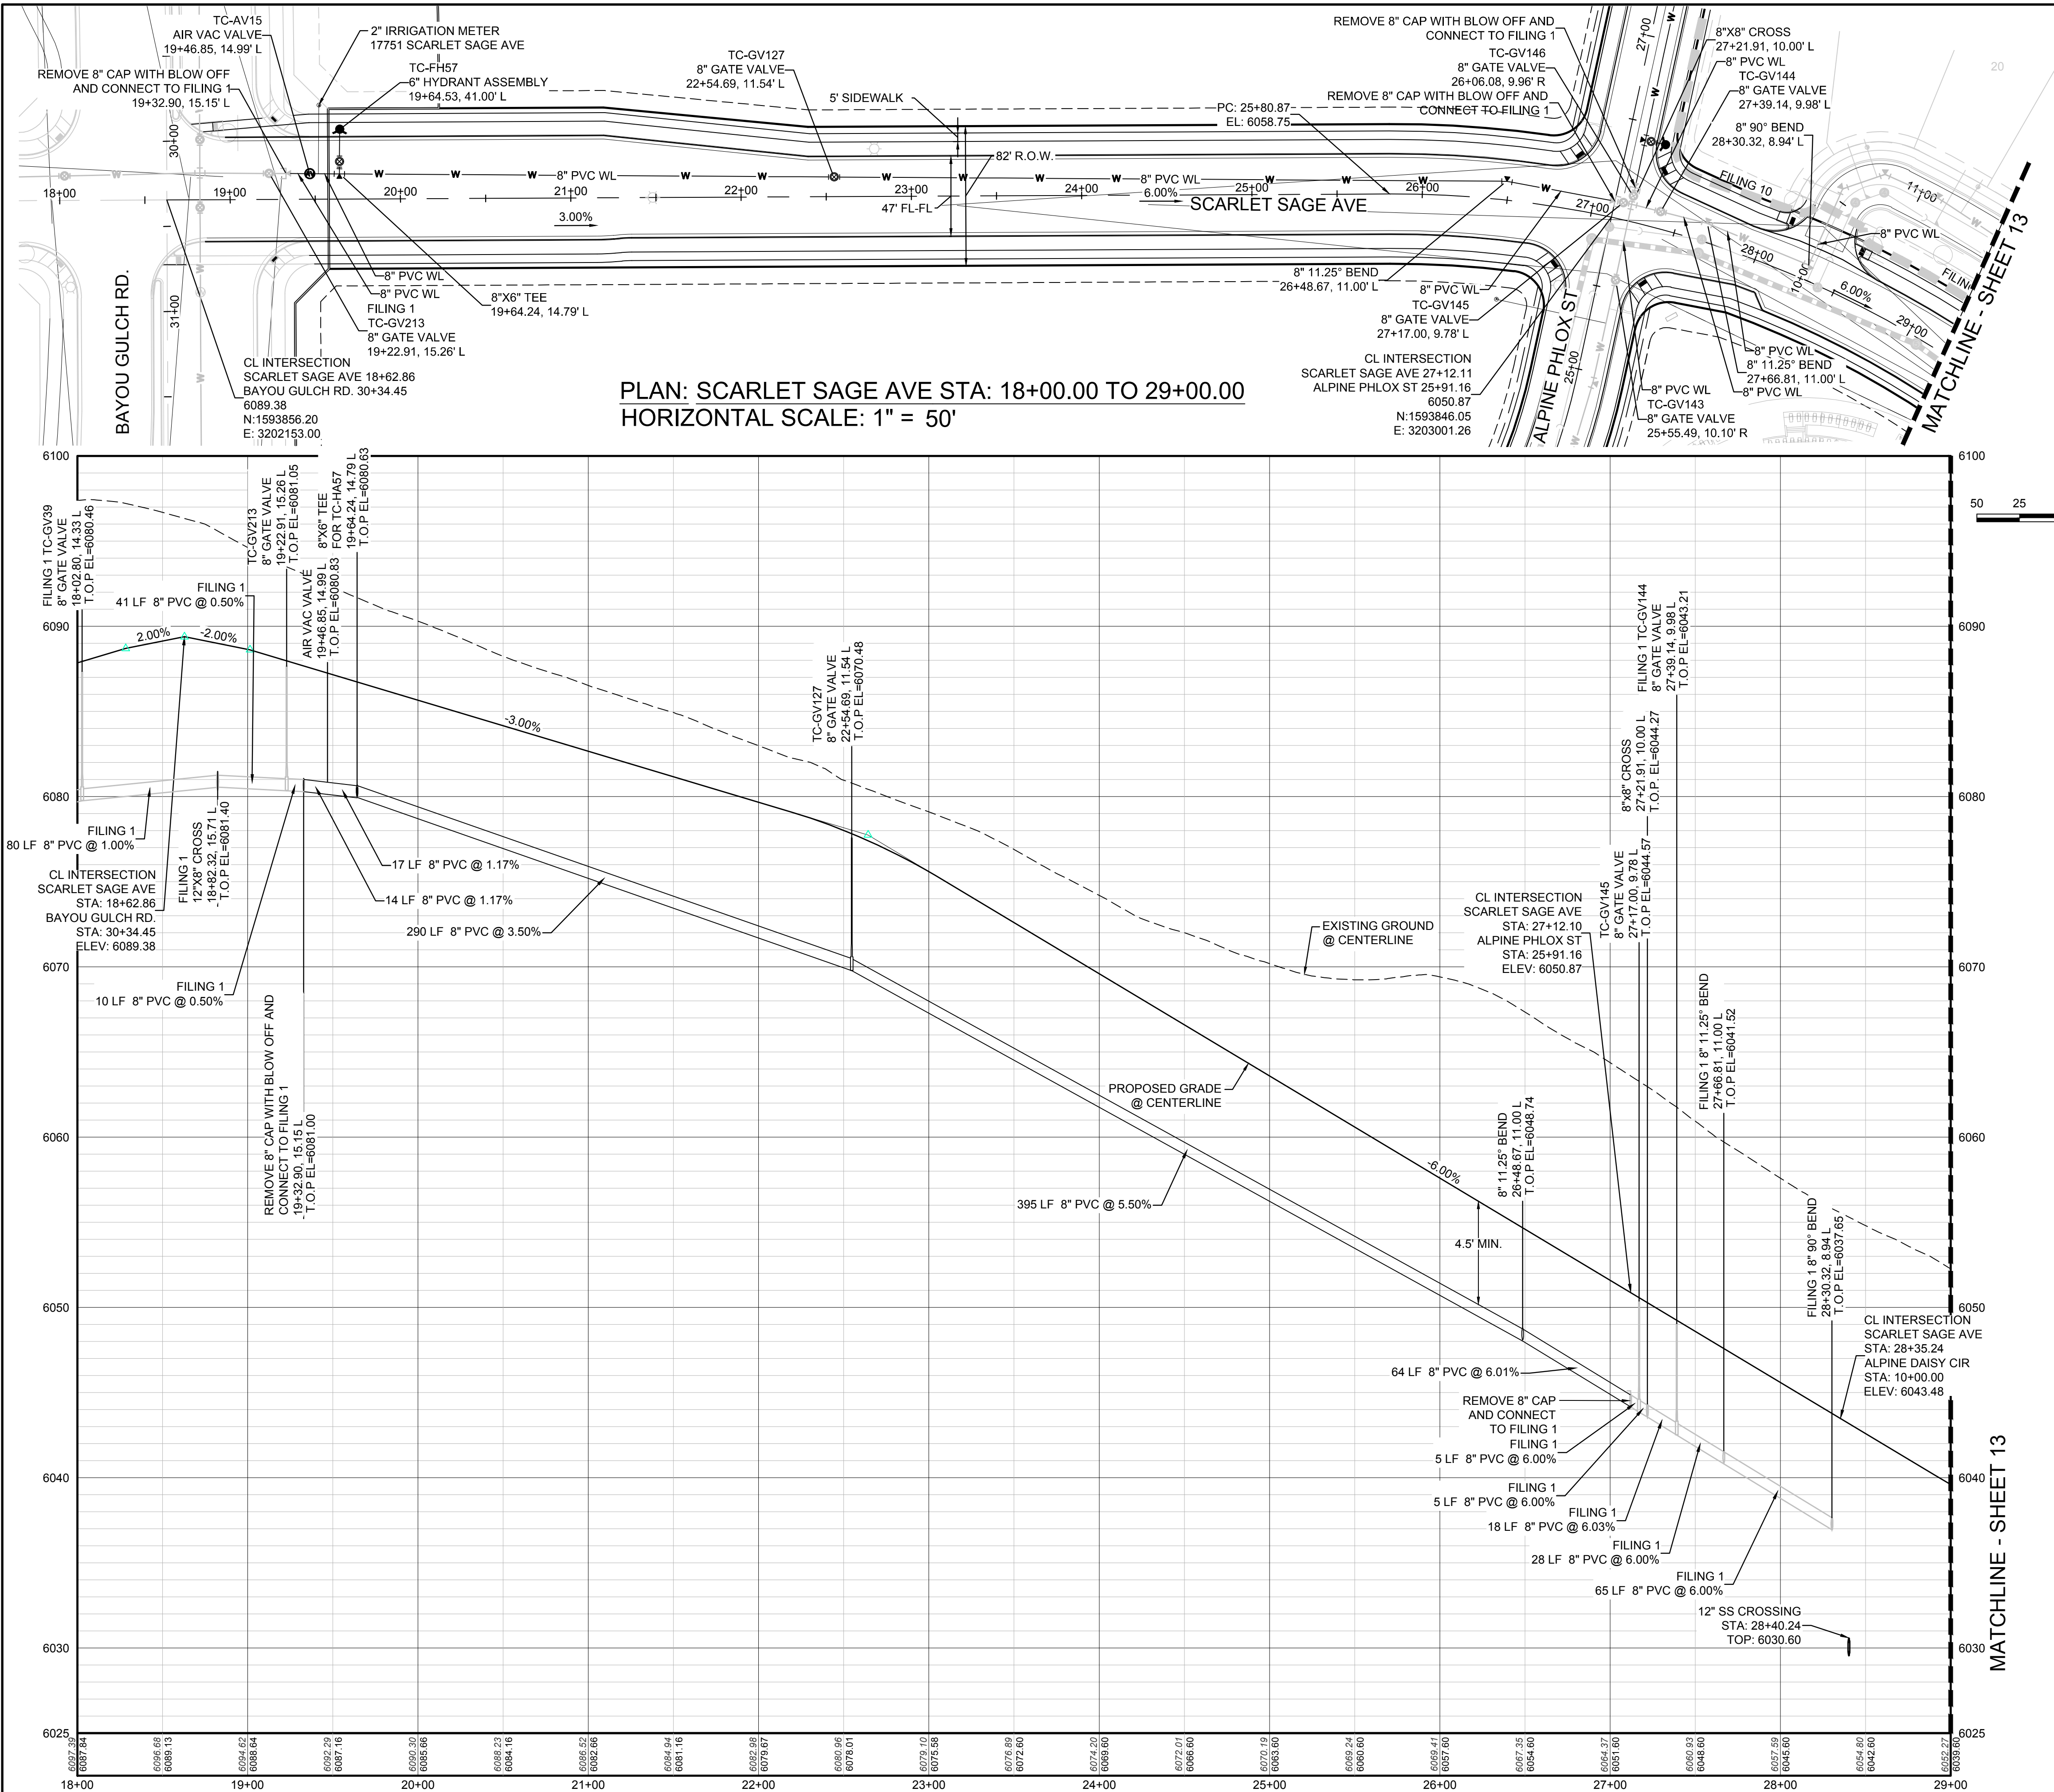

PREPARED UNDER THE
SUPERVISION OF

BRIAN P. WILSON
COLORADO P.E. 0050067

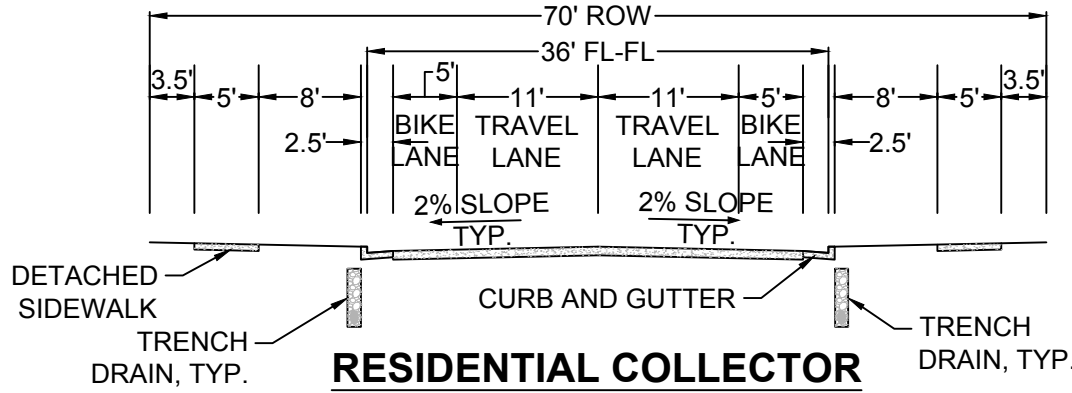

2

6

PROPOSED BUTTERFLY VALVE

PROPOSED CAP WITH END OF LINE BLOW OFF

PROPOSED REDUCER

PROPOSED VALVE

PROPOSED FIRE HYDRANT

PROPOSED WL FITTING WITH THRUST BLOCK END SECTION

PROPOSED LOW POINT BLOW-OFF

PROPOSED AIR VALVE

FUTURE PHASE VALVE

FUTURE FIRE HYDRANT

PROPOSED LIGHT POLE

PROPOSED SIDEWALK

PROPOSED SIDEWALK RAMP

10.00

10.00

PROPOSED STORM DRAIN INLET

PROPOSED STORM DRAIN MANHOLE

PROPOSED RANGE POINT

CENTERLINE

RIGHT-OF-WAY

PROPERTY LINE

EDGE OF PAVEMENT

PROPOSED DIRECTION OF FLOW

PROPOSED SLOPE & DIRECTION

EXISTING 5' CONTOUR

EXISTING 1' CONTOUR

PROPOSED 5' CONTOUR

PROPOSED 1' CONTOUR

PROPOSED STORM DRAIN

PROPOSED SEWER LINE WITH MANHOLE

PROPOSED SEWER LATERAL

PROPOSED WATER LINE

PROPOSED WATER LATERAL W/ METER

SECTION LINE

FILING BOUNDARY

EXISTING FIBER OPTIC LINE

EXISTING OVERHEAD POWER

EXISTING TELEPHONE LINE

AD

AV

BVC

BVP

CBO

CRR

EL

EP

EVC

EVP

FG

FL

GV

HCR

HP

INV

K

LF

MH

N.T.S.

PVC

PVI

PVT

RCBC

RCPC

ROW

SC

SD

SL

SS

STA

T.O.P.

UE

VC

WL

WLC

WSE

MANHOLE

NOT TO SCALE

POLYVINYL CHLORIDE

PT OF VERTICAL INTERSECTION

POINT OF VERTICAL TANGENT

REINFORCED CONCRETE BOX CULVERT

REINFORCED CONCRETE PIPE

RIGHT OF WAY

SANITARY CAP

STORM DRAIN

SECTION LINE

SANITARY SEWER

TOP OF PIPE

UTILITY EASEMENT

VERTICAL CURVE

WATER LINE

WATER LINE CONNECTION


WATER SURFACE ELEVATION

ABBREVIATIONS			
AD	ANGLE DIFFERENCE	MH	MANHOLE
AV	AIR VAC RELEASE VALVE	N.T.S.	NOT TO SCALE
BVC	BEGIN VERTICAL CURVE	PVC	POLYVINYL CHLORIDE
BVP	BEGIN VERTICAL PROFILE	PVI	PT. OF VERTICAL INTERSECTION
CBO	CAP WITH BLOW OFF	PVT	POINT OF VERTICAL TANGENT
CRR	CURB RETURN RADIUS	RCBC	REINFORCED CONCRETE BOX CULVERT
EL	ELEVATION	RCPC	REINFORCED CONCRETE PIPE
EP	EDGE OF PAVEMENT	ROW	RIGHT OF WAY
EVC	END VERTICAL CURVE	SC	SANITARY CAP
EVP	END VERTICAL PROFILE	SD	STORM DRAIN
FG	FINISHED GROUND	SL	SECTION LINE
FH	FIRE HYDRANT	SS	SANITARY SEWER
FL	FLOW LINE	STA	STATION
GV	GATE VALVE	T.O.P.	TOP OF PIPE
HCR	HANDICAP CURB RAMP	UE	UTILITY EASEMENT
HP	HIGH POINT	VC	VERTICAL CURVE
INV	INVERT	WL	WATER LINE
K	CURVATURE COEFFICIENT	WLC	WATER LINE CONNECTION
LF	LINEAR FEET	WSE	WATER SURFACE ELEVATION

KEYMAP

N.T.S.

LEGEND

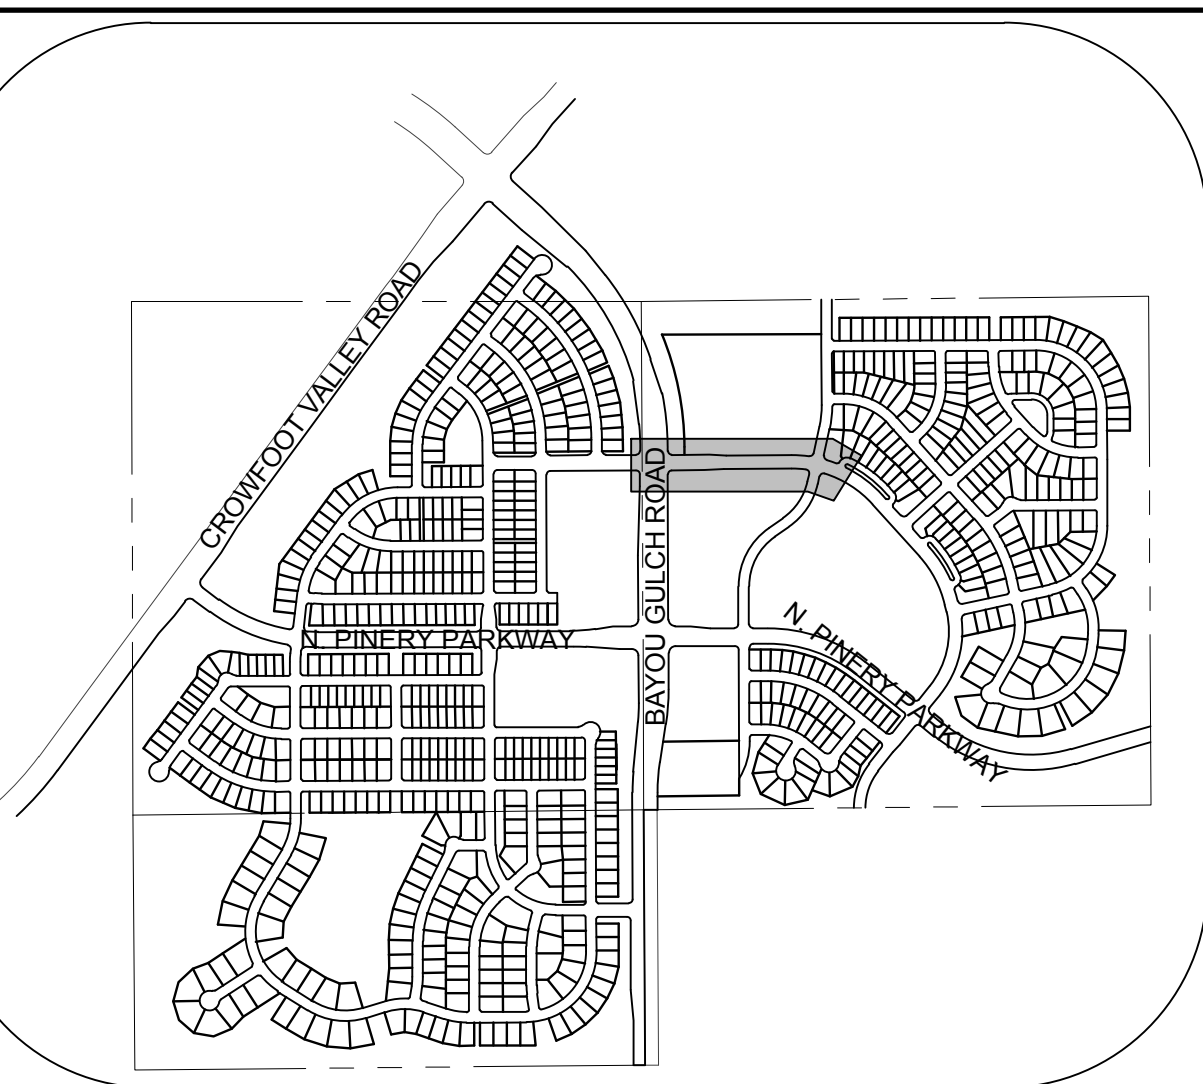

PROFILE: SCARLET SAGE AVE STA: 18+00.00 TO 29+00.00
HORIZONTAL: 1" = 50'
VERTICAL: 1" = 5'

BENCHMARK
A DOUGLAS COUNTY CONTROL POINT KNOWN AS 1.060032, BEING A 3-1/4" ALUMINUM CAP, BEING LOCATED IN THE SOUTHWEST QUARTER OF SECTION 33, TOWNSHIP 6 SOUTH, RANGE 66 WEST OF THE SIXTH PRINCIPAL MERIDIAN, HAVING A PUBLISHED ELEVATION OF 1799.2870 METERS (5903.13 FEET) NAVD '88 DATUM.

BASIS OF BEARINGS:
THE EAST LINE OF THE NORTHEAST QUARTER OF SAID SECTION 9 BEING MONUMENTED AT THE NORTHEAST CORNER OF SAID SECTION 9 BY A 3-1/4" ALUMINUM CAP STAMPED LS 23053 AND AT THE EAST QUARTER CORNER OF SAID SECTION 9 BY A 2-1/2" ALUMINUM CAP STAMPED LS 6935 BEING CONSIDERED TO BEAR SOUTH 00°15'06" EAST, 2648.70 FEET.

10333 E. Dry Creek Rd.
Englewood, CO 80141
Tel: (720) 482-9526
Fax: (720) 482-9546



HR 935 LLC
7353 South Alton Way
CENTENNIAL, CO 80112

SCALE:
AS SHOWN

FILE NO:
8130283701

DRAWN BY:
RHR

CHECKED BY:
JLJ

DATE:
MAY 2017

TRAITS AT CROWFOOT
FILING 9 CONSTRUCTION DRAWINGS
WATER PLAN & PROFILE
SCARLET SAGE AVENUE

SHEET NUMBER
12

No.

Revisions


Init.

Date


Appr.

Date


N:\PROJECTS\SSR\BANCHADO\ENGINEERING\SSR\SET\CD\SSR\WATER AND SANITATION\WATER PLAN AND PROFILE\9 SCARLET SAGE AVENUE WATER.DWG, B19A.W, 2/26/2018 6:27 PM

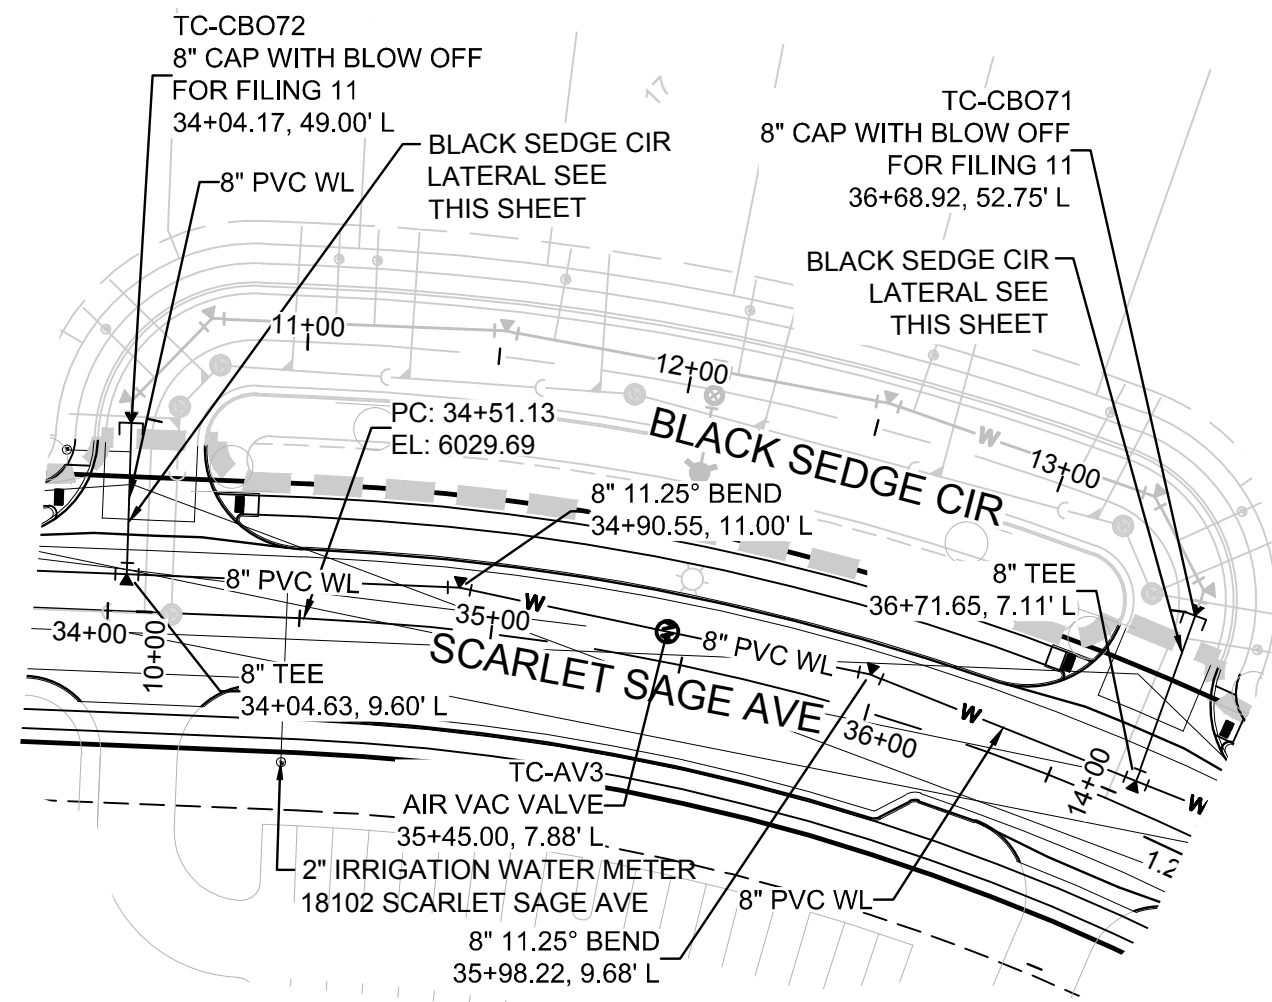


PLAN: BLACK SEDGE CIR STA: 10+00.00 TO 14+00.00
HORIZONTAL SCALE: 1" = 50'

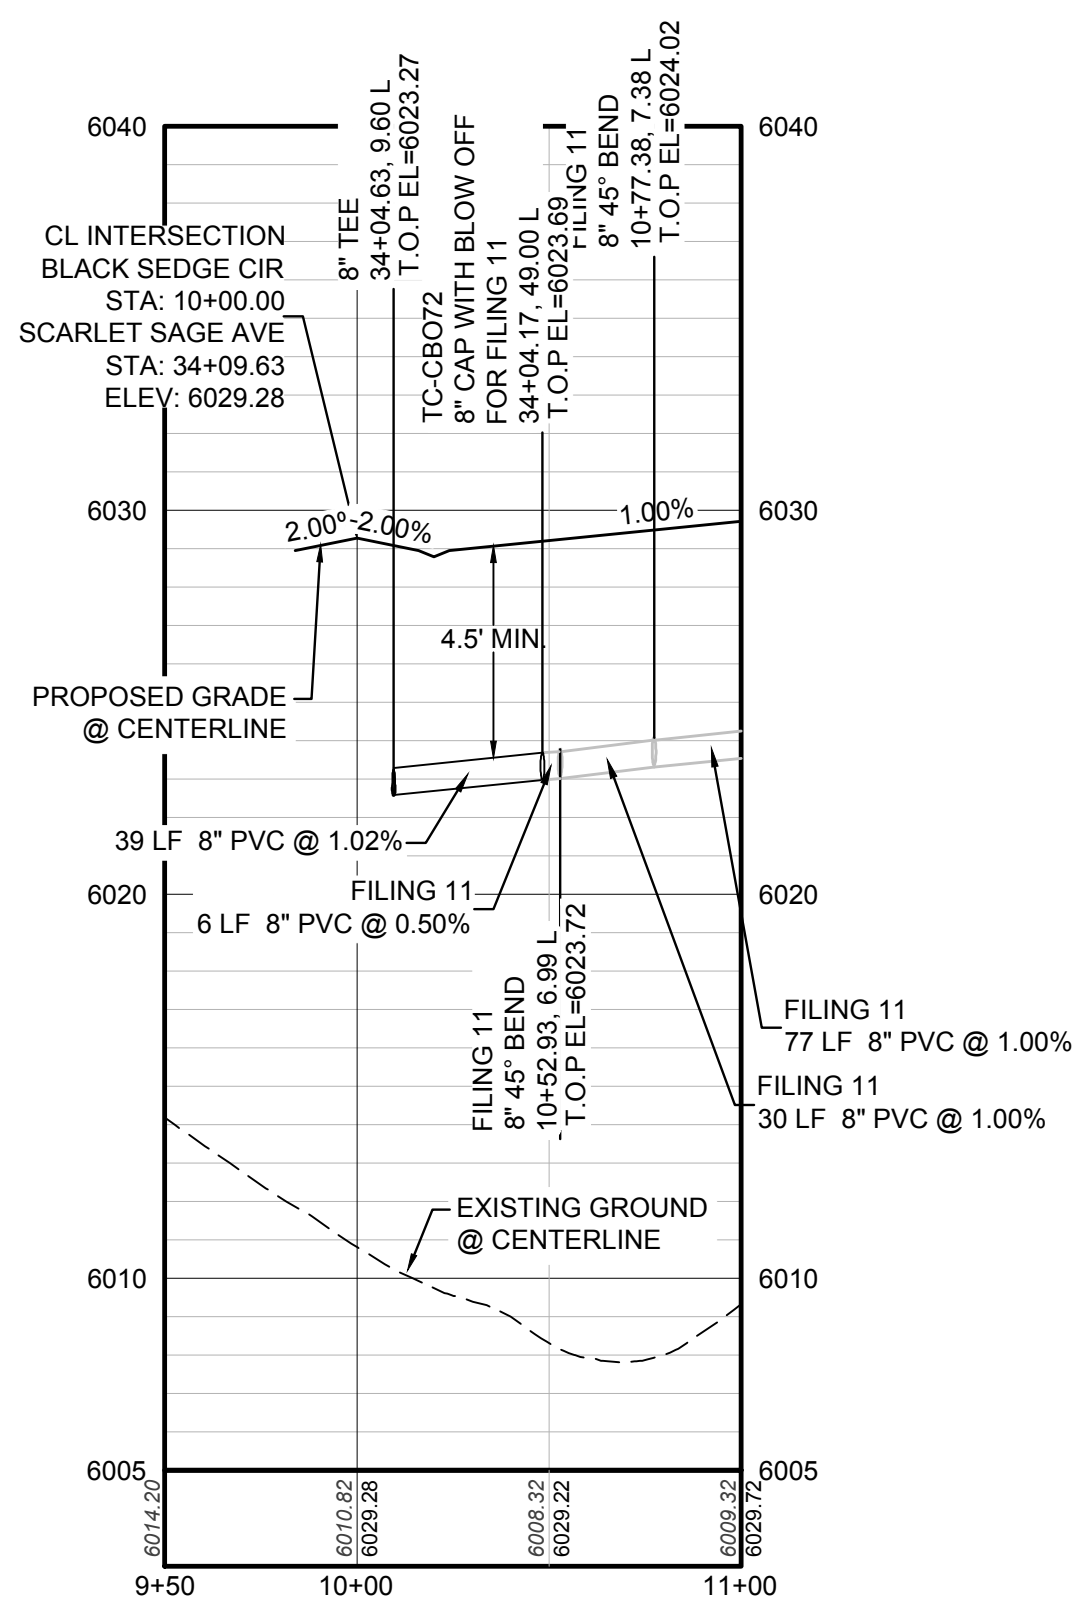


PROFILE: BLACK SEDGE CIR STA: 9+50.00 TO 11+00.00
HORIZONTAL: 1" = 50'
VERTICAL: 1" = 5'

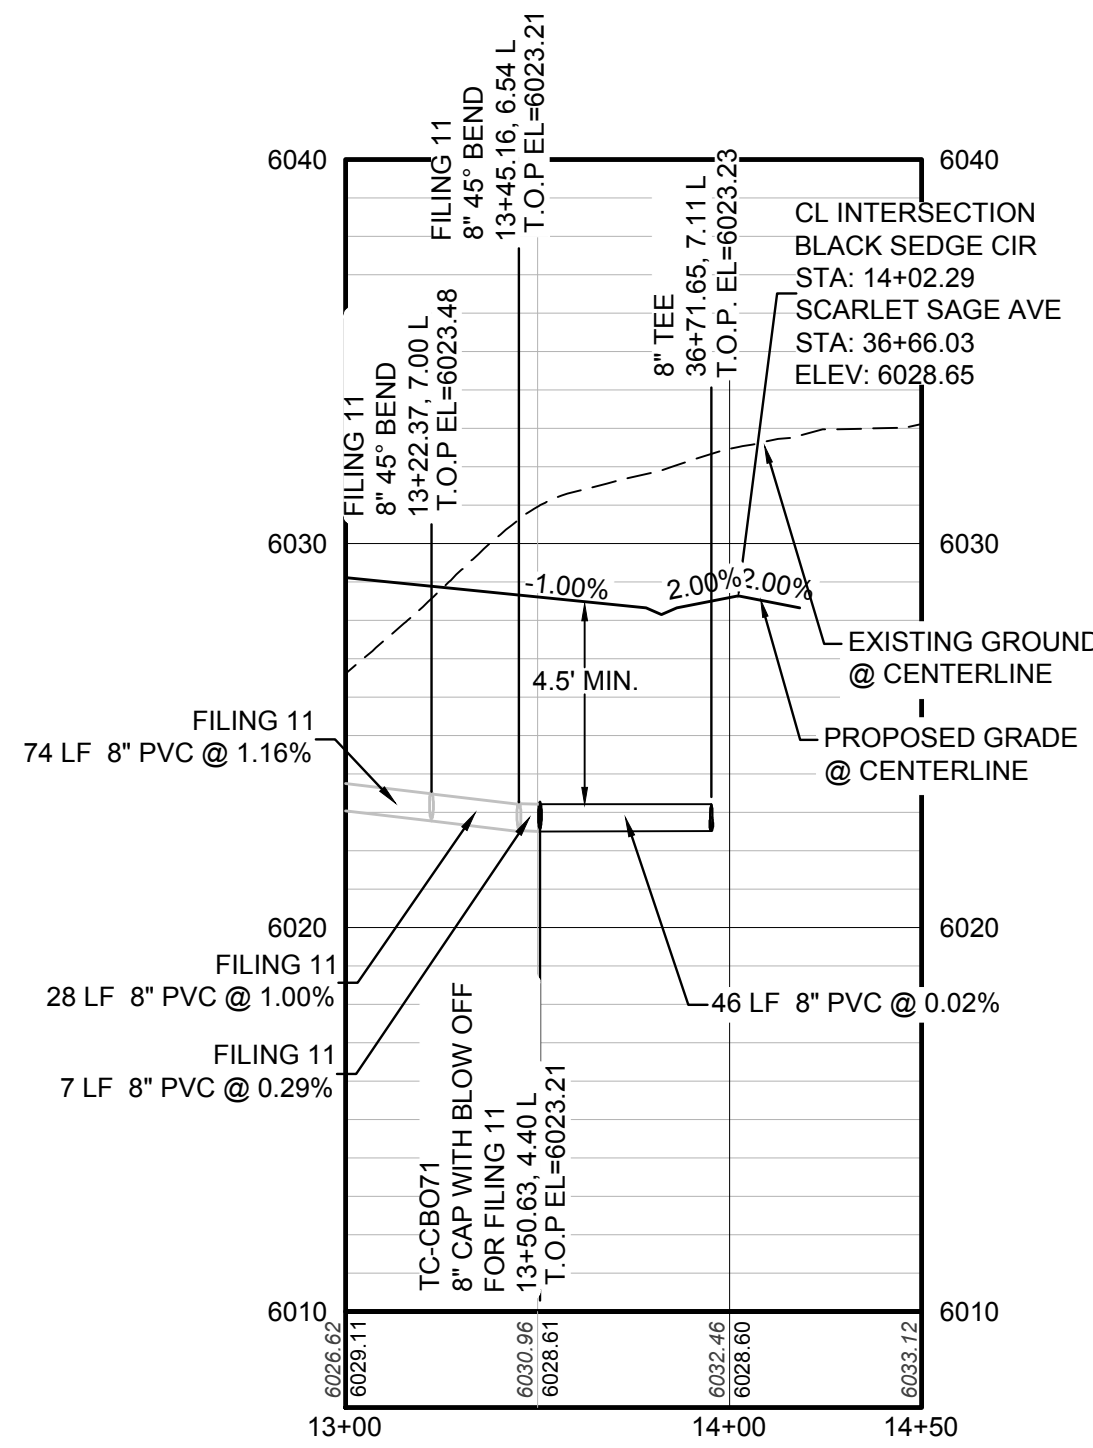


PROFILE: BLACK SEDGE CIR STA: 13+00.00 TO 14+50.00
HORIZONTAL: 1" = 50'
VERTICAL: 1" = 5'

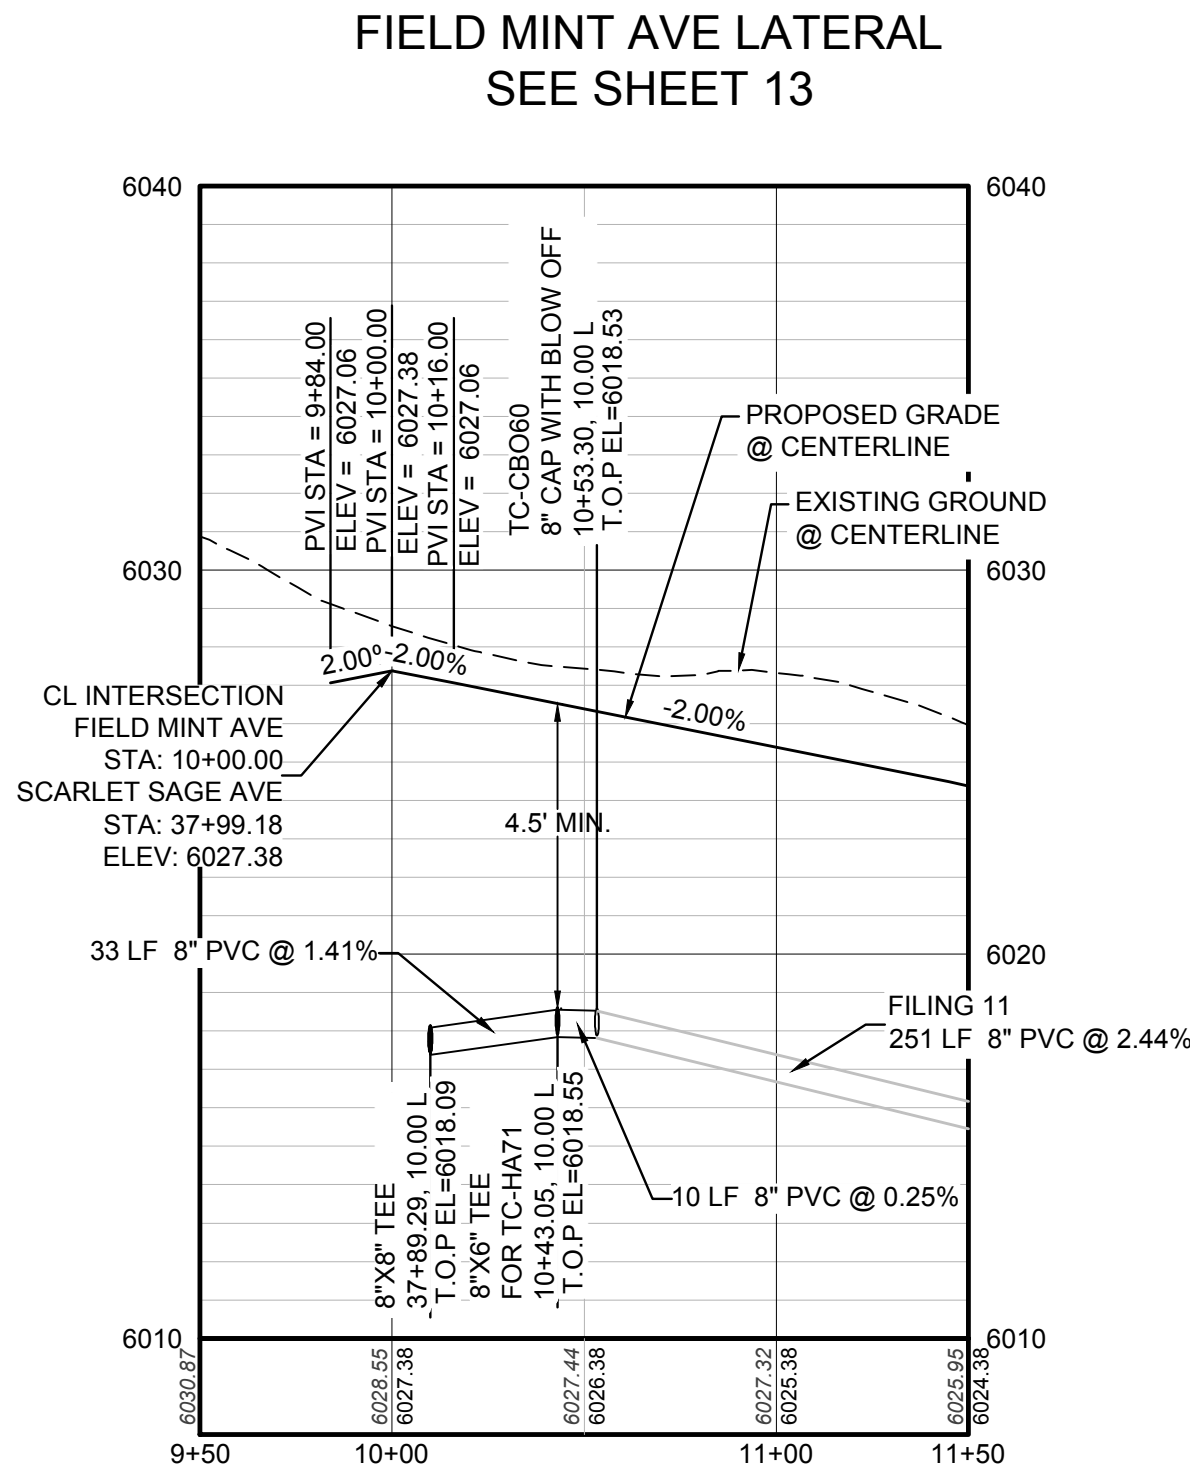

PROFILE: FIELD MINT AVE STA: 9+50.00 TO 11+50.00
HORIZONTAL: 1" = 50'
VERTICAL: 1" = 5'

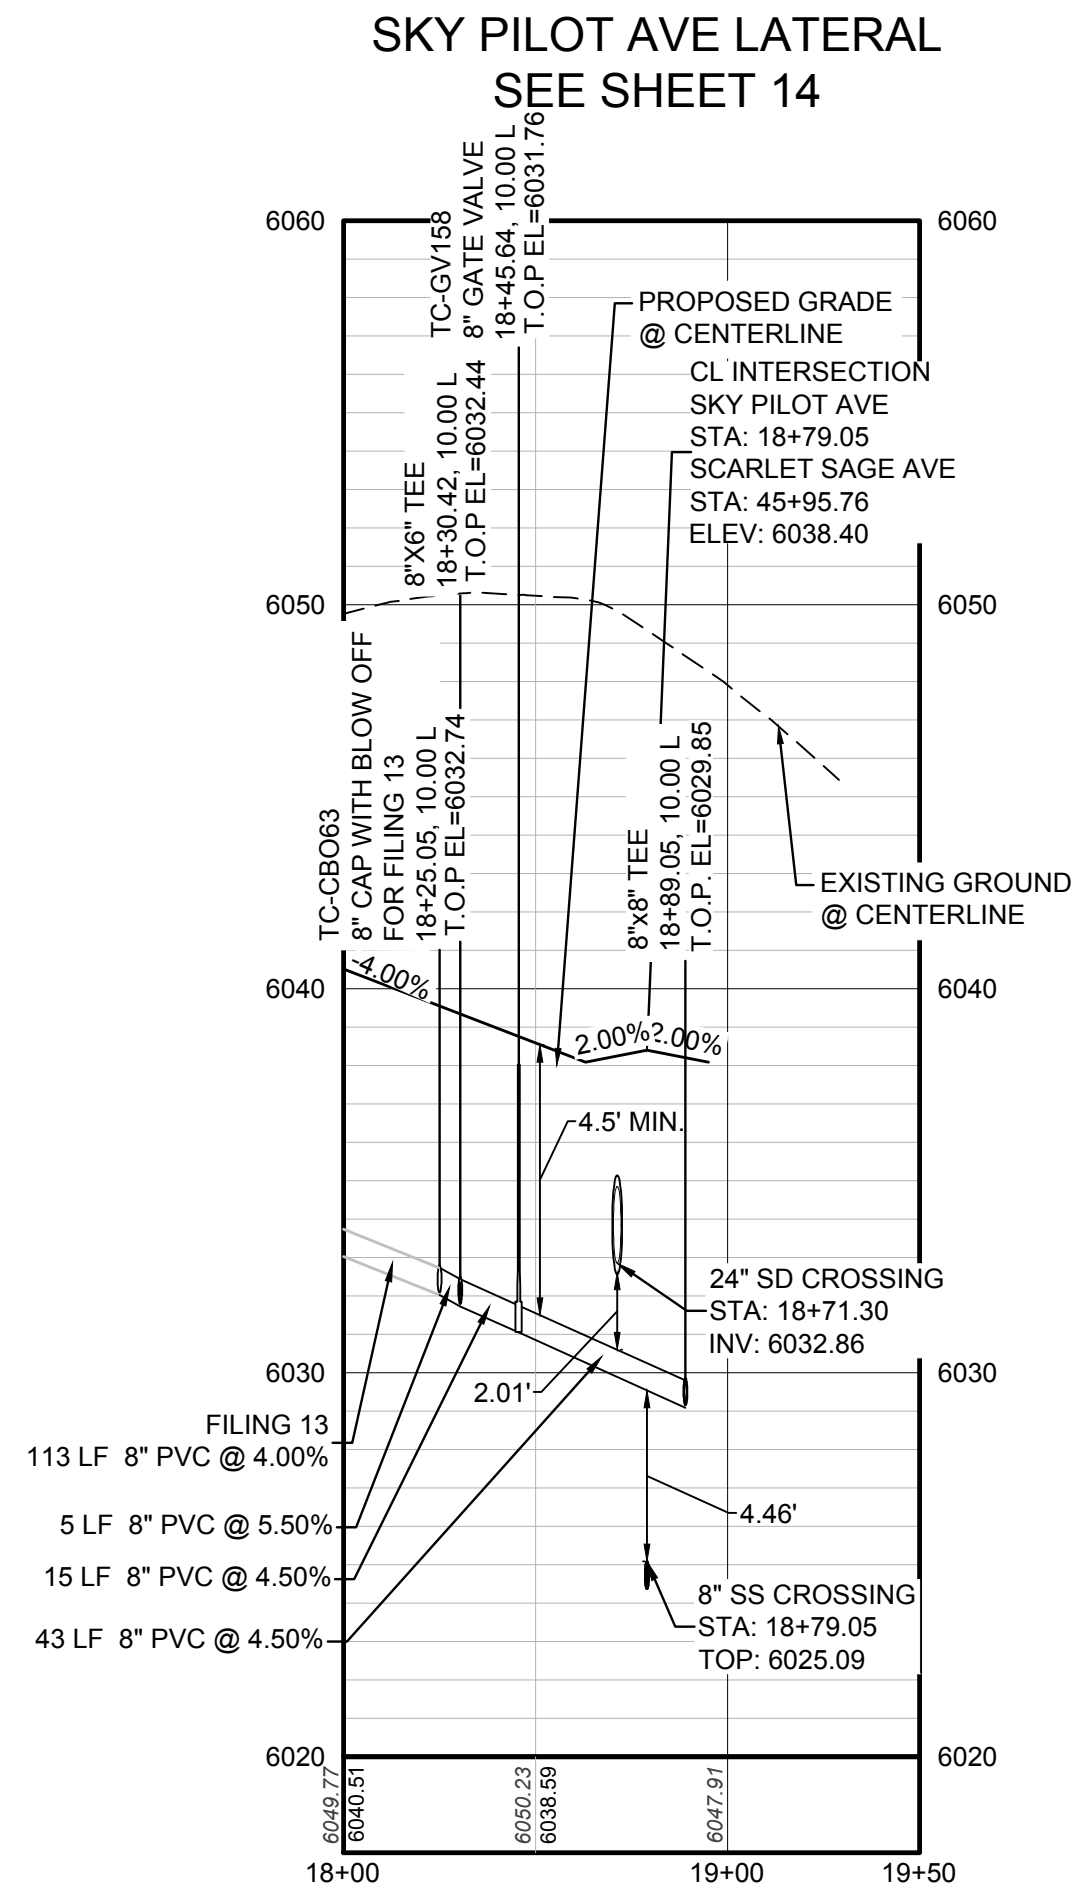

PROFILE: SKY PILOT AVE STA: 18+00.00 TO 19+50.00
HORIZONTAL: 1" = 50'
VERTICAL: 1" = 5'

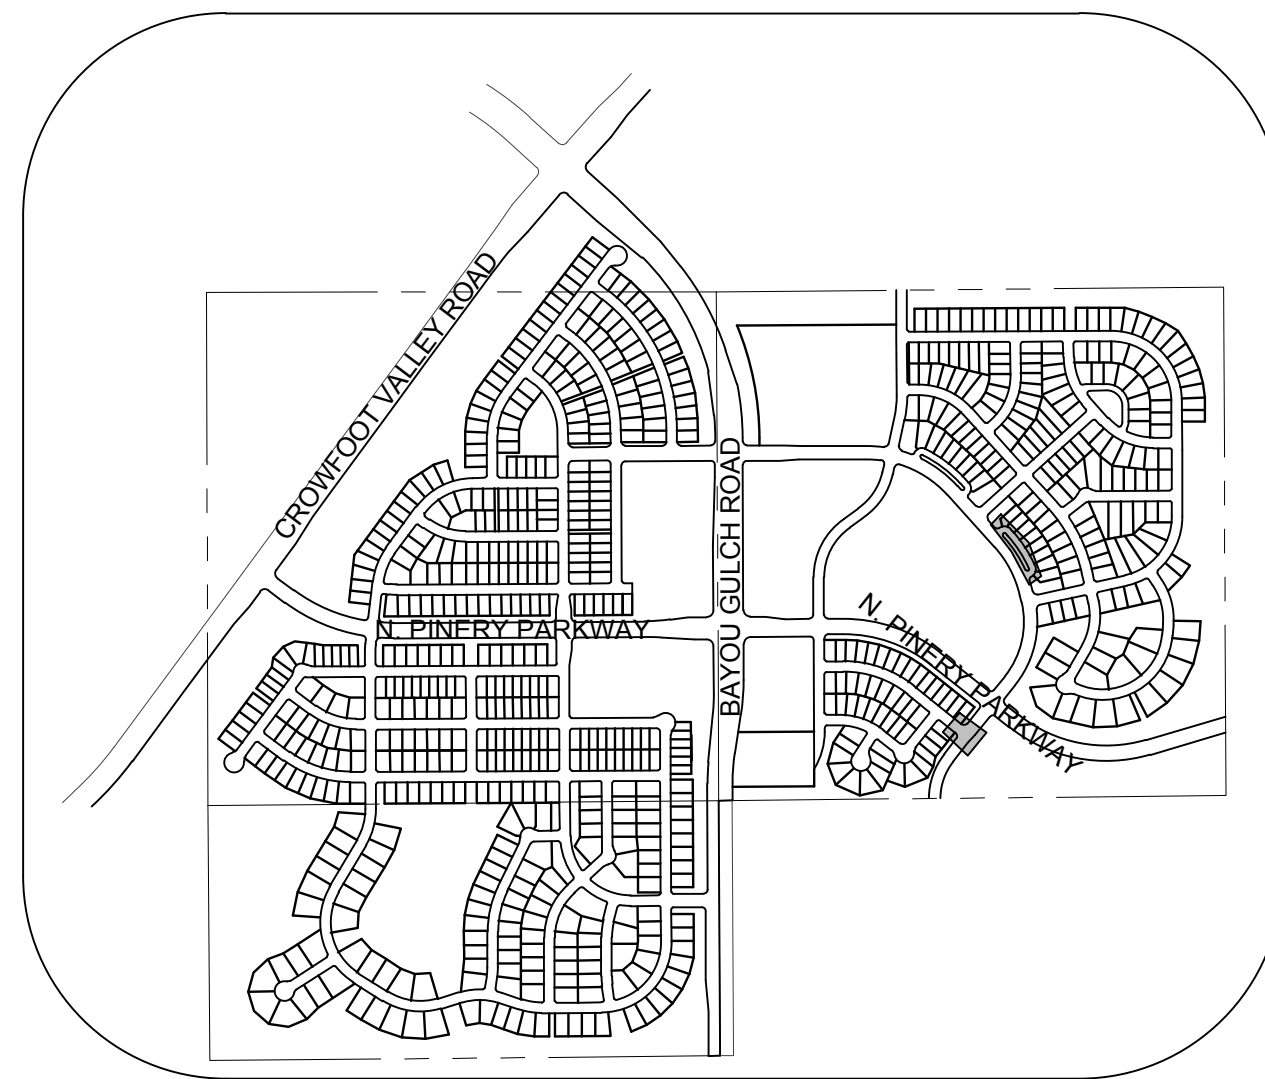

KEYMAP
N.T.S.

LEGEND

②	BLOCK NUMBER	△	PROPOSED RANGE POINT
Ⓐ	LOT TYPE	---	CENTERLINE
6	LOT NUMBER	---	RIGHT-OF-WAY
⊕	PROPOSED BUTTERFLY VALVE	---	PROPERTY LINE
⌋	PROPOSED CAP WITH END OF LINE BLOWOFF	---	EDGE OF PAVEMENT
⌋	PROPOSED REDUCER	→	PROPOSED DIRECTION OF FLOW
⊕	PROPOSED VALVE	1.0%	PROPOSED SLOPE & DIRECTION
⊕	PROPOSED FIRE HYDRANT	---	EXISTING 5' CONTOUR
⊕	PROPOSED WL FITTING WITH THRUST BLOCK	---	EXISTING 1' CONTOUR
⊕	PROPOSED FLARED END SECTION	---	PROPOSED 5' CONTOUR
⊕	PROPOSED LOW POINT BLOW-OFF	---	PROPOSED 1' CONTOUR
⊕	PROPOSED AIR VALVE	---	PROPOSED STORM DRAIN
⊕	FUTURE PHASE VALVE	---	PROPOSED SEWER LINE WITH MANHOLE
⊕	FUTURE FIRE HYDRANT	---	PROPOSED SEWER LATERAL
⊕	PROPOSED LIGHT POLE	---	PROPOSED WATER LINE
⊕	PROPOSED SIDEWALK	---	PROPOSED WATER LATERAL W/ METER
⊕	PROPOSED SIDEWALK RAMP	---	SECTION LINE
10.00	EXISTING ELEVATION	---	FILING BOUNDARY
10.00	PROPOSED DESIGN ELEVATION	---	EXISTING FIBER
⊕	PROPOSED STORM DRAIN INLET	---	EXISTING OVERHEAD POWER
⊕	PROPOSED STORM DRAIN MANHOLE	---	EXISTING TELEPHONE LINE

ABBREVIATIONS

AD	ANGLE DIFFERENCE	MH	MANHOLE
AV	AIR VAC RELEASE VALVE	N.T.S.	NOT TO SCALE
BVC	BEGIN VERTICAL CURVE	PVC	POLYVINYL CHLORIDE
BVP	BEGIN VERTICAL PROFILE	PVI	PT. OF VERTICAL INTERSECTION
CBO	CAP WITH BLOW OFF	PVT	POINT OF VERTICAL TANGENT
CRR	CURB RETURN RADIUS	RCBC	REINFORCED CONCRETE BOX CULVERT
EL	ELEVATION	RCP	REINFORCED CONCRETE PIPE
EP	EDGE OF PAVEMENT	ROW	RIGHT OF WAY
EVC	END VERTICAL CURVE	SC	SANITARY CAP
EVP	END VERTICAL PROFILE	SD	STORM DRAIN
FG	FINISHED GROUND	SL	SECTION LINE
FH	FIRE HYDRANT	SS	SANITARY SEWER
FL	FLOW LINE	STA	STATION
GV	GATE VALVE	T.O.P.	TOP OF PIPE
HCR	HANDICAP CURB RAMP	UE	UTILITY EASEMENT
HP	HIGH POINT	VC	VERTICAL CURVE
INV	INVERT	WL	WATER LINE
K	CURVATURE COEFFICIENT	WLC	WATER LINE CONNECTION
LF	LINEAR FEET	WSE	WATER SURFACE ELEVATION


BENCHMARK
DOUGLAS COUNTY CONTROL POINT KNOWN AS 1.060032, BEING A 3-1/4" ALUMINUM CAP, BEING LOCATED IN THE SOUTHWEST QUARTER OF SECTION 33, TOWNSHIP 6 SOUTH, RANGE 66 WEST OF THE SIXTH PRINCIPAL MERIDIAN, HAVING A PUBLISHED ELEVATION OF 1799.2870 METERS (5903.13 FEET) NAVD '88 DATUM.

BASIS OF BEARINGS:
THE EAST LINE OF THE NORTHEAST QUARTER OF SAID SECTION 9 BEING MONUMENTED AT THE NORTHEAST CORNER OF SAID SECTION 9 BY A 3-1/4" ALUMINUM CAP STAMPED LS 23053 AND AT THE EAST QUARTER CORNER OF SAID SECTION 9 BY A 2-1/2" ALUMINUM CAP STAMPED LS 6935 BEING CONSIDERED TO BEAR SOUTH 00°15'06" EAST, 2648.70 FEET.

PREPARED UNDER THE
SUPERVISION OF

BRIAN P. WILSON
COLORADO P.E. 0050067

10333 E. Dry Creek Rd.
Suite 110
Englewood, CO 80110
Tel: (720) 482-9526
Fax: (720) 482-9546

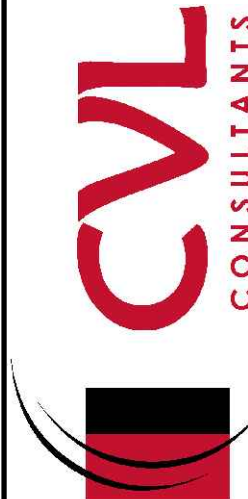

HR 935 LLC
7353 South Alton Way
CENTENNIAL, CO 80112

TRAILS AT CROWFOOT
FILING 9 CONSTRUCTION DRAWINGS
WATER PLAN & PROFILE
SCARLET SAGE AVENUE LATERALS

SCALE: AS SHOWN
DRAWN BY: RHR
CHECKED BY: JJ
DATE: MAY 2017
FILE NO: 8130283701

N:\PROJECTS\SSR\BANCROFT\ENGINEERING\SSR\BANCROFT\WATER AND SANITATION\WATER PLAN AND PROFILE\NORTH PINERY PARKWAY WATER.DWG, BRIANW, 2/26/2018 8:52 PM



UNCC



LITUTY NOTIFICATION CENTER OF COLORADO

CALL 811

TWO WORKING DAYS

BEFORE YOU DIG

1-800-922-1987

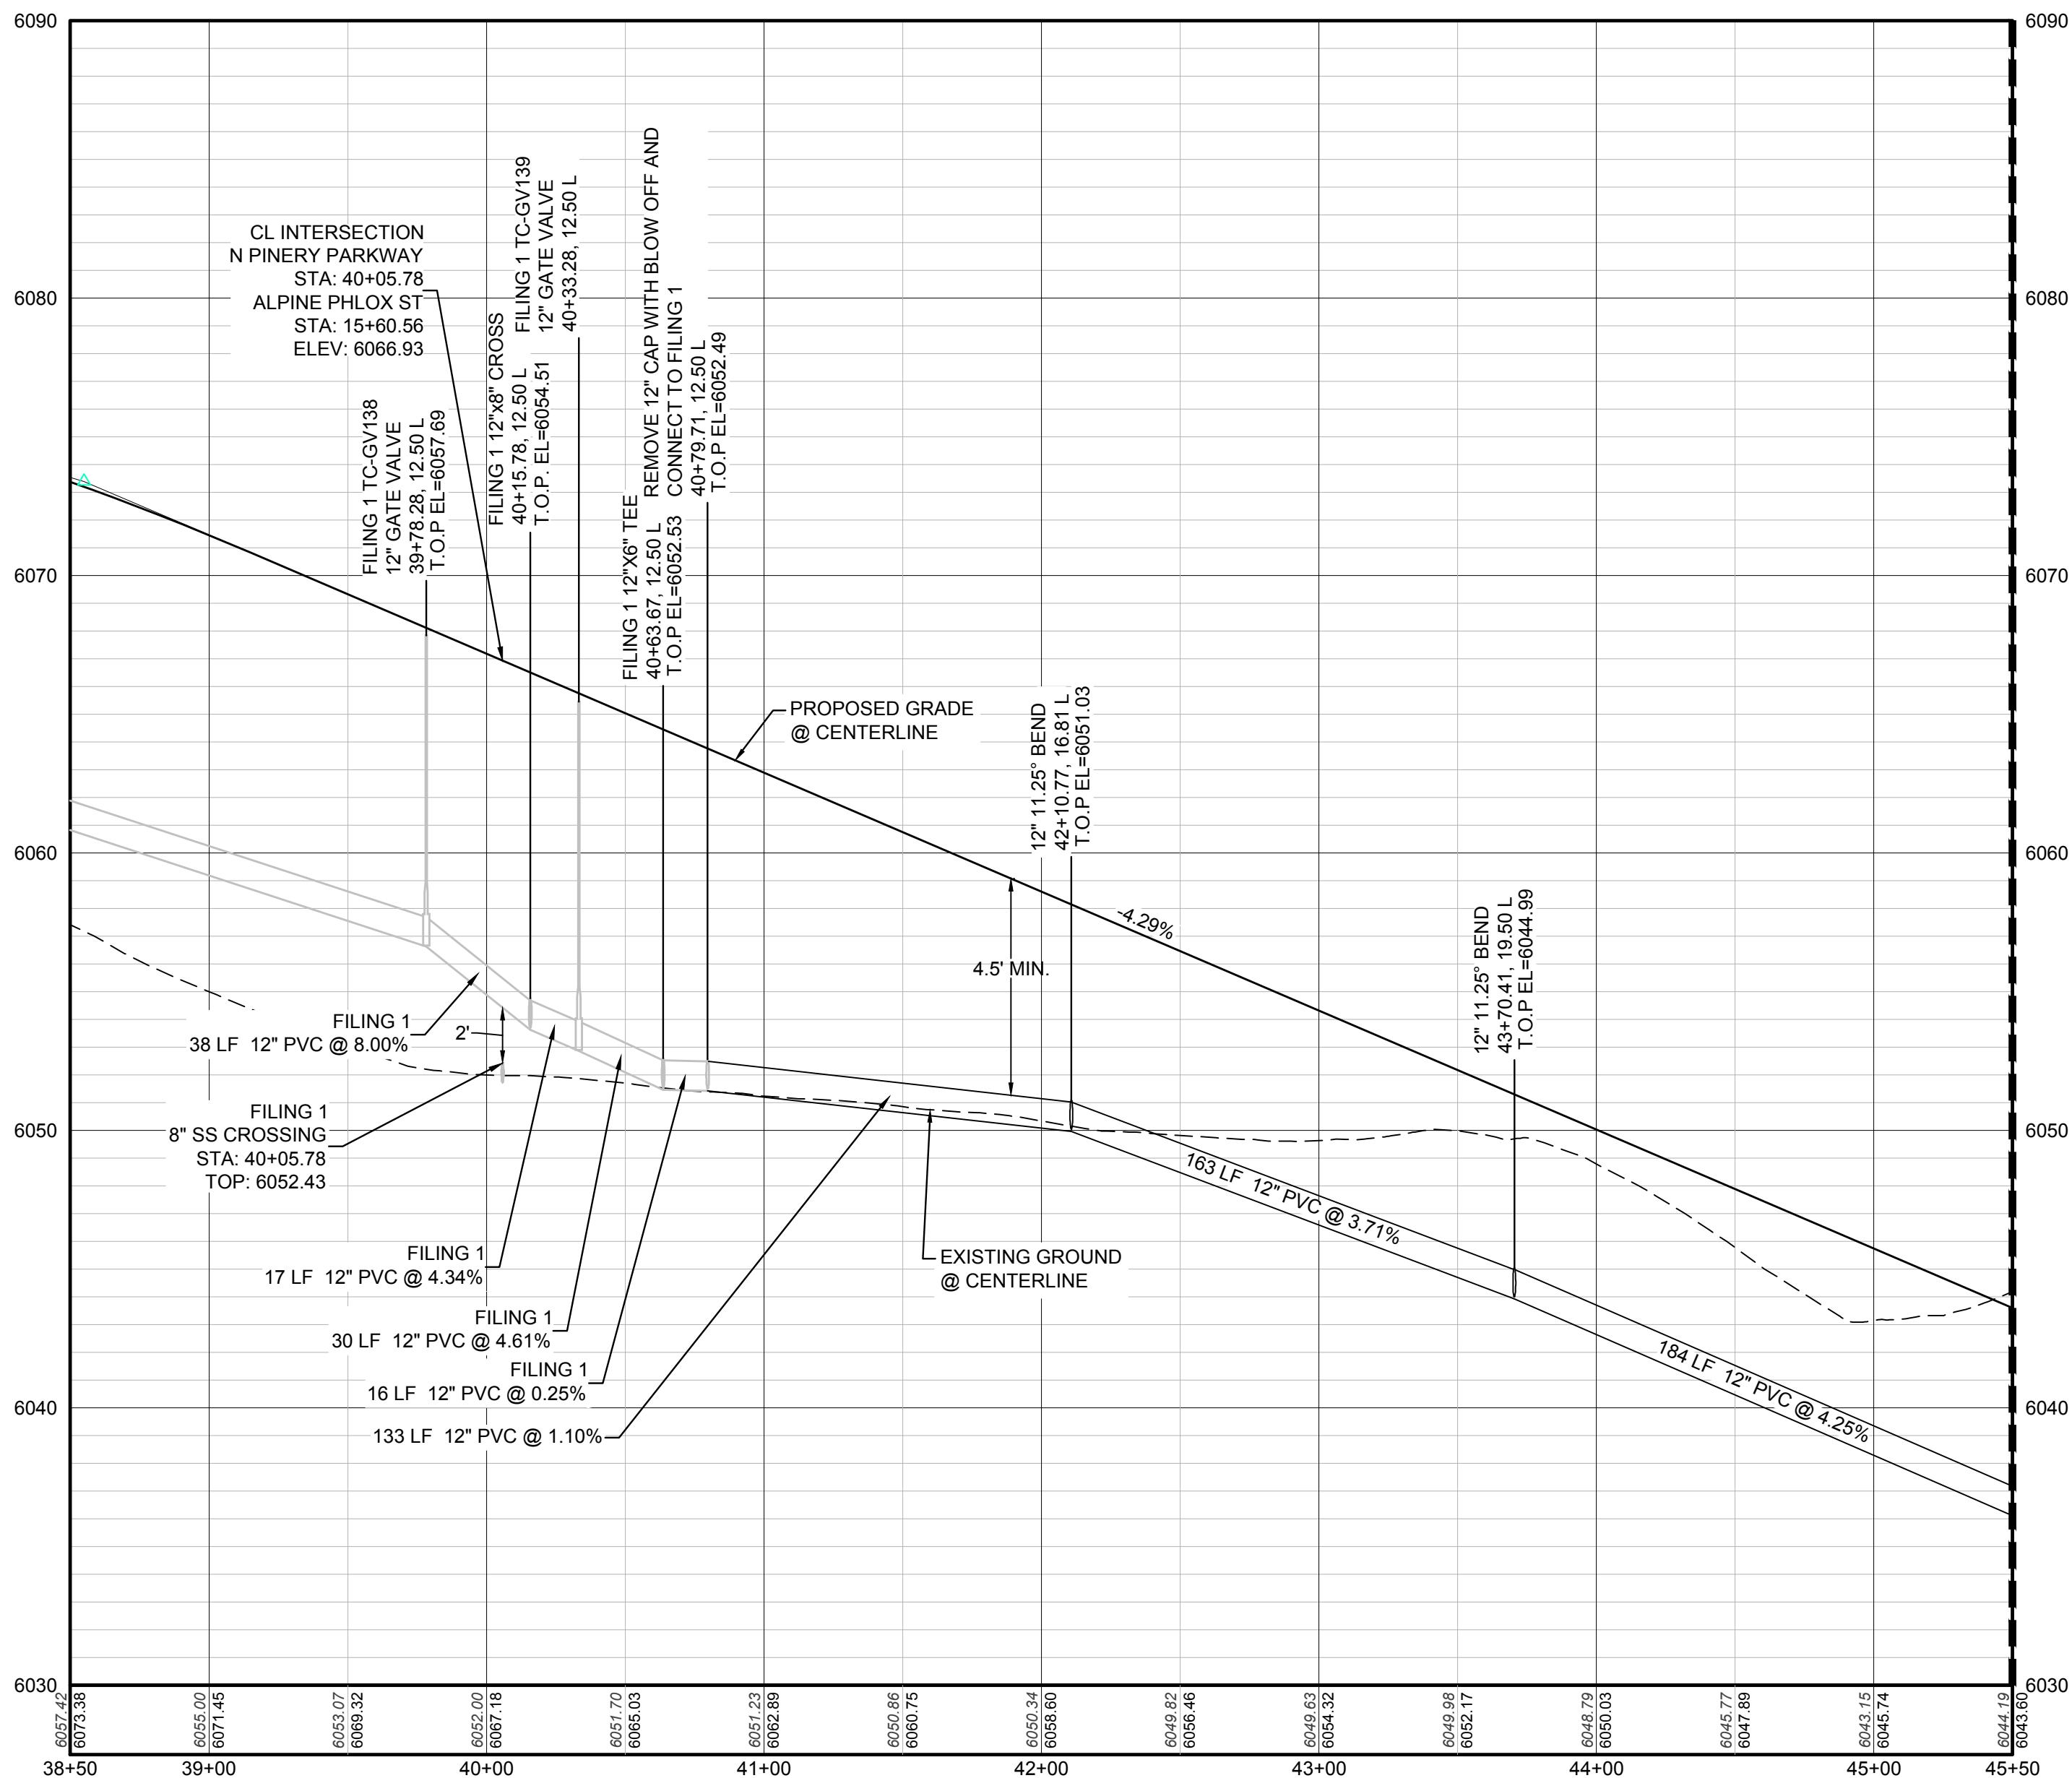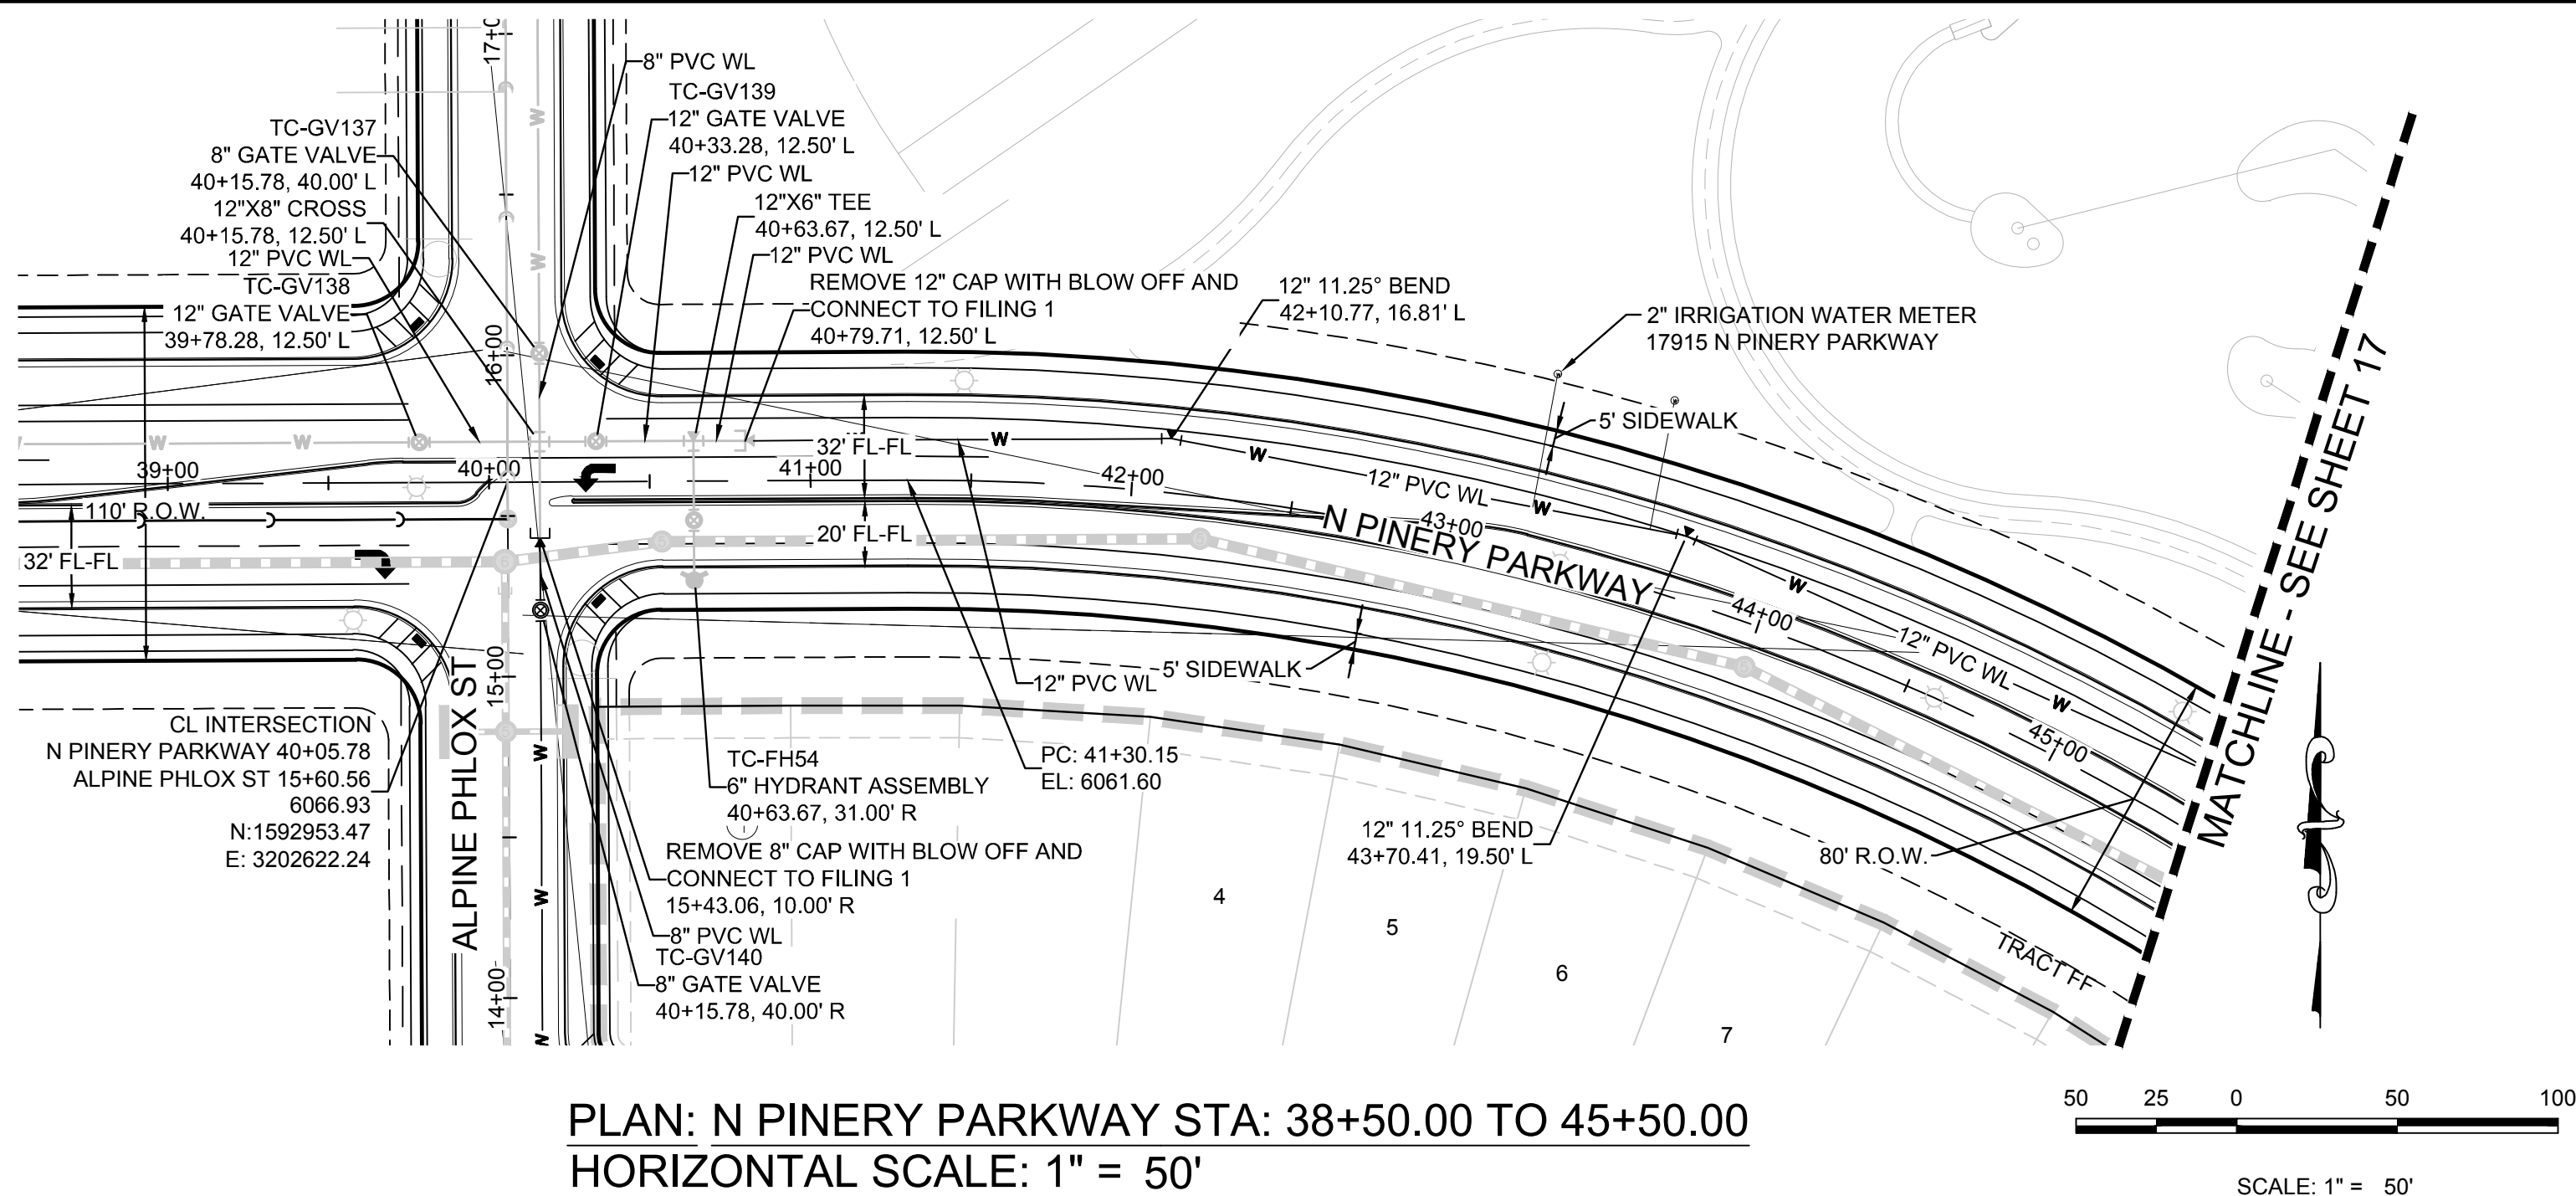


PROFILE: N PINERY PARKWAY STA: 38+50.00 TO 45+50.00
HORIZONTAL: 1" = 50'
VERTICAL: 1" = 5'

BENCHMARK
DOUGLAS COUNTY CONTROL POINT KNOWN AS 1.060032, BEING A 3-1/4" ALUMINUM CAP, BEING LOCATED IN THE SOUTHWEST QUARTER OF SECTION 33, TOWNSHIP 6 SOUTH, RANGE 66 WEST OF THE SIXTH PRINCIPAL MERIDIAN, HAVING A PUBLISHED ELEVATION OF 1799.2870 METERS (5903.13 FEET) NAVD '88 DATUM.

BASIS OF BEARINGS:
THE EAST LINE OF THE NORTHEAST QUARTER OF SAID SECTION 9 BEING MONUMENTED AT THE NORTHEAST CORNER OF SAID SECTION 9 BY A 3-1/4" ALUMINUM CAP STAMPED LS 23053 AND AT THE EAST QUARTER CORNER OF SAID SECTION 9 BY A 2-1/2" ALUMINUM CAP STAMPED LS 6935 BEING CONSIDERED TO BEAR SOUTH 00°15'06" EAST, 2648.70 FEET.

PREPARED UNDER THE
SUPERVISION OF

BRIAN P. WILSON
COLORADO P.E. 0050067

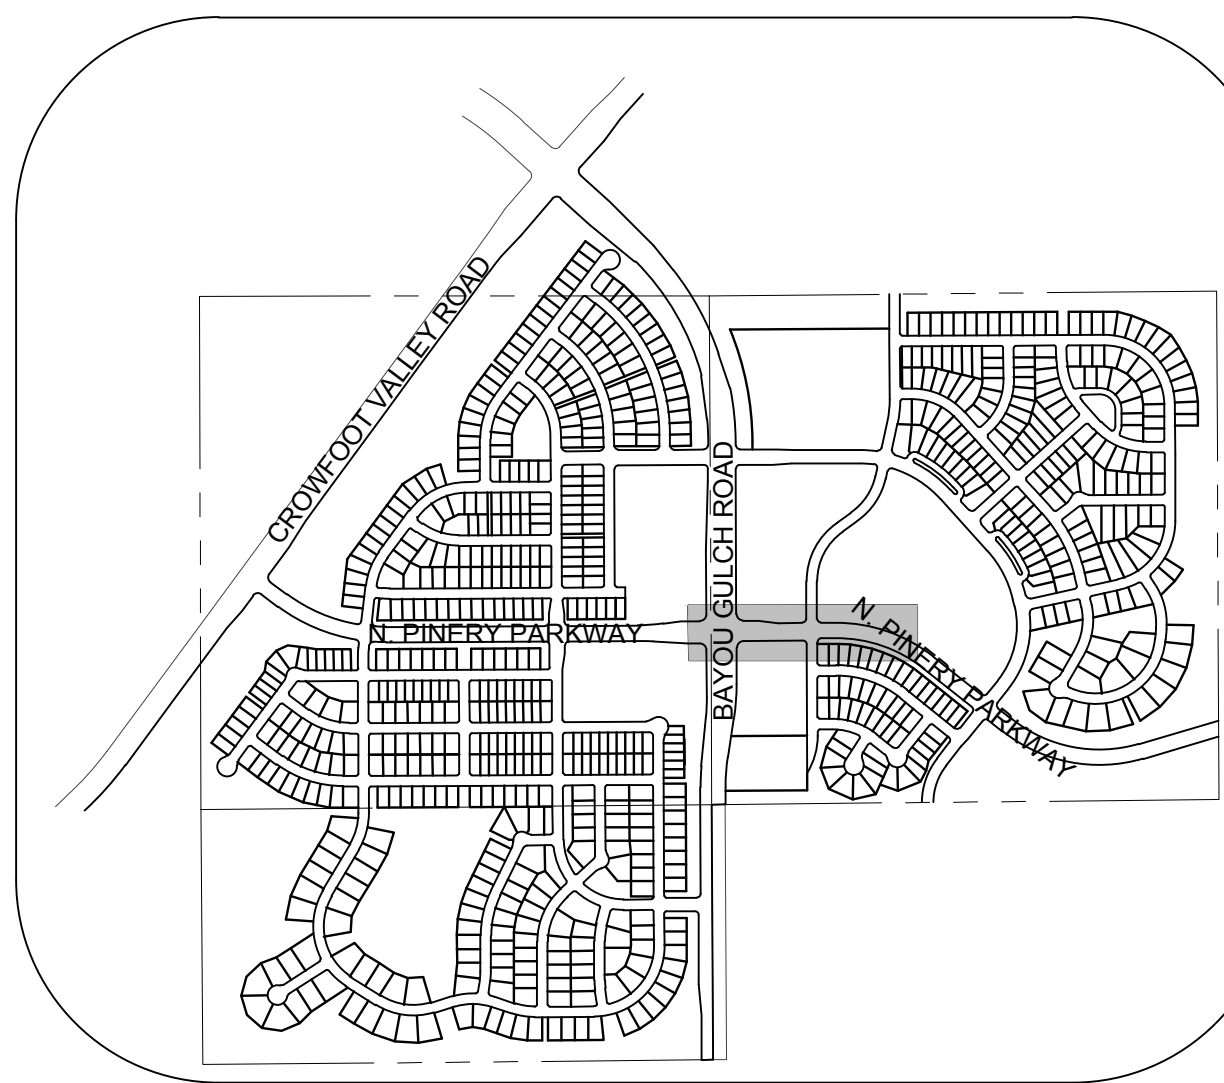


KEYMAP
N.T.S.
LEGEND

- | | | | |
|-------|---------------------------------------|------|----------------------------------|
| ② | BLOCK NUMBER | △ | PROPOSED RANGE POINT |
| Ⓐ | LOT TYPE | --- | CENTERLINE |
| 6 | LOT NUMBER | --- | RIGHT-OF-WAY |
| ⊗ | PROPOSED BUTTERFLY VALVE | --- | PROPERTY LINE |
| ⌋ | PROPOSED CAP WITH END OF LINE BLOWOFF | --- | EDGE OF PAVEMENT |
| ⌋ | PROPOSED REDUCER | → | PROPOSED DIRECTION OF FLOW |
| ⊗ | PROPOSED VALVE | 1.0% | PROPOSED SLOPE & DIRECTION |
| ⊗ | PROPOSED FIRE HYDRANT | --- | EXISTING 5' CONTOUR |
| ⊗ | PROPOSED WL FITTING WITH THRUST BLOCK | --- | EXISTING 1' CONTOUR |
| ⌋ | PROPOSED FLARED END SECTION | --- | PROPOSED 5' CONTOUR |
| ⊗ | PROPOSED LOW POINT BLOW-OFF | --- | PROPOSED 1' CONTOUR |
| ⊗ | PROPOSED AIR VALVE | --- | PROPOSED STORM DRAIN |
| ⊗ | FUTURE PHASE VALVE | --- | PROPOSED SEWER LINE WITH MANHOLE |
| ⊗ | FUTURE FIRE HYDRANT | --- | PROPOSED SEWER LATERAL |
| ⊗ | PROPOSED LIGHT POLE | --- | PROPOSED WATER LINE |
| ⊗ | PROPOSED SIDEWALK | --- | PROPOSED WATER LATERAL W/ METER |
| ⊗ | PROPOSED SIDEWALK RAMP | --- | SECTION LINE |
| 10.00 | EXISTING ELEVATION | --- | FILING BOUNDARY |
| 10.00 | PROPOSED DESIGN ELEVATION | --- | EXISTING FIBER OPTIC LINE |
| ⊗ | PROPOSED STORM DRAIN INLET | --- | EXISTING OVERHEAD POWER |
| ⊗ | PROPOSED STORM DRAIN MANHOLE | --- | EXISTING TELEPHONE LINE |

ABBREVIATIONS

- | | | | |
|-----|------------------------|--------|---------------------------------|
| AD | ANGLE DIFFERENCE | MH | MANHOLE |
| AV | AIR VAC RELEASE VALVE | N.T.S. | NOT TO SCALE |
| BVC | BEGIN VERTICAL CURVE | PVC | POLYVINYL CHLORIDE |
| BVP | BEGIN VERTICAL PROFILE | PVI | PT. OF VERTICAL INTERSECTION |
| CBO | CAP WITH BLOW OFF | PVT | POINT OF VERTICAL TANGENT |
| CRR | CURB RETURN RADIUS | RCBC | REINFORCED CONCRETE BOX CULVERT |
| EL | ELEVATION | RCP | REINFORCED CONCRETE PIPE |
| EP | EDGE OF PAVEMENT | ROW | RIGHT OF WAY |
| EVC | END VERTICAL CURVE | SC | SANITARY CAP |
| EVP | END VERTICAL PROFILE | SD | STORM DRAIN |
| FG | FINISHED GROUND | SL | SECTION LINE |
| FH | FIRE HYDRANT | SS | SANITARY SEWER |
| FL | FLOW LINE | STA | STATION |
| GV | GATE VALVE | T.O.P. | TOP OF PIPE |
| HCR | HANDICAP CURB RAMP | UE | UTILITY EASEMENT |
| HP | HIGH POINT | VC | VERTICAL CURVE |
| INV | INVERT | WL | WATER LINE |
| K | CURVATURE COEFFICIENT | WLC | WATER LINE CONNECTION |
| LF | LINEAR FEET | WSE | WATER SURFACE ELEVATION |

10333 E. Dry Creek Rd.
Suite 100
Englewood, CO 80110
Tel: (720) 482-9526
Fax: (720) 482-9548

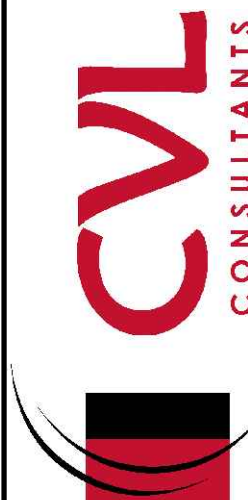






HR 935 LLC
7353 South Alton Way
CENTENNIAL, CO 80112


TRAILS AT CROWFOOT
FILING 9 CONSTRUCTION DRAWINGS
WATER PLAN & PROFILE
NORTH PINERY PARKWAY

DRAWN BY: RHR
CHECKED BY: JJ
DATE: MAY 2017
SCALE: AS SHOWN
FILE NO: 8130283701

    SHEET NUMBER
16

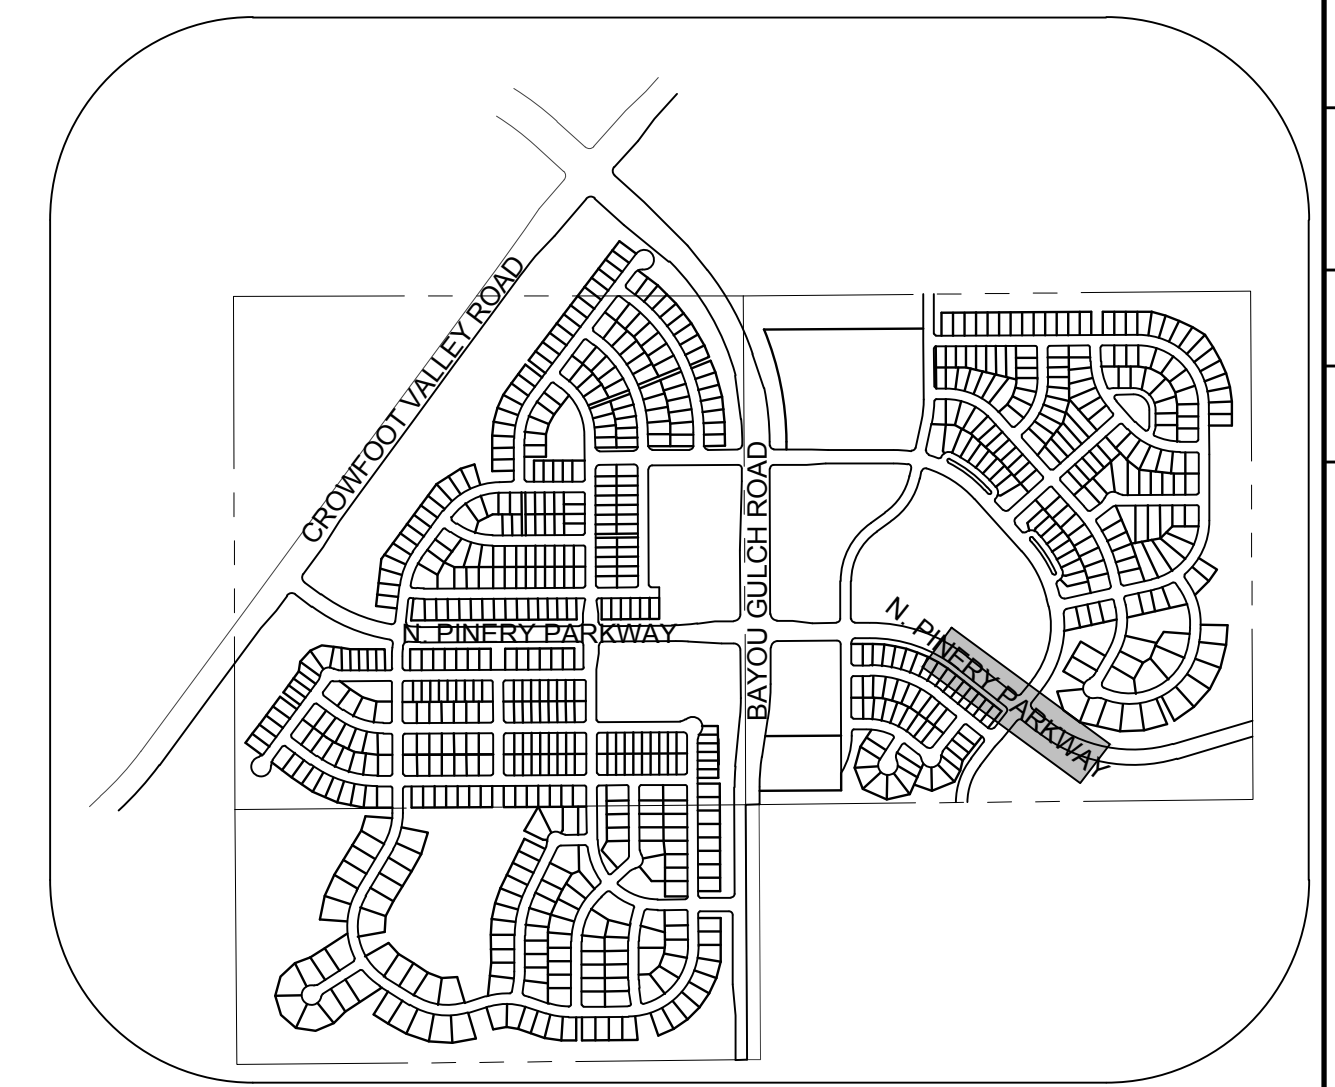

	BLOCK NUMBER		PROPOSED RANGE POINT
	LOT TYPE		CENTERLINE
6	LOT NUMBER		RIGHT-OF-WAY
	PROPOSED BUTTERFLY VALVE		PROPERTY LINE
	PROPOSED CAP WITH END OF LINE BLOWOFF		EDGE OF PAVEMENT
	PROPOSED REDUCER		PROPOSED DIRECTION OF FLOW
	PROPOSED VALVE		PROPOSED SLOPE & DIRECTION
	PROPOSED FIRE HYDRANT		EXISTING 5' CONTOUR
	PROPOSED WL FITTING WITH THRUST BLOCK		EXISTING 1' CONTOUR
	PROPOSED FLARED END SECTION		PROPOSED 5' CONTOUR
	PROPOSED LOW POINT BLOW-OFF		PROPOSED 1' CONTOUR
	PROPOSED AIR VALVE		PROPOSED STORM DRAIN
	FUTURE PHASE VALVE		PROPOSED SEWER LINE WITH MANHOLE
	FUTURE FIRE HYDRANT		PROPOSED SEWER LATERAL
	PROPOSED LIGHT POLE		PROPOSED WATER LINE
	PROPOSED SIDEWALK		PROPOSED WATER LATERAL W/ METER
	PROPOSED SIDEWALK RAMP		SECTION LINE
10.00	EXISTING ELEVATION		FILING BOUNDARY
10.00	PROPOSED DESIGN ELEVATION		EXISTING FIBER OPTIC LINE
	PROPOSED STORM DRAIN INLET		EXISTING OVERHEAD POWER
	PROPOSED STORM DRAIN MANHOLE		EXISTING TELEPHONE LINE

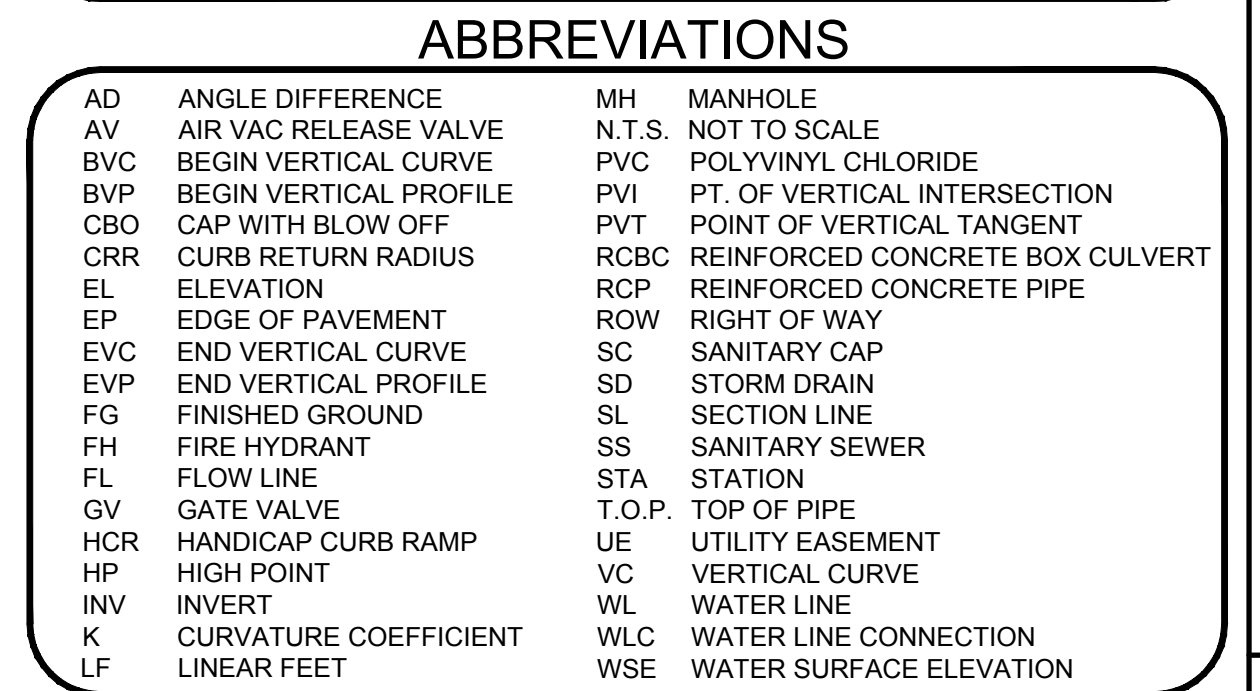





 **UNCC**
UTILITY NOTIFICATION
CENTER OF COLORADO

CALL 811
TWO WORKING DAYS
BEFORE YOU DIG
1-800-922-1987


BASIS OF BEARINGS:
THE EAST LINE OF THE NORTHEAST QUARTER OF SAID SECTION 9 BEING MONUMENTED AT THE NORTHEAST CORNER OF SAID SECTION 9 BY A 3-1/4" ALUMINUM CAP STAMPED LS 23053 AND AT THE EAST QUARTER CORNER OF SAID SECTION 9 BY A 2-1/2" ALUMINUM CAP STAMPED LS 6935 BEING CONSIDERED TO BEAR SOUTH 00°15'06" EAST, 2648.70 FEET.

PREPARED UNDER THE
SUPERVISION OF


BRIAN P. WILSON
COLORADO P.E. 0050067

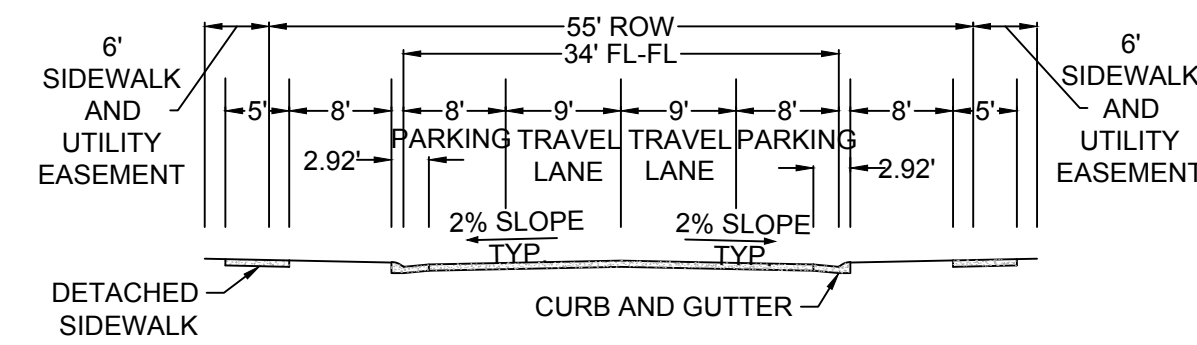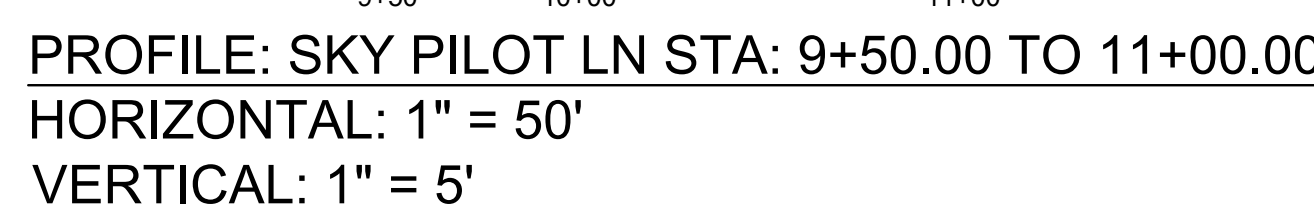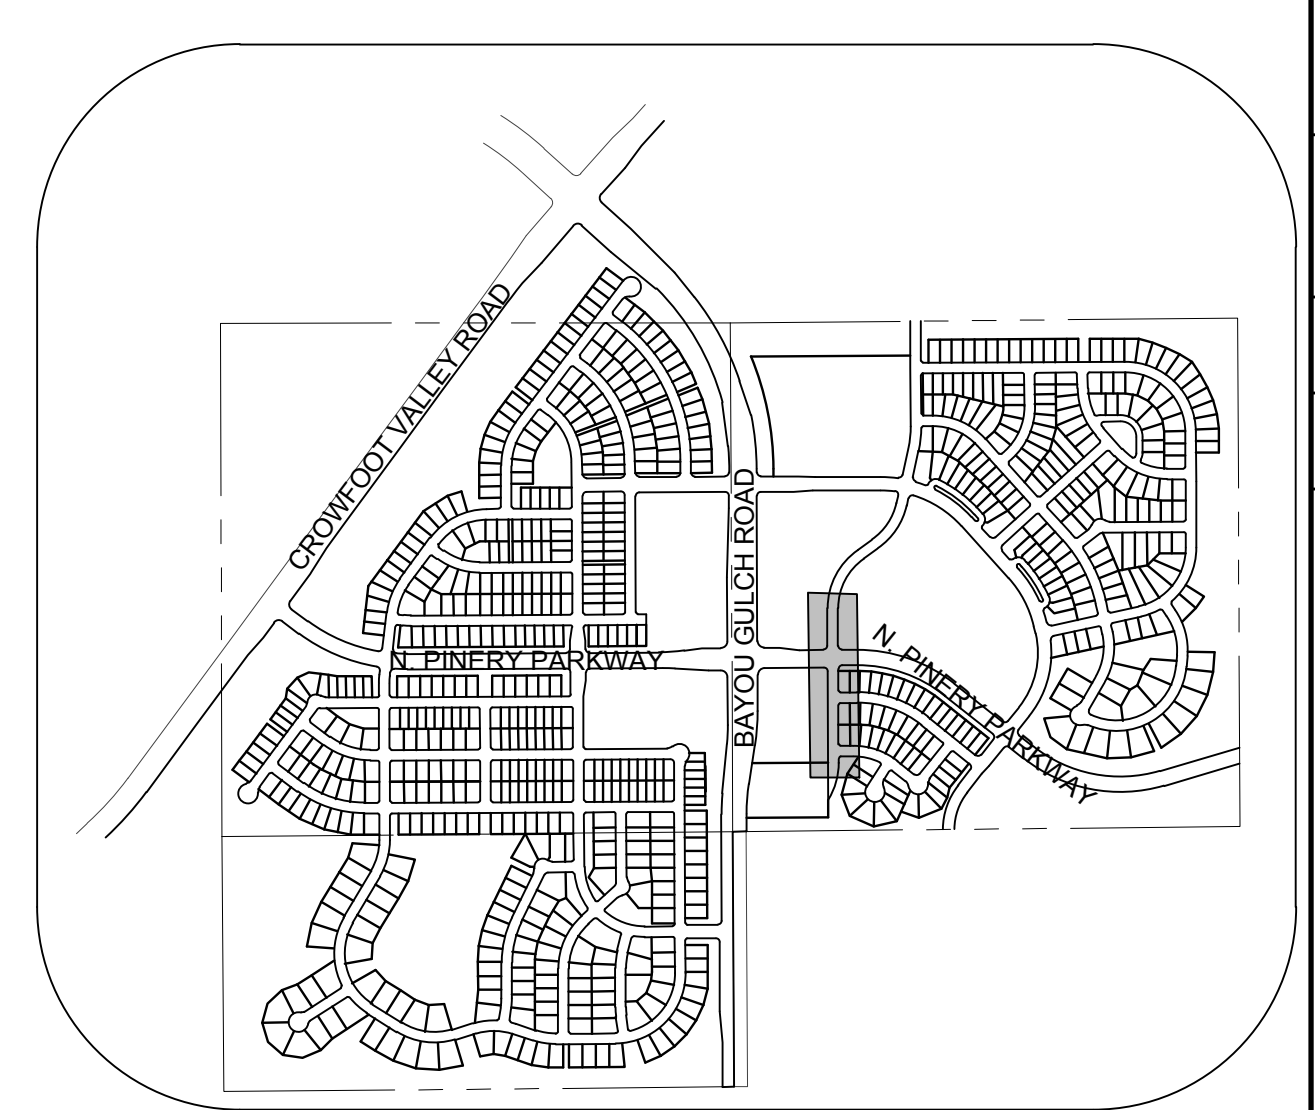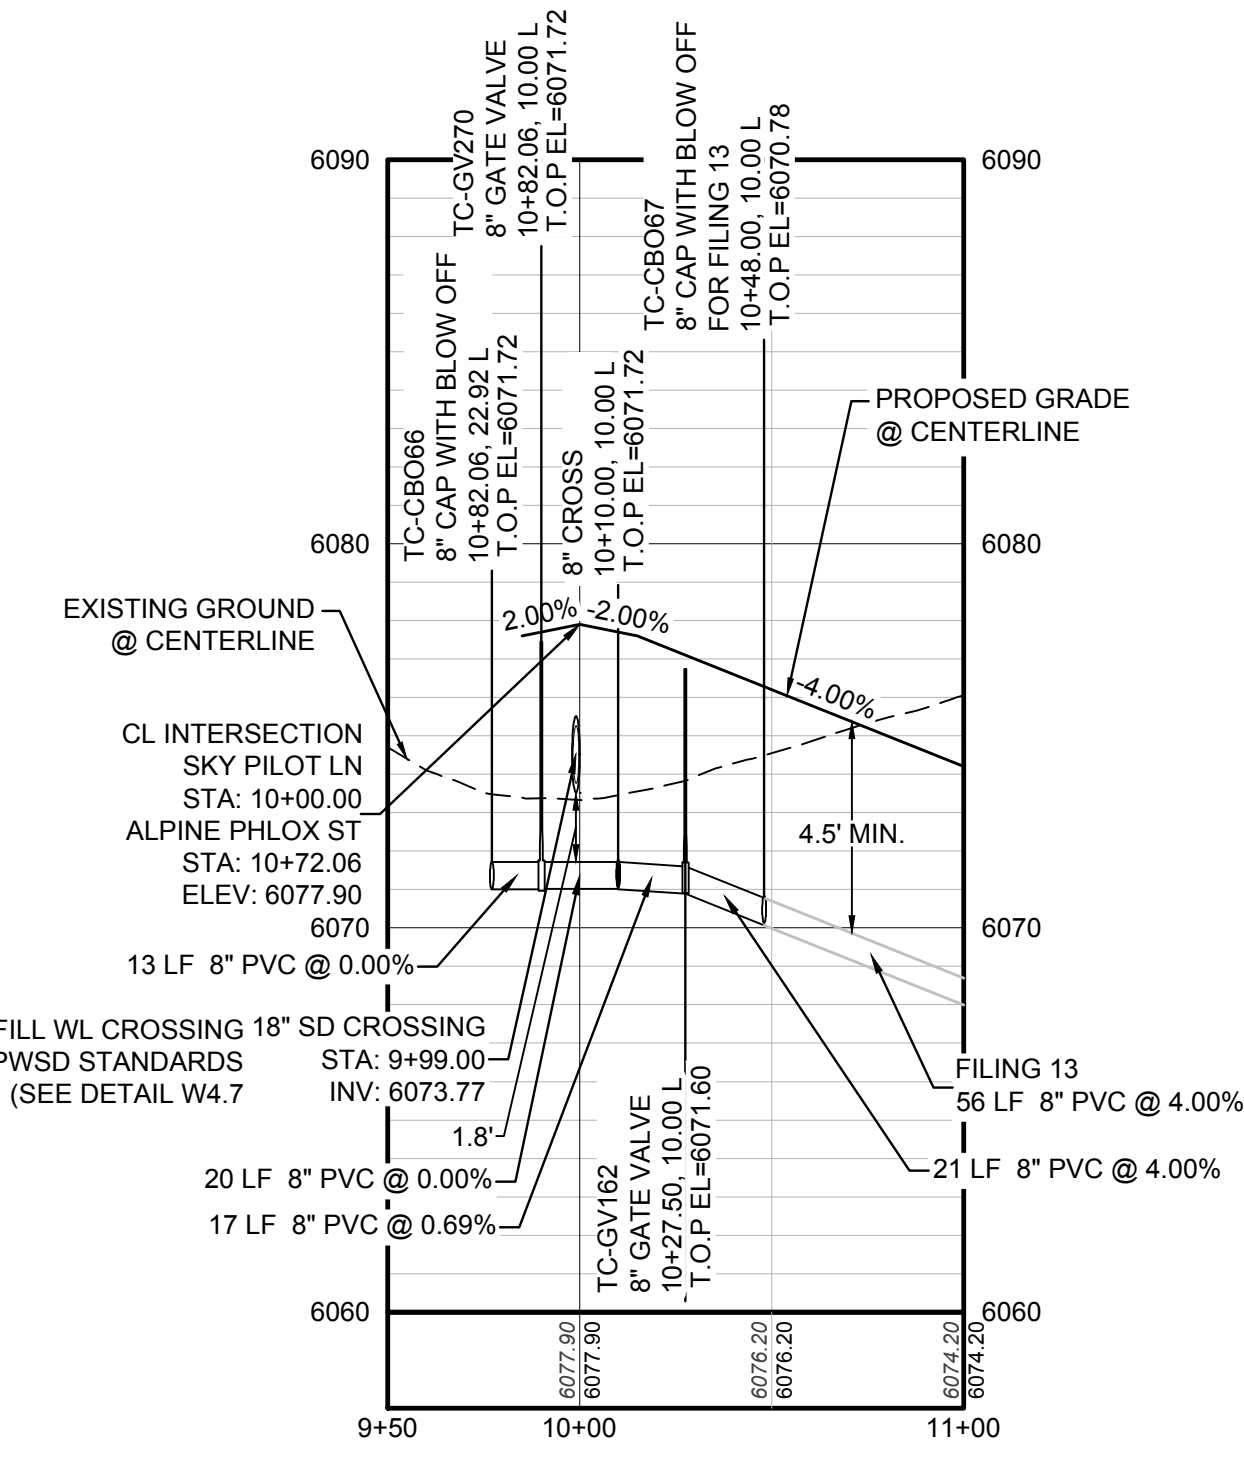








RESIDENTIAL LOCAL

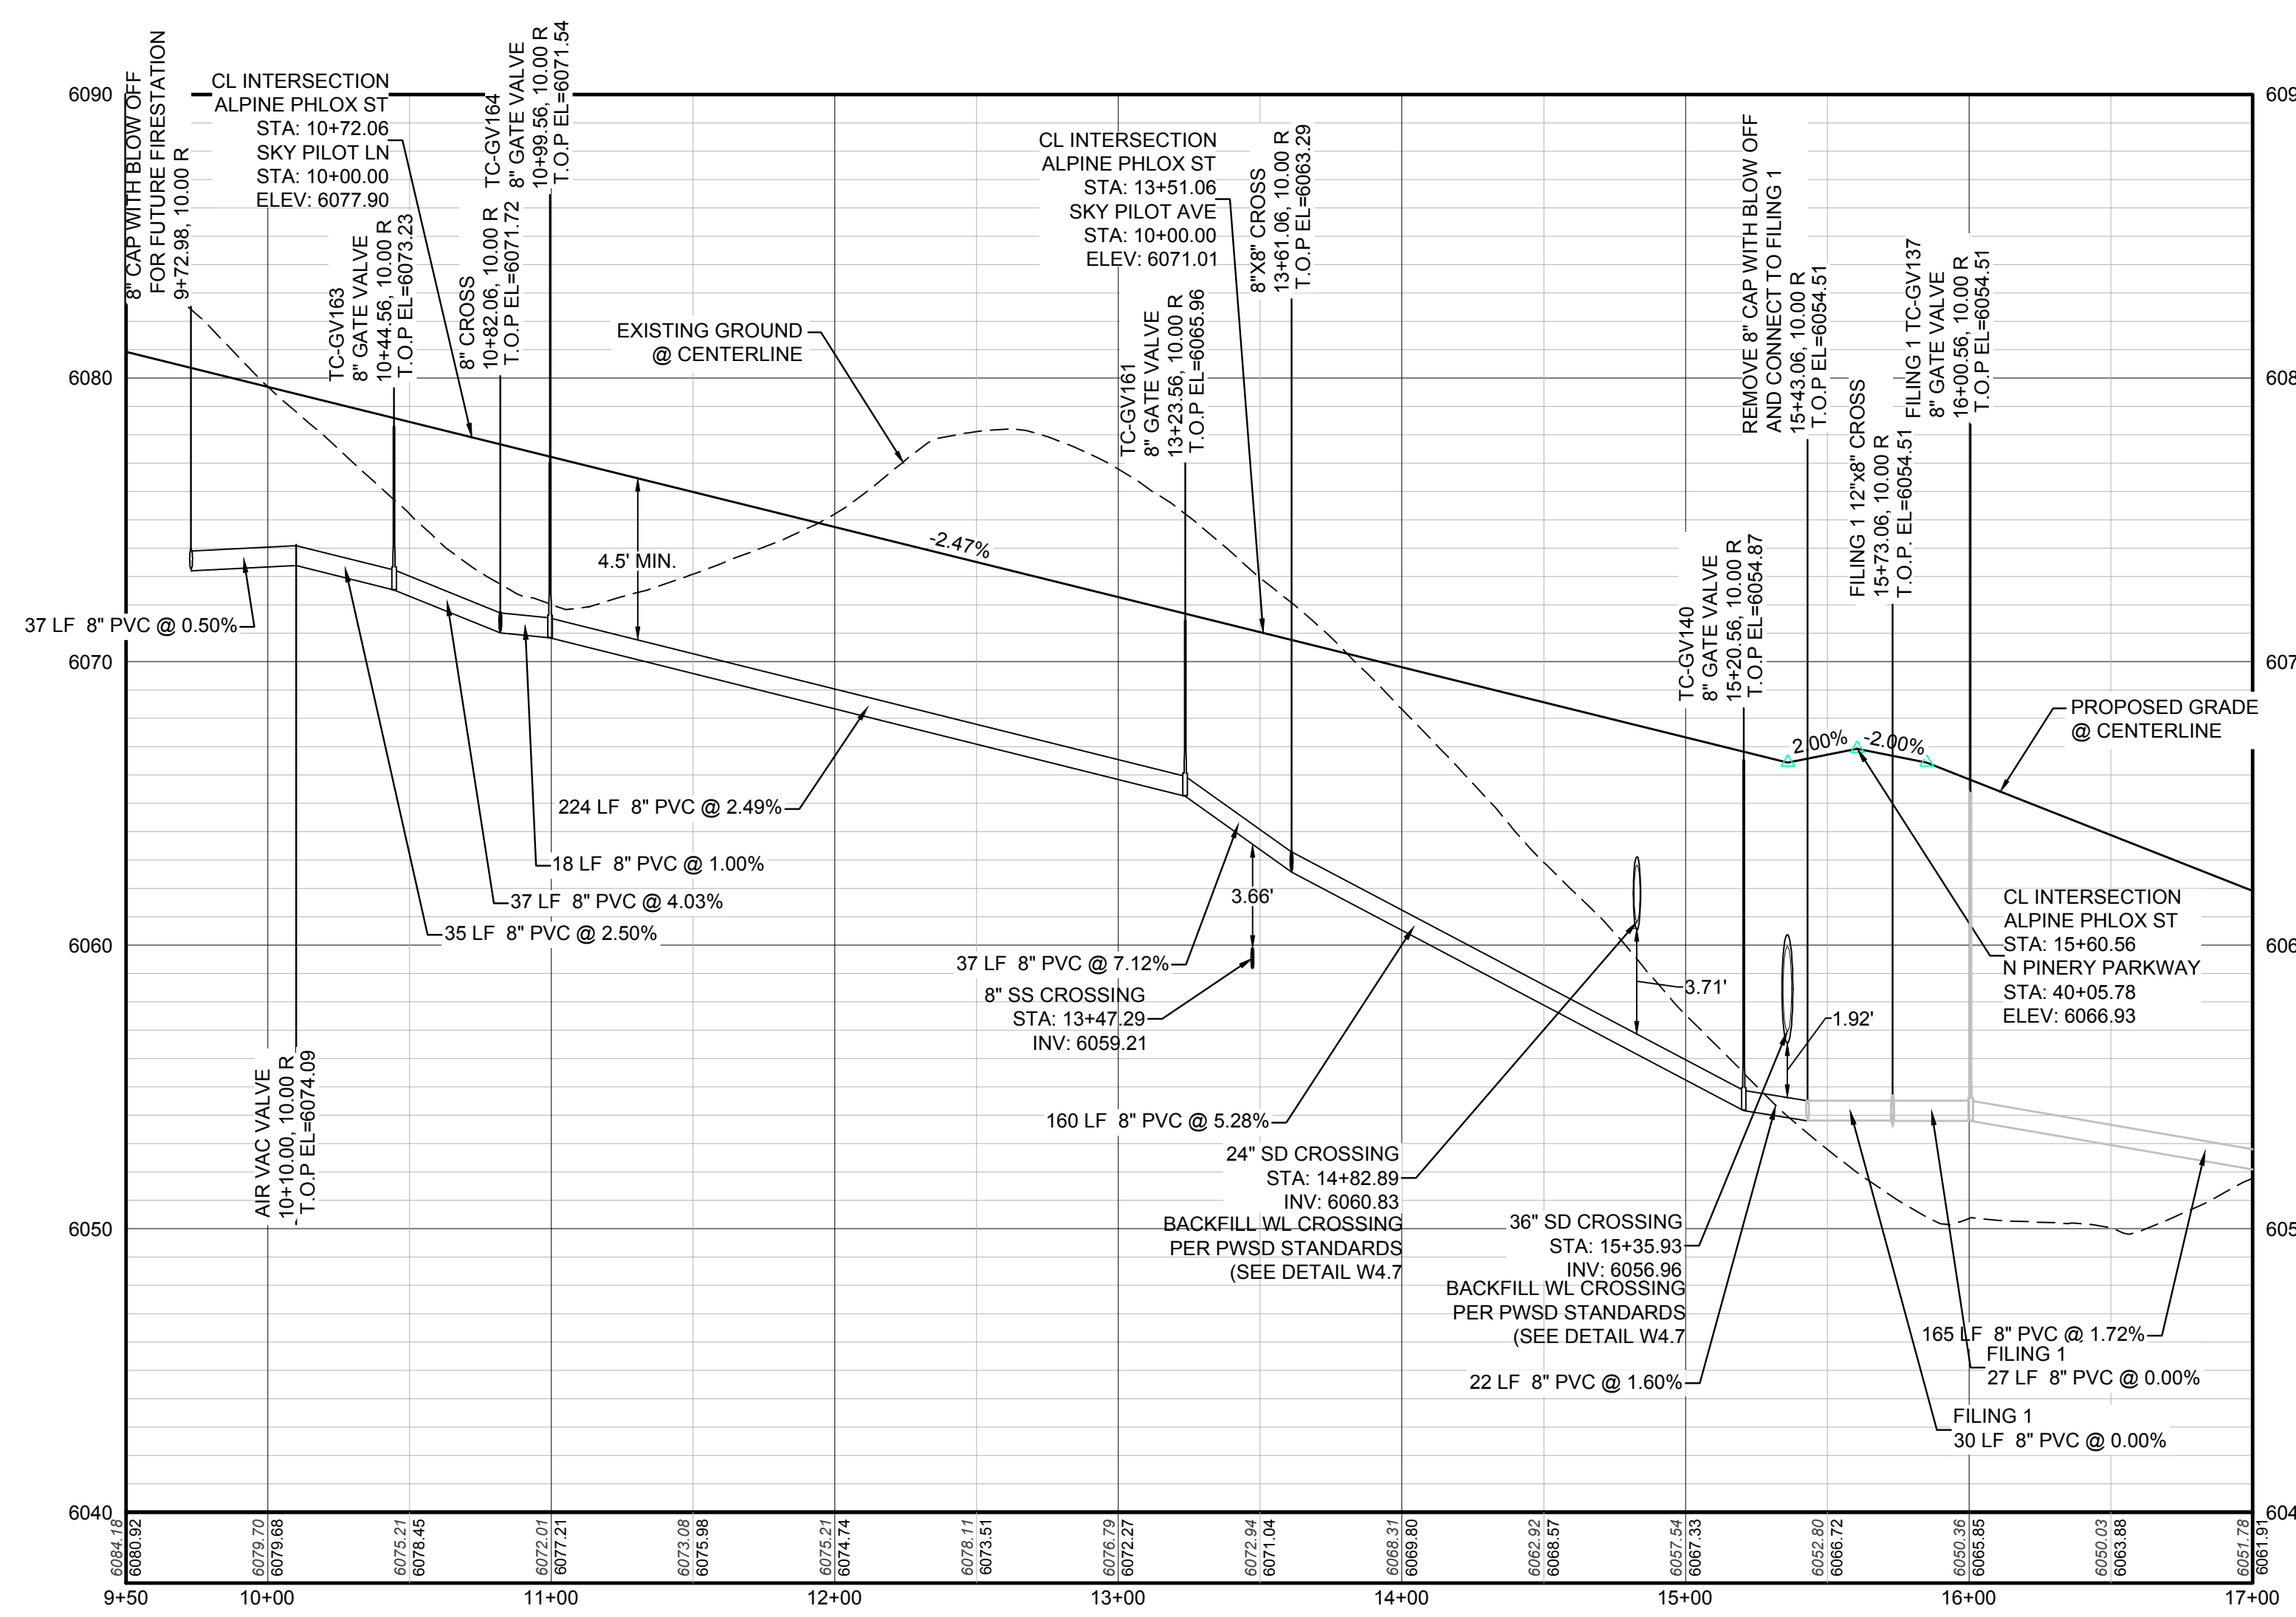

PROFILE: ALPINE PHLOX ST STA: 9+50.00 TO 17+00.00
HORIZONTAL: 1" = 50'
VERTICAL: 1" = 5'

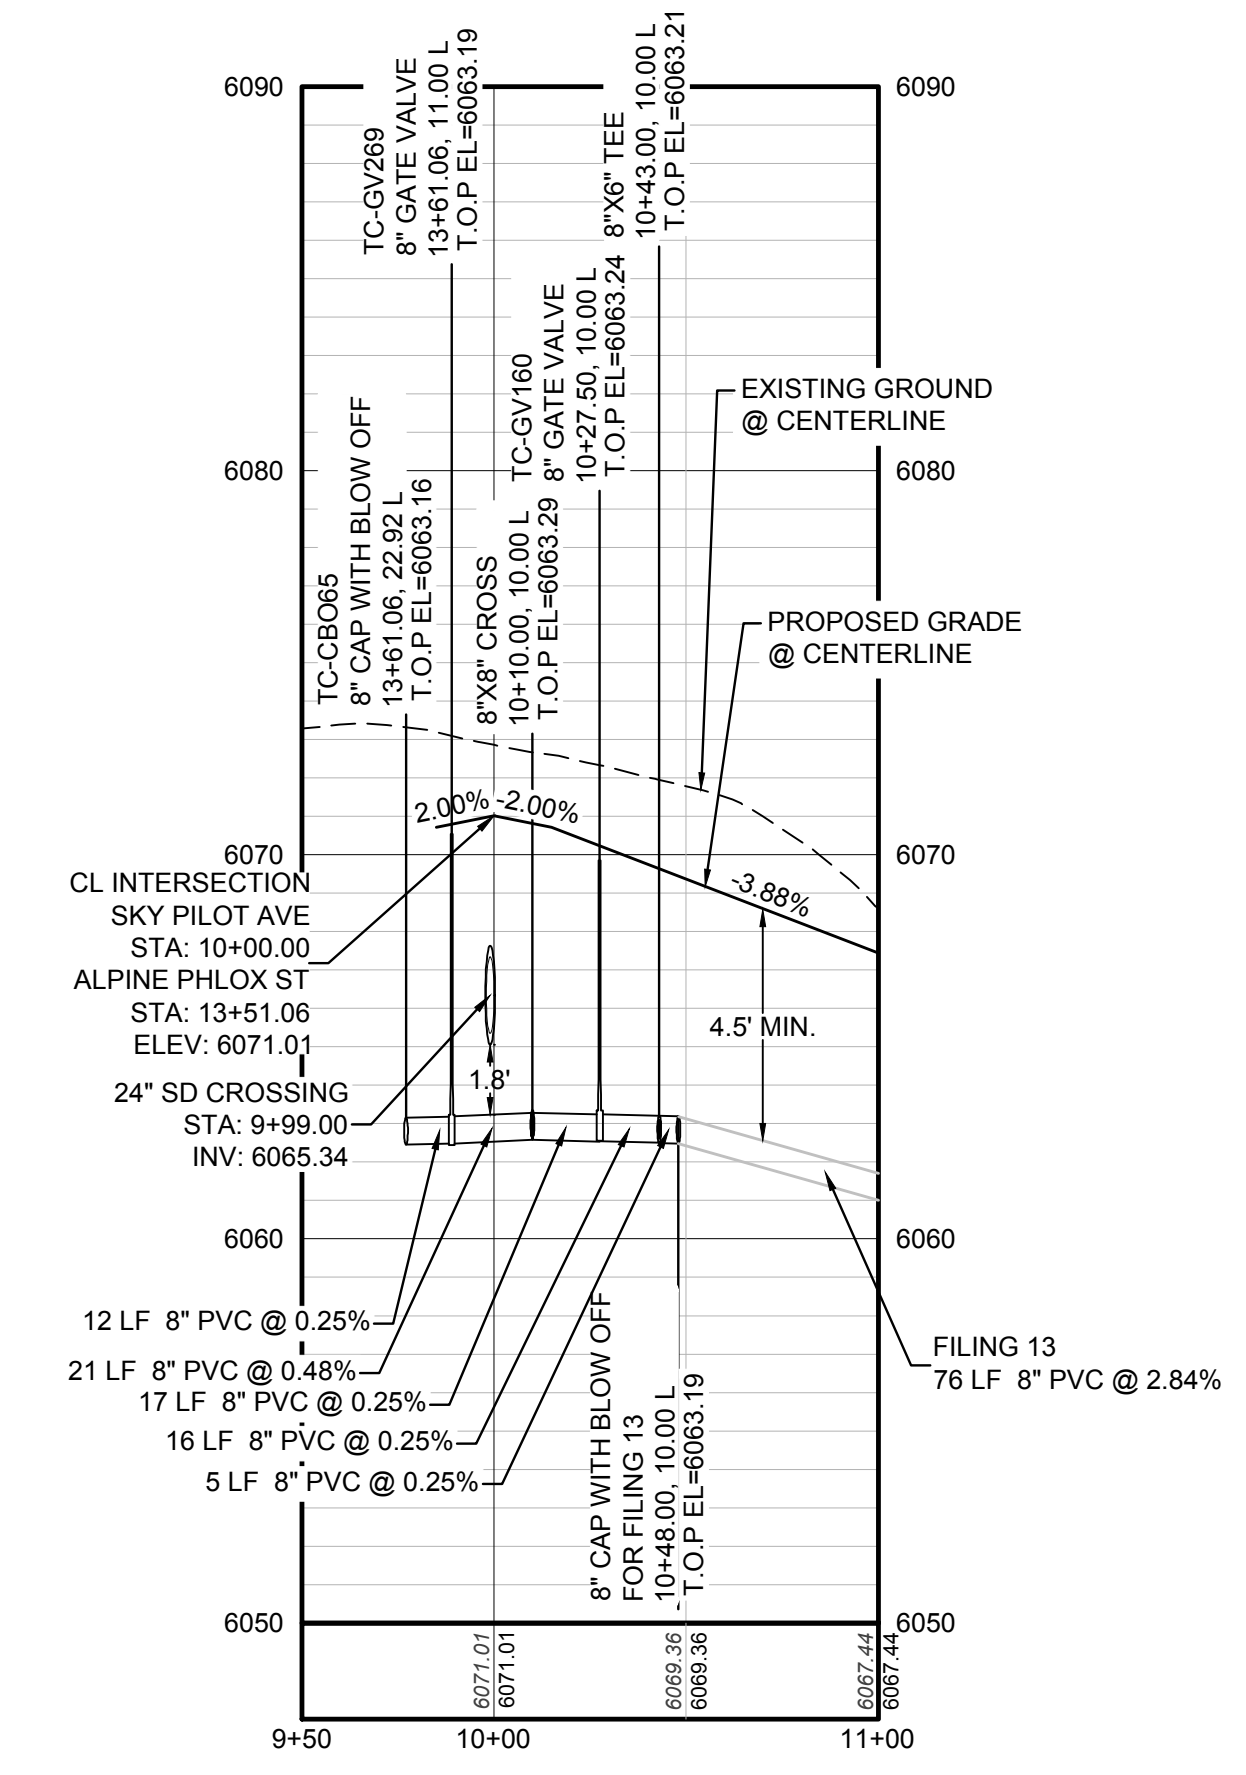

       PROFILE: SKY PILOT AVE STA: 9+50.00 TO 11+00.00
HORIZONTAL: 1" = 50'
VERTICAL: 1" = 5'

	BLOCK NUMBER		PROPOSED RANGE POINT
	LOT TYPE		CENTERLINE
6	LOT NUMBER		RIGHT-OF-WAY
	PROPOSED BUTTERFLY VALVE		PROPERTY LINE
	PROPOSED CAP WITH END OF LINE BLOWOFF		EDGE OF PAVEMENT
	PROPOSED REDUCER		PROPOSED DIRECTION OF FLOW
	PROPOSED VALVE		PROPOSED SLOPE & DIRECTION
	PROPOSED FIRE HYDRANT		EXISTING 5' CONTOUR
	PROPOSED WL FITTING WITH THRUST BLOCK		EXISTING 1' CONTOUR
	PROPOSED FLARED END SECTION		PROPOSED 5' CONTOUR
	PROPOSED LOW POINT BLOWOFF		PROPOSED 1' CONTOUR
	PROPOSED AIR VALVE		PROPOSED STORM DRAIN
	FUTURE PHASE VALVE		PROPOSED SEWER LINE WITH MANHOLE
	FUTURE FIRE HYDRANT		PROPOSED SEWER LATERAL
	PROPOSED LIGHT POLE		PROPOSED WATER LINE
	PROPOSED SIDEWALK		PROPOSED WATER LATERAL W/ METER
	PROPOSED SIDEWALK RAMP		SECTION LINE
10.00	EXISTING ELEVATION		FILING BOUNDARY
10.00	PROPOSED DESIGN ELEVATION		EXISTING FIBER OPTIC LINE
	PROPOSED STORM DRAIN INLET		EXISTING OVERHEAD POWER
	PROPOSED STORM DRAIN MANHOLE		EXISTING TELEPHONE LINE

ABBREVIATIONS

AD	ANGLE DIFFERENCE	MH	MANHOLE
BVC	AIR VAC RELEASE VALVE	N.T.S.	NOT TO SCALE
BVC	BEGIN VERTICAL CURVE	PVC	POLYVINYL CHLORIDE
BVP	BEGIN VERTICAL PROFILE	PVI	POINT OF VERTICAL INTERSECTION
CBO	CAP WITH BLOW OFF	PVT	POINT OF VERTICAL TANGENT
CRR	CURB RETURN RADIUS	RBCB	REINFORCED CONCRETE BOX CULVERT
EL	ELEVATION	RCP	REINFORCED CONCRETE PIPE
EP	EDGE OF PAVEMENT	ROW	RIGHT OF WAY
EVC	END VERTICAL CURVE	SC	SANITARY CAP
EVP	END VERTICAL PROFILE	SD	STORM DRAIN
FG	FINISHED GROUND	SL	SECTION LINE
FH	FIRE HYDRANT	SS	SANITARY SEWER
FL	FLOW LINE	STA	STATION
GV	GATE VALVE	T.O.P.	TOP OF PIPE
HCR	HANDICAP CURB RAMP	UE	UTILITY EASEMENT
HP	HIGH POINT	VC	VERTICAL CURVE
INV	INVERT	WL	WATER LINE
K	CURVATURE COEFFICIENT	WLC	WATER LINE CONNECTION
LF	LINEAR FEET	WSE	WATER SURFACE ELEVATION

333 E. Dry Creek Rd.
Suite 240
Englewood, CO 80112
Tel: (720) 482-9526
Fax: (720) 482-9546



HR 935 LLC
7353 South Alton Way
CENTENNIAL, CO 80111

TRAILS AT CROWFOOT
9 CONSTRUCTION DRAWINGS
WATER PLAN AND PROFILE
ALPINE PHILOX STREET

SCALE: AS SHOWN	FILE NO: 8130283701
--------------------	------------------------

DRAWN BY:	RHR
CHECKED BY:	JJJ
DATE:	MAY 2017

18

N:\PROJECTS\HSS RANCH\CAD\ENGINEERING\SHEET SETS\CD\S\F9\PARKER WATER AND SANITATION\WATER PLAN AND PROFILE\F9 ALPINE PHLOX STREET WATER.DWG, CODYA, 2/26/2018 6:38 PM



CALL 811
TWO WORKING DAYS
BEFORE YOU DIG
1-800-922-1987

UNCC
UTILITY NOTIFICATION
CENTER OF COLORADO


BENCHMARK
DOUGLAS COUNTY CONTROL POINT KNOWN AS 1.060032, BEING A 3-1/4" ALUMINUM CAP, BEING LOCATED IN THE SOUTHWEST QUARTER OF SECTION 33, TOWNSHIP 6 SOUTH, RANGE 66 WEST OF THE SIXTH PRINCIPAL MERIDIAN, HAVING A PUBLISHED ELEVATION OF 1799.2870 METERS (5903.13 FEET) NAVD '88 DATUM.

BASIS OF BEARINGS:
THE EAST LINE OF THE NORTHEAST QUARTER OF SAID SECTION 9 BEING MONUMENTED AT THE NORTHEAST CORNER OF SAID SECTION 9 BY A 3-1/4" ALUMINUM CAP STAMPED LS 23053 AND AT THE EAST QUARTER CORNER OF SAID SECTION 9 BY A 2-1/2" ALUMINUM CAP STAMPED LS 6935 BEING CONSIDERED TO BEAR SOUTH 00°15'06" EAST, 2648.70 FEET.



PREPARED UNDER THE
SUPERVISION OF

BRIAN P. WILSON
COLORADO P.E. 0050067

N:\PROJECTS\SSR\BANCROFT\ENGINEERING\SSR\BANCROFT\WATER AND SANITATION\WATER PLAN AND PROFILE\ALPINE PHLOX STREET WATER.DWG, CDDVA, 2/26/2018 6:39 PM

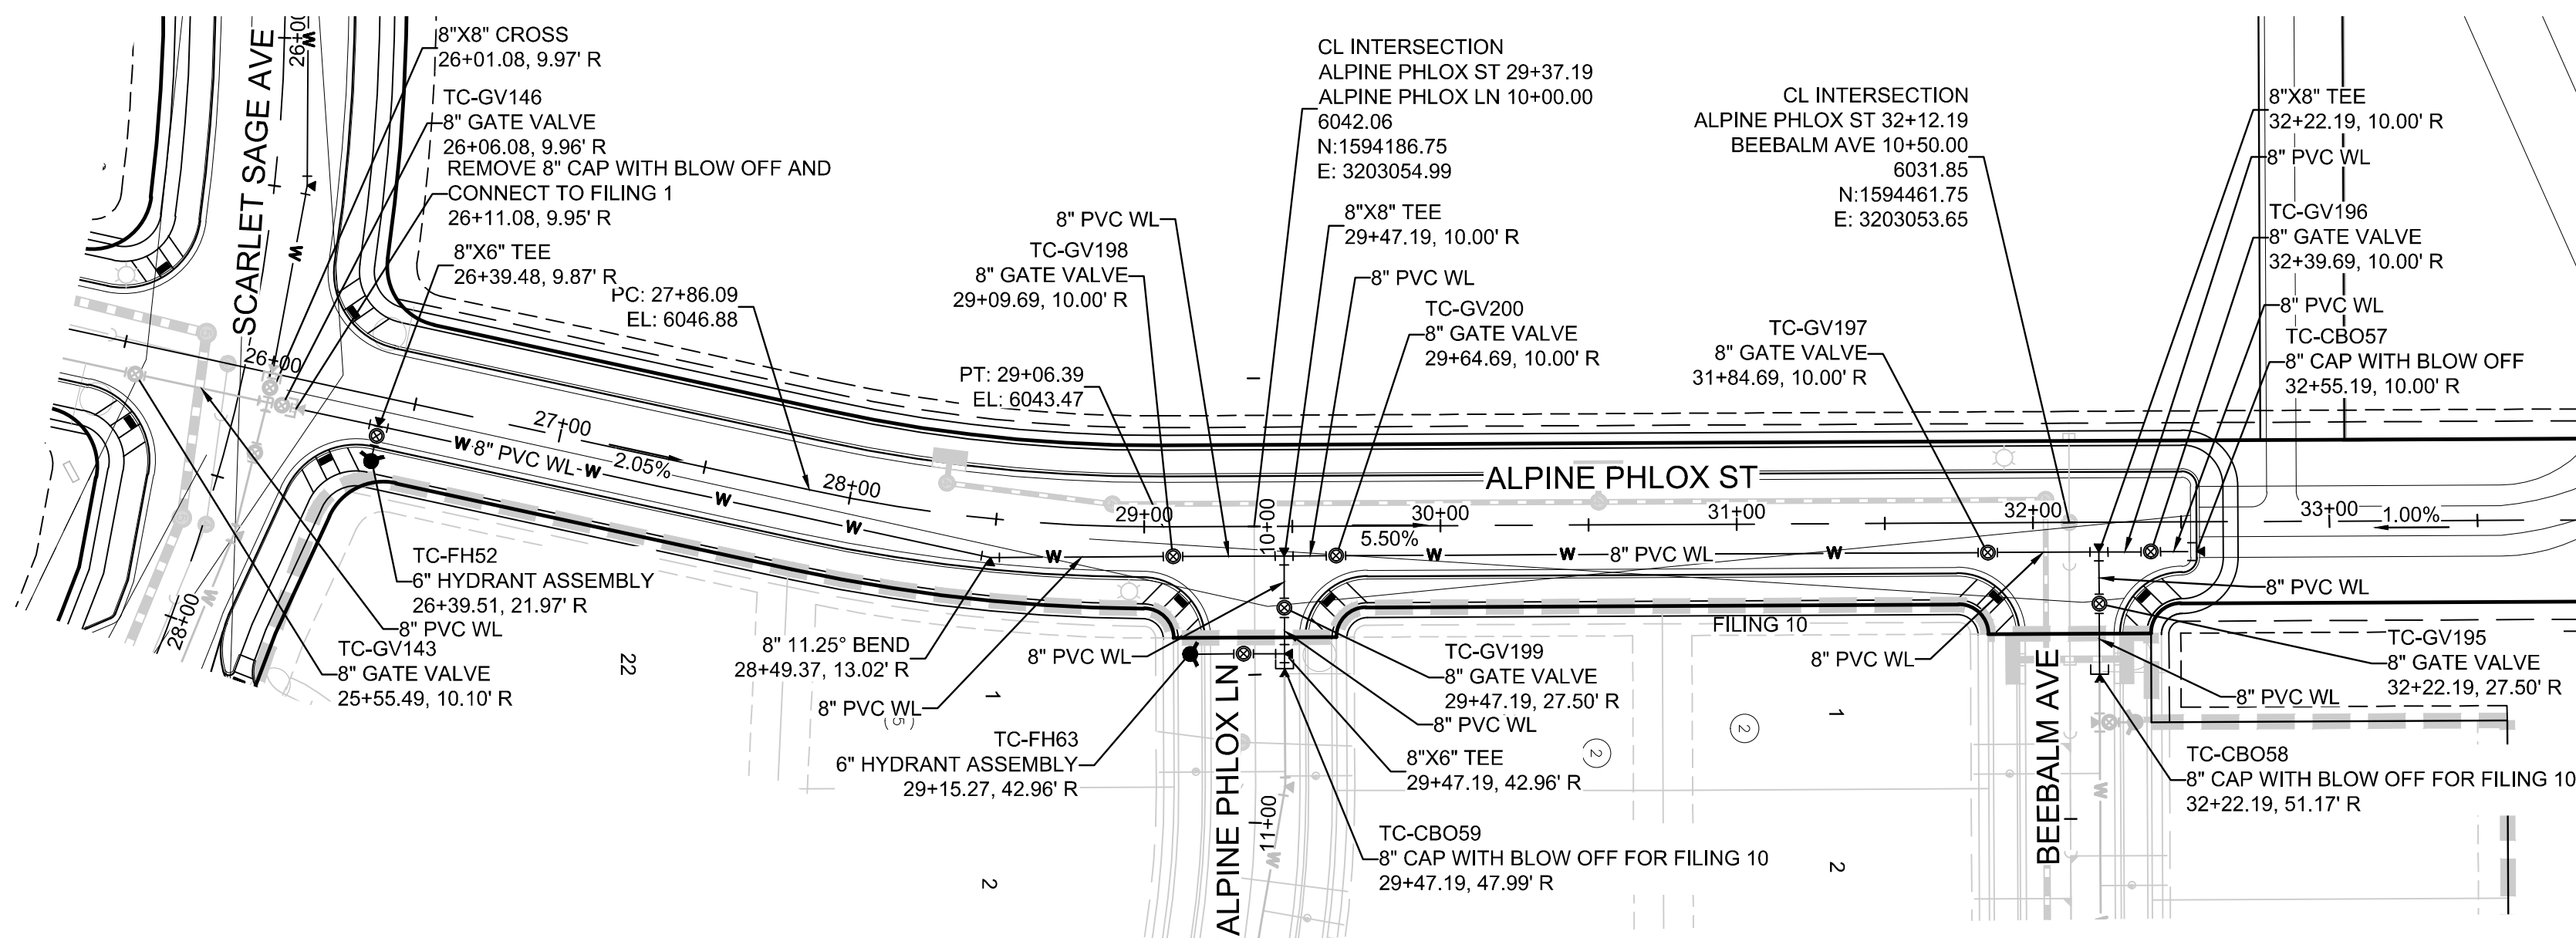

PLAN: ALPINE PHLOX ST STA: 25+50.00 TO 33+50.00
HORIZONTAL SCALE: 1" = 50'

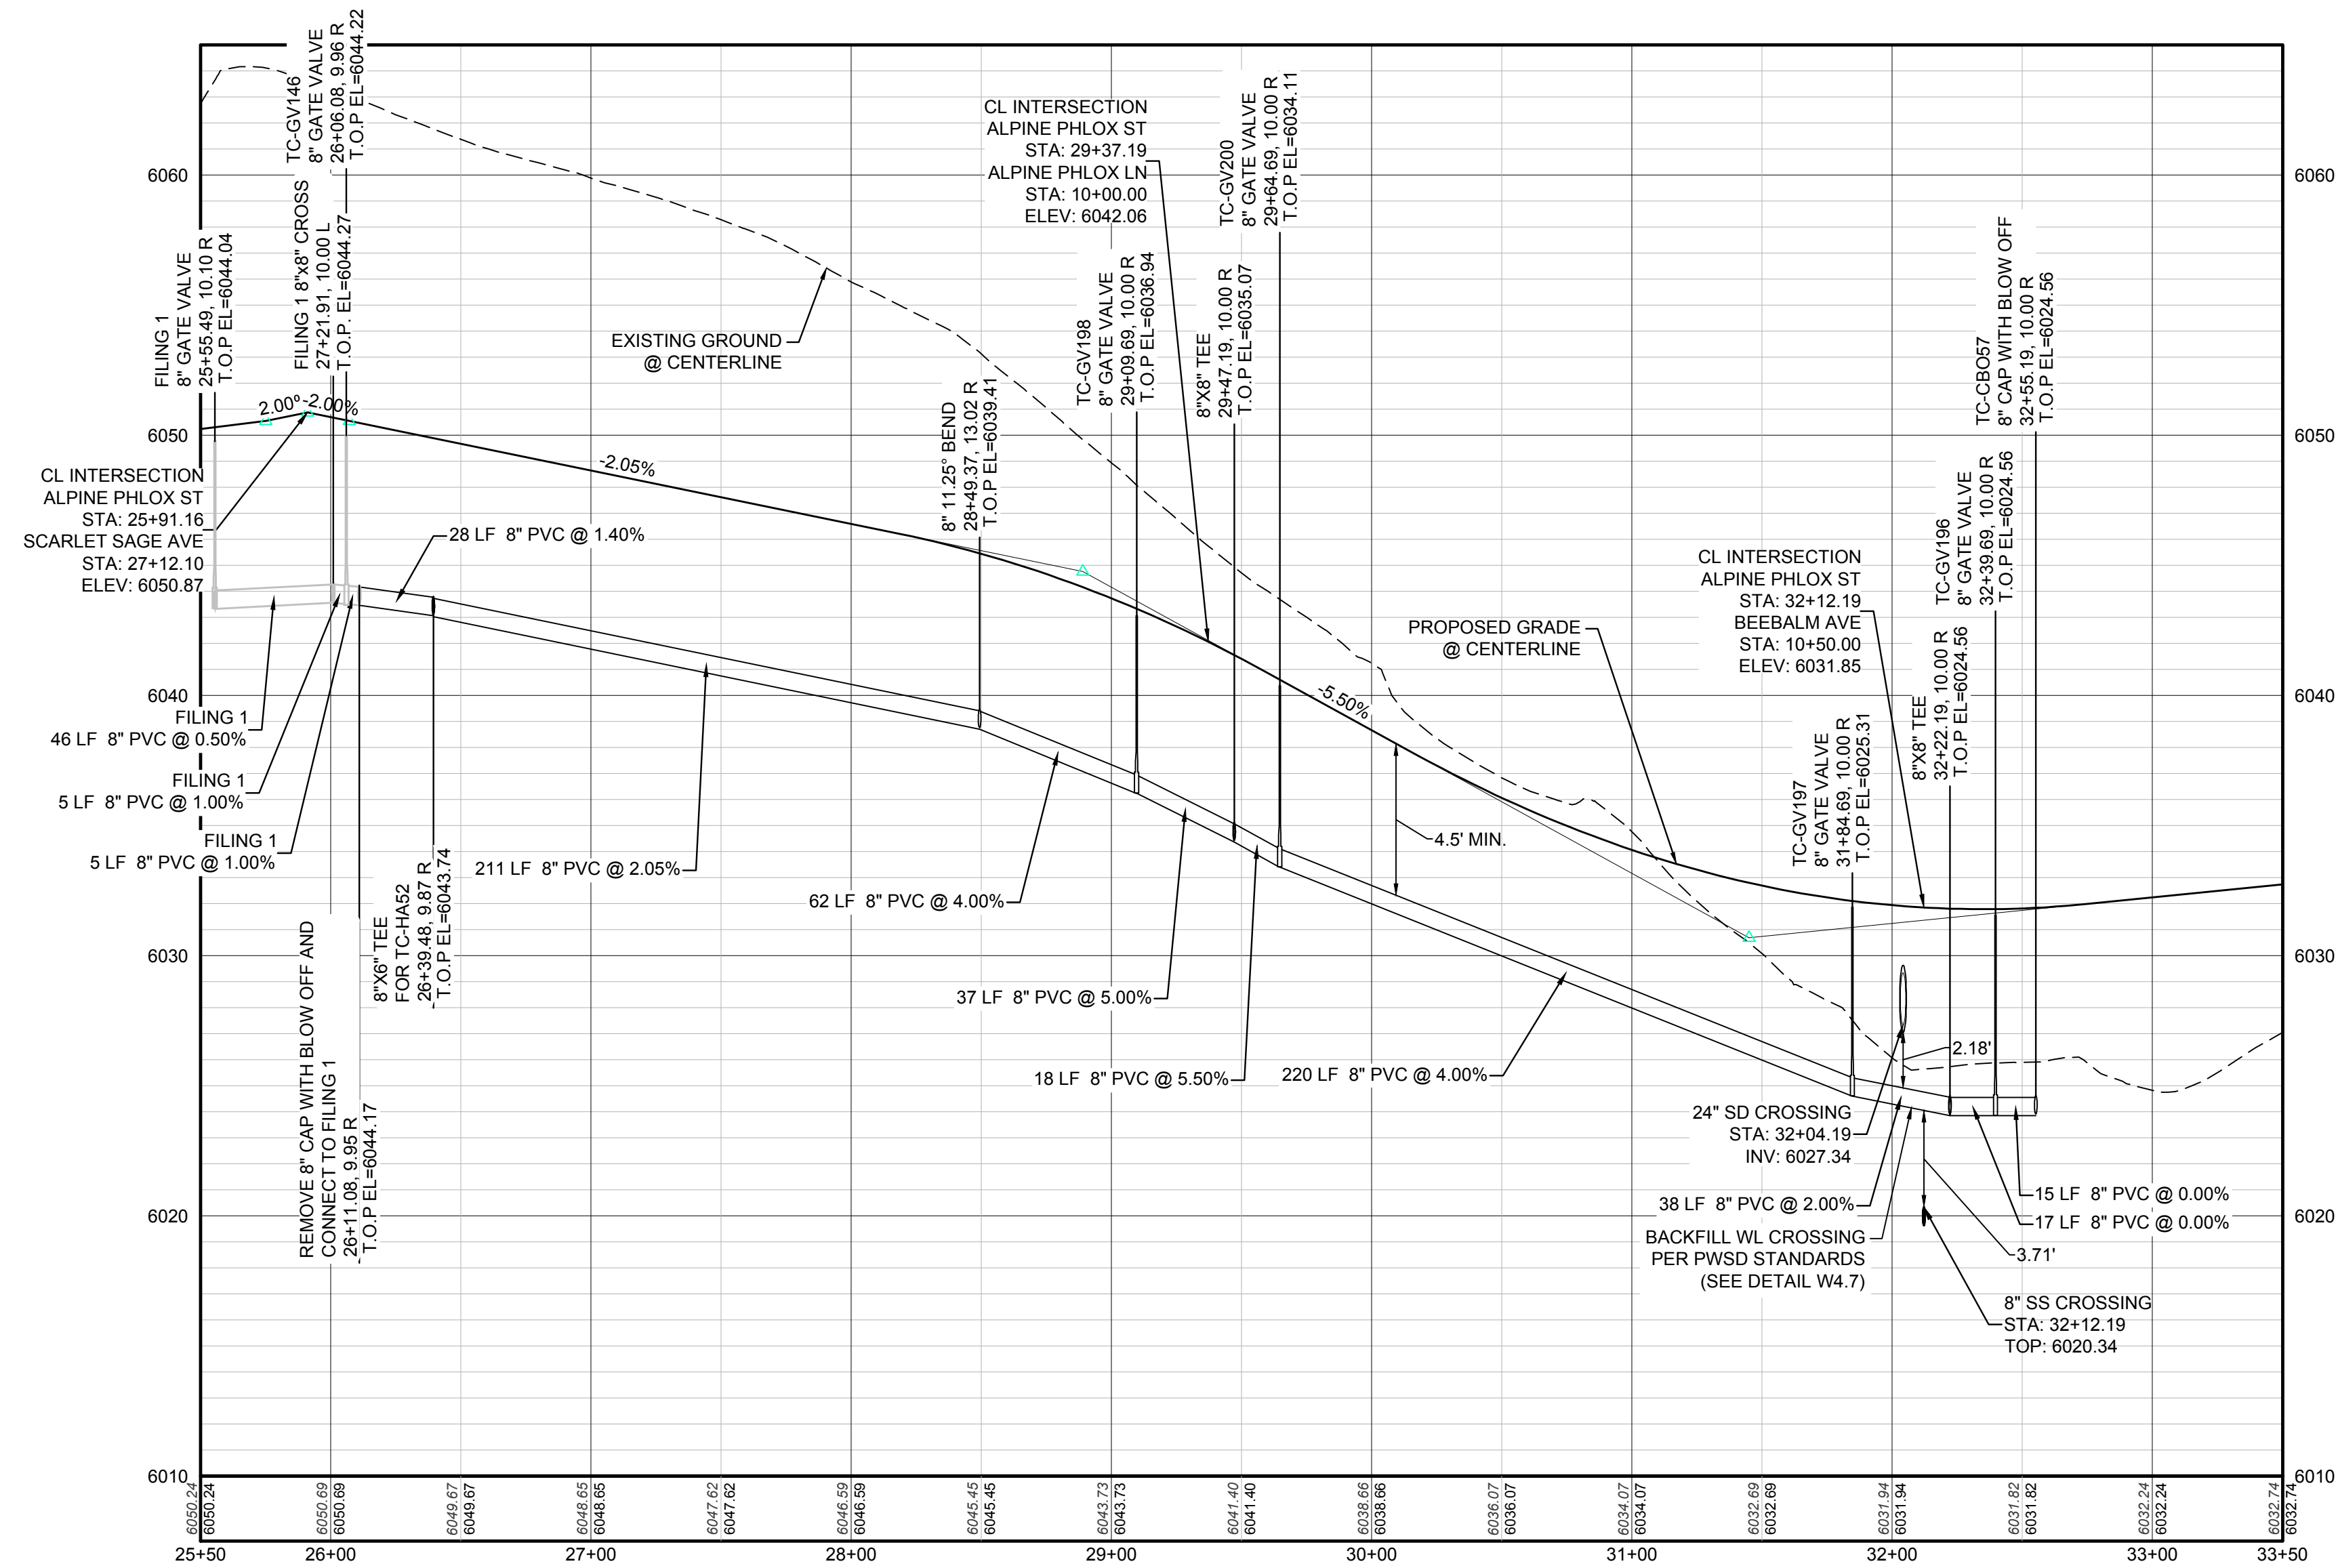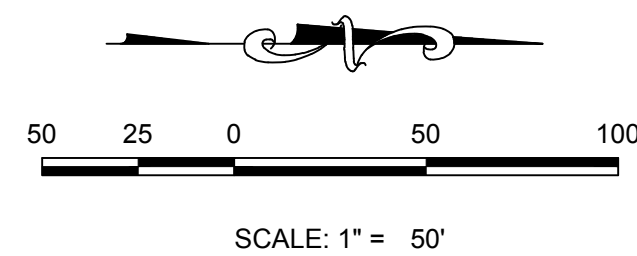


PROFILE: ALPINE PHLOX ST STA: 25+50.00 TO 33+50.00
HORIZONTAL: 1" = 50'
VERTICAL: 1" = 5'

BENCHMARK
DOUGLAS COUNTY CONTROL POINT KNOWN AS 1.060032, BEING A 3-1/4" ALUMINUM CAP, BEING LOCATED IN THE SOUTHWEST QUARTER OF SECTION 33, TOWNSHIP 6 SOUTH, RANGE 66 WEST OF THE SIXTH PRINCIPAL MERIDIAN, HAVING A PUBLISHED ELEVATION OF 1799.2870 METERS (5903.13 FEET) NAVD '88 DATUM.

BASIS OF BEARINGS:
THE EAST LINE OF THE NORTHEAST QUARTER OF SAID SECTION 9 BEING MONUMENTED AT THE NORTHEAST CORNER OF SAID SECTION 9 BY A 3-1/4" ALUMINUM CAP STAMPED LS 23053 AND AT THE EAST QUARTER CORNER OF SAID SECTION 9 BY A 2-1/2" ALUMINUM CAP STAMPED LS 6335 BEING CONSIDERED TO BEAR SOUTH 00°15'06" EAST, 2648.70 FEET.


PREPARED UNDER THE
SUPERVISION OF

BRIAN P. WILSON
COLORADO P.E. 0050067

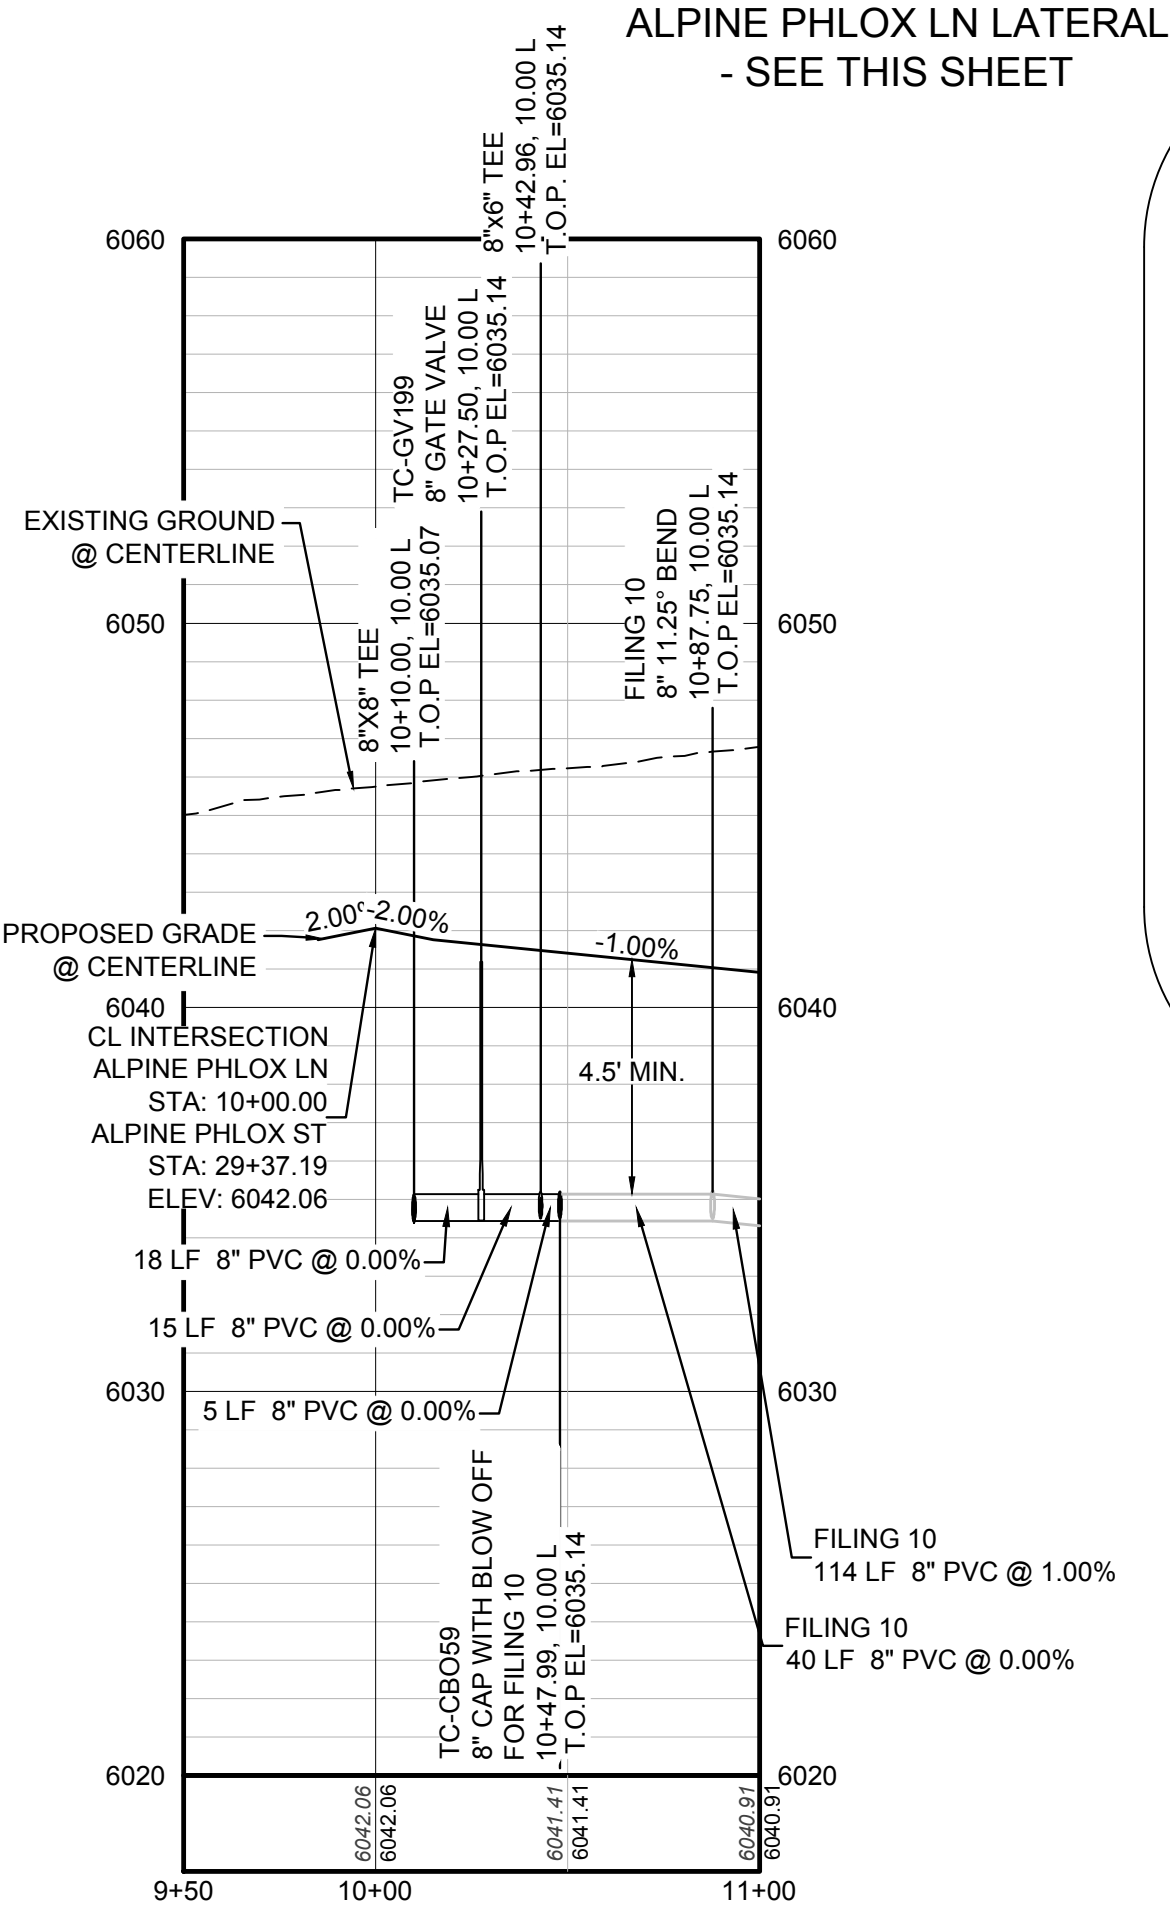


PROFILE: ALPINE PHLOX LN STA: 9+50.00 TO 11+00.00
HORIZONTAL: 1" = 50'
VERTICAL: 1" = 5'

BEEBALM AVE LATERAL -
SEE THIS SHEET

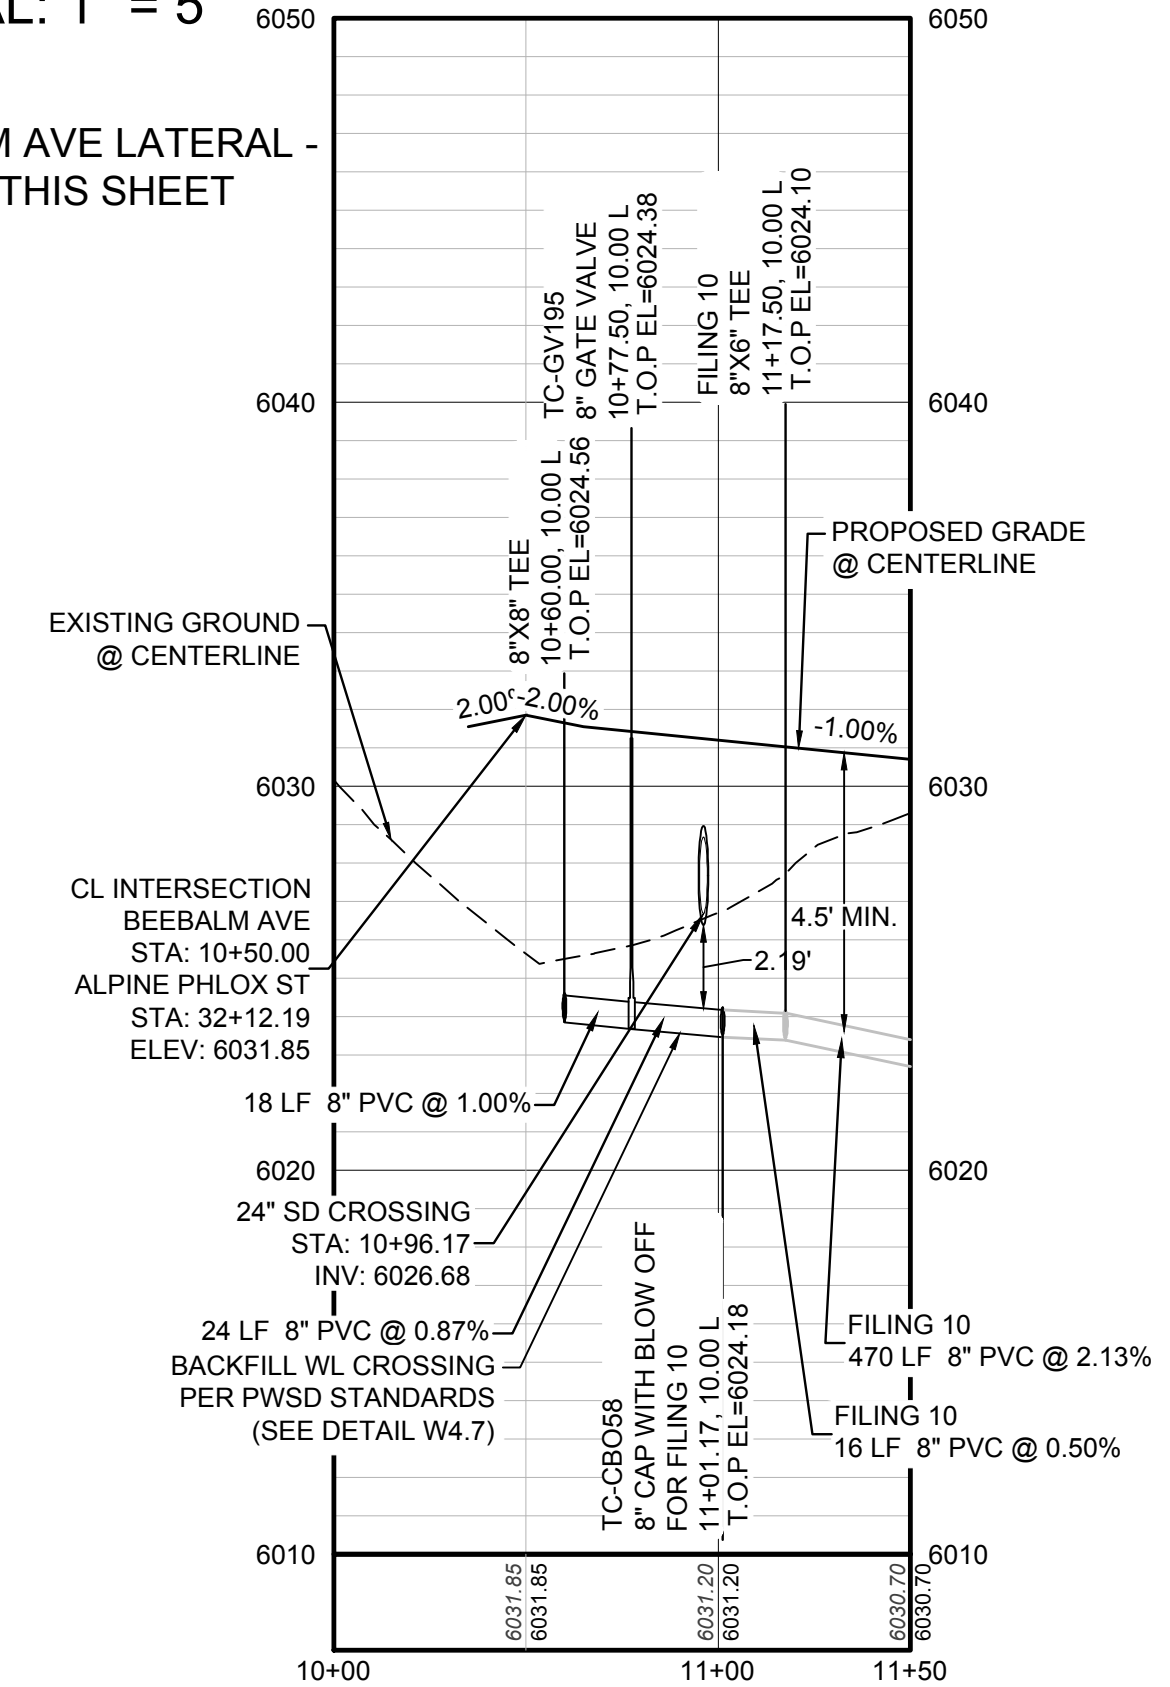

PROFILE: BEEBALM AVE STA: 10+00.00 TO 11+50.00
HORIZONTAL: 1" = 50'
VERTICAL: 1" = 5'

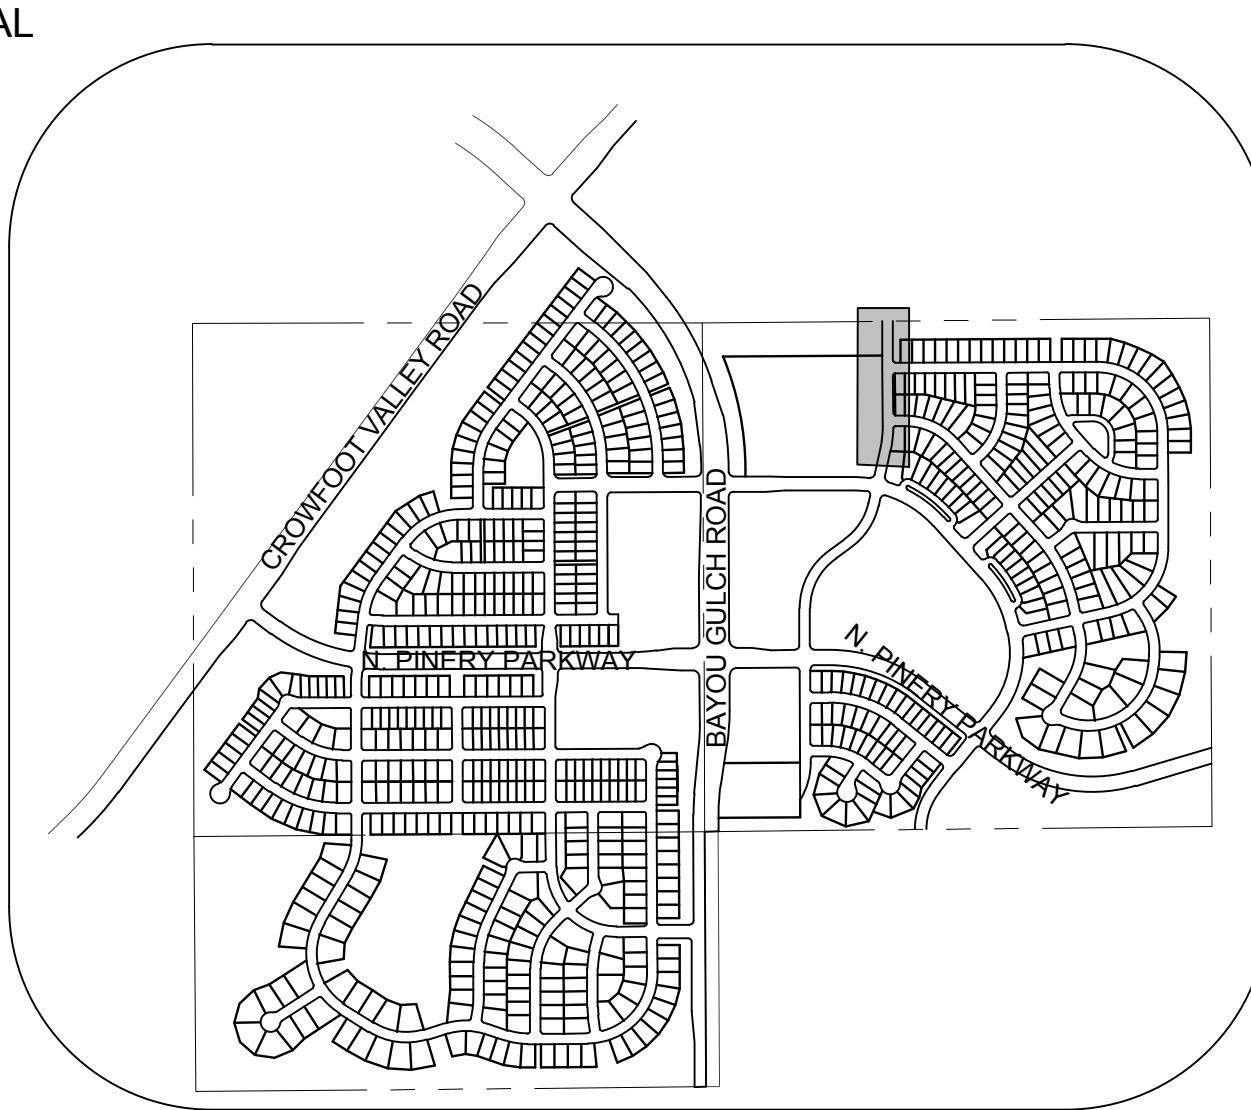


KEYMAP
N.T.S.
LEGEND

- | | |
|---|--------------------------------------|
| ② BLOCK NUMBER | △ PROPOSED RANGE POINT |
| Ⓐ LOT TYPE | --- CENTERLINE |
| 6 LOT NUMBER | --- RIGHT-OF-WAY |
| ⊗ PROPOSED BUTTERFLY VALVE | --- PROPERTY LINE |
| ⌋ PROPOSED CAP WITH END OF LINE BLOWOFF | --- EDGE OF PAVEMENT |
| ⌋ PROPOSED REDUCER | → PROPOSED DIRECTION OF FLOW |
| ⊗ PROPOSED VALVE | 1.0% PROPOSED SLOPE & DIRECTION |
| ⌋ PROPOSED FIRE HYDRANT | --- EXISTING 5' CONTOUR |
| ⌋ PROPOSED WL FITTING WITH THRUST BLOCK | --- EXISTING 1' CONTOUR |
| ⌋ PROPOSED FLARED END SECTION | --- PROPOSED 5' CONTOUR |
| ⊗ PROPOSED LOW POINT BLOW-OFF | --- PROPOSED 1' CONTOUR |
| ⊗ PROPOSED AIR VALVE | --- PROPOSED STORM DRAIN |
| ⊗ FUTURE PHASE VALVE | --- PROPOSED SEWER LINE WITH MANHOLE |
| ⊗ FUTURE FIRE HYDRANT | --- PROPOSED SEWER LATERAL |
| ⊗ PROPOSED LIGHT POLE | --- PROPOSED WATER LINE |
| ⌋ PROPOSED SIDEWALK | --- PROPOSED WATER LATERAL W/ METER |
| ⌋ PROPOSED SIDEWALK RAMP | --- SECTION LINE |
| 10.00 EXISTING ELEVATION | --- FILING BOUNDARY |
| 10.00 PROPOSED DESIGN ELEVATION | --- FO EXISTING FIBER OPTIC LINE |
| ⊗ PROPOSED STORM DRAIN INLET | --- OH EXISTING OVERHEAD POWER |
| ⊗ PROPOSED STORM DRAIN MANHOLE | --- TEL EXISTING TELEPHONE LINE |

ABBREVIATIONS

- | | |
|----------------------------|--------------------------------------|
| AD ANGLE DIFFERENCE | MH MANHOLE |
| AV AIR VAC RELEASE VALVE | N.T.S. NOT TO SCALE |
| BVC BEGIN VERTICAL CURVE | PVC POLYVINYL CHLORIDE |
| BVP BEGIN VERTICAL PROFILE | PVI PT. OF VERTICAL INTERSECTION |
| CBO CAP WITH BLOW OFF | PVT POINT OF VERTICAL TANGENT |
| CRR CURB RETURN RADIUS | RCBC REINFORCED CONCRETE BOX CULVERT |
| EL ELEVATION | RCP REINFORCED CONCRETE PIPE |
| EP EDGE OF PAVEMENT | ROW RIGHT OF WAY |
| EVC END VERTICAL CURVE | SC SANITARY CAP |
| EVP END VERTICAL PROFILE | SD STORM DRAIN |
| FG FINISHED GROUND | SL SECTION LINE |
| FH FIRE HYDRANT | SS SANITARY SEWER |
| FL FLOW LINE | STA STATION |
| GV GATE VALVE | T.O.P. TOP OF PIPE |
| HCR HANDICAP CURB RAMP | UE UTILITY EASEMENT |
| HP HIGH POINT | VC VERTICAL CURVE |
| INV INVERT | WL WATER LINE |
| K CURVATURE COEFFICIENT | WLC WATER LINE CONNECTION |
| LF LINEAR FEET | WSE WATER SURFACE ELEVATION |

10333 E. Dry Creek Rd.
Suite 110
Englewood, CO 80110
Tel: (720) 482-9526
Fax: (720) 482-9548

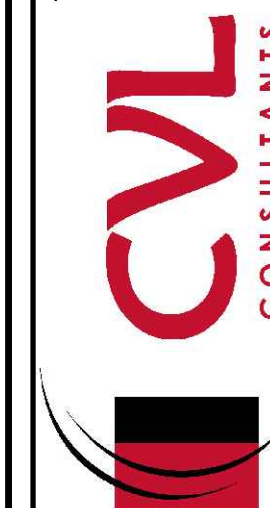

HR 935 LLC
7353 South Alton Way
CENTENNIAL, CO 80112

TRAILS AT CROWFOOT
FILING 9 CONSTRUCTION DRAWINGS
WATER PLAN & PROFILE
ALPINE PHLOX STREET

SCALE: AS SHOWN
DRAWN BY: RHR
CHECKED BY: JJJ
FILE NO: 8130283701
DATE: MAY 2017

SHEET NUMBER
19

CALL 811
TWO WORKING DAYS
BEFORE YOU DIG
UNCC 1-800-922-1987
UTILITY NOTIFICATION
CENTER OF COLORADO

N:\PROJECTS\SSR\BANCOC\ENGINEERING\SSR\BANCOC\DWG\DWG\2262018\6.30 PM

INSPECTION POLICY:

1. ALL SERVICE INSPECTIONS MUST BE SCHEDULED AT LEAST 24 HOURS IN ADVANCE OF THE REQUESTED INSPECTION.
2. SERVICE INSPECTIONS WILL OCCUR BETWEEN 1:00 P.M. AND 3:00 P.M. SPECIFIC INSPECTION TIMES ARE NOT AVAILABLE.
3. IF THE CONTRACTOR IS NOT READY FOR INSPECTION WHEN THE INSPECTOR ARRIVES AT THE SITE OR SERVICE FAILS, A RE-INSPECTION WILL HAVE TO BE SCHEDULED IN ACCORDANCE WITH NOTES 1 AND 2 ABOVE AND A RE-INSPECTION FEE CHARGED.
4. SHOULD THE SERVICE LINES BE DAMAGED BY LATER CONSTRUCTION, AN INSPECTION OF THE REPAIR WILL BE REQUIRED IN ACCORDANCE WITH NOTES 1 AND 2 ABOVE.
5. THE CONTRACTOR SHALL LEAVE ALL PIPE AND FITTINGS EXPOSED FOR THE INSPECTOR TO OBSERVE. INSPECTORS WILL NOT ENTER ANY EXCAVATIONS TO CHECK MATERIALS. THE TOP LAYER OF BEDDING CAN BE ADDED AFTER THE INSPECTION HAS BEEN COMPLETED.
6. ALL EXCAVATIONS SHALL BE IN ACCORDANCE WITH OSHA STANDARDS.
7. LOTS WITHOUT BUILDING ADDRESSES BEFORE DISTRICT INSPECTION OR METER SET WILL FAIL AUTOMATICALLY.
8. CONTRACTOR MUST BE PRESENT AT TIME OF INSPECTION, UNLESS COORDINATED WITH DISTRICT INSPECTOR.

INSTALLATION NOTES:

WATER

1. ACCEPTABLE PIPE MATERIALS SHALL BE K-COPPER TUBING. (3/4" MIN.)
2. APPROVED BEDDING TO BE SQUEEGEE.
3. ONLY ONE COUPLING WILL BE ALLOWED BETWEEN THE SUB-IN AND BUILDING. COMPRESSION COUPLINGS WILL NOT BE ALLOWED ON NEW CONSTRUCTION. SILVER SOLDERED JOINTS MUST BE USED ON SERVICES LARGER THAN 3/4". SILVER SOLDERED JOINTS MUST BE INSPECTED BY PWSD PRIOR TO BURIAL. FLARED COUPLINGS WILL BE ALLOWED ON ALL SERVICES 3/4" AND SMALLER.
4. A WATER SERVICE WHICH CROSSES A SEWER SERVICE CAN DO SO ONLY AT A 45-90° ANGLE. WATER SERVICES SHALL BE LOCATED A MINIMUM OF 18" ABOVE SEWER SERVICE.
5. WATER SERVICE FOUNDATION PENETRATIONS SHALL BE WATERPROOFED USING MASTIC OR OTHER APPROVED METHOD. CRAWL SPACE REQUIRES CONTINUOUS COPPER WITH A 1" BURY.
6. CURB STOP MUST BE PLUMB AND CENTERED OVER THE NUT. IT SHOULD BE STRAPPED TO THE METER PIT (RESIDENTIAL INSTALLATIONS) OR CENTERED OVER THE EASEMENT LINE (COMMERCIAL INSTALLATIONS). THE ASSEMBLY MUST BE AT OR SLIGHTLY ABOVE FINISHED GRADE.
7. MOVED CURB BOXES MUST BE INSPECTED BY PWSD PRIOR TO BURIAL.
8. WATERLINE MUST BE ATTACHED TO A SUPPORT BOARD THAT IS MOUNTED TO THE WALL.
9. NO VOIDS ALLOWED UNDER WATERLINES FROM STOP BOX TO FOUNDATION.
10. CURBSTOP BOXES AND METER PITS CANNOT BE IN DRIVEWAYS.
11. ONLY 3/4" (JUMPER) PIPES (RESIDENCES) ARE ALLOWED. (JUMPER) PIPES WILL BE REMOVED PRIOR TO METER SET DATE.
12. ALL SERVICES WILL BE PERMANENTLY MARKED ON CURB FACE AS FOLLOWS:
"X" FOR SANITARY SEWER SERVICE
"Y" FOR WATER SERVICES
13. NO SPLICES OR FLARED COUPLINGS ALLOWED ON SERVICES LARGER THAN 3/4". SILVER SOLDERED JOINTS MUST BE INSPECTED BY PWSD PRIOR TO BURIAL. FLARED COUPLINGS WILL BE ALLOWED ON ALL SERVICES 3/4" AND SMALLER.

PARKER WATER & SANITATION DISTRICT

NOTES FOR WATER SERVICES

SCALE: NONE	DATE: 2/96
APPROVED: 1/04	
PVR	1/16
DIRECTOR OF ENGINEERING	10/16

2016 REVISION

SHEET W1.1

TYPICAL SERVICES PLAN VIEW

NTS

TYPICAL SERVICES SECTION

NTS

NOTE:

1. SEE SHEET W1.1 FOR DISTRICT POLICIES AND INSTALLATION NOTES.
2. REFER TO SEWER SERVICES DETAIL SHEET S1.2.
3. 4" PVC SLEEVES REQUIRED FOR SERVICE LINES UNDER CONCRETE SURFACE.

PARKER WATER & SANITATION DISTRICT

TYPICAL WATER SERVICES

SCALE: NONE	DATE: 2/96
APPROVED: 1/04	10/16
PVR	12/07
DIRECTOR OF ENGINEERING	1/16

2016 REVISION

SHEET W1.2

TYPICAL PLAN

NTS

NOTES:

1. SEE "TYPICAL STREET CROSS SECTION - TYPICAL STREET Q PROFILE" DRAWING.
2. ALL FIRE HYDRANTS TO BE LOCATED AT POINTS OTHER THAN CORNER INTERSECTIONS SHALL BE INSTALLED AT A LOT LINE EXTENDED.

PARKER WATER & SANITATION DISTRICT

WATER DISTRIBUTION SYSTEM

TYPICAL PLAN

SCALE: NONE	DATE: 2/96
APPROVED: 1/16	
PVR	10/16
DIRECTOR OF ENGINEERING	

2016 REVISION

SHEET W2.1

TYPICAL STREET CROSS SECTION

NTS

TYPICAL STREET Q PROFILE

NTS

PARKER WATER & SANITATION DISTRICT

TYPICAL STREET CROSS SECTION

TYPICAL STREET Q PROFILE

SCALE: NONE	DATE: 2/96
APPROVED: 1/16	
PVR	10/16
DIRECTOR OF ENGINEERING	

2016 REVISION

SHEET W2.2

TYPICAL PLAN FOR CURVED STREETS

NTS

PARKER WATER & SANITATION DISTRICT

WATER DISTRIBUTION SYSTEM

TYPICAL PLAN FOR CURVED STREETS

SCALE: NONE	DATE: 2/96
APPROVED: 1/16	
PVR	10/16
DIRECTOR OF ENGINEERING	

2016 REVISION

SHEET W2.3

TYPICAL PLAN FOR CUL-DE-SACS

NTS

PARKER WATER & SANITATION DISTRICT

WATER DISTRIBUTION SYSTEM

TYPICAL PLAN FOR CUL-DE-SACS

SCALE: NONE	DATE: 2/96
APPROVED: 1/16	
PVR	10/16
DIRECTOR OF ENGINEERING	

2016 REVISION

SHEET W2.4

PREFERRED FIRE HYDRANT LOCATION

NTS

NOTES:

1. ALTERNATE TO THE ABOVE: FASTEN PL. VALVE DIRECTLY TO A PL. ANCHOR THE VALVE SHALL BE CALLED "VALVE 1".
2. NO HORIZONTAL OR VERTICAL BENDS ARE ALLOWED IN FIRE HYDRANT BRANCH.
3. NO PORTION OF FIRE HYDRANT MAY
4. FIRE HYDRANT EXTENSIONS MAY NOT BE MORE THAN 6" MAX. AREA.

PARKER WATER & SANITATION DISTRICT

FIRE HYDRANTS

LOCATION & INSTALLATION

SCALE: NONE	DATE: 2/96
APPROVED: 4/01	10/16
PVR	05/02
DIRECTOR OF ENGINEERING	10/27

2016 REVISION

SHEET W2.5

PIPE LOCATION SYSTEM

NTS

PLAN

NTS

SECTION VIEW @ FIRE HYDRANT

NTS

NOTES:

1. FOR USE IN ALL DUTILE SOON AND PVE WATER MAINS.
2. LOCATOR STATION POSITION MAY BE MODIFIED AT THE DIRECTION OF THE DISTRICT ENGINEER.
3. A CONTINUITY TEST WILL BE REQUIRED PRIOR TO PERMANENTLY ACCEPTANCE.

PARKER WATER & SANITATION DISTRICT









LOCATOR WIRE DETAILS

SCALE: NONE	DATE: 2/96
APPROVED: 4/01	
PVR	05/02
DIRECTOR OF ENGINEERING	10/16

2016 REVISION

SHEET W2.6

N:\PROJECTS\BENCH\ENGINEERING\NO. SHEET SET\CD\DWG\WATER AND SANITATION\PIPING\DETAILS\DWG. CDDVA. 2/26/2018 6:30 PM

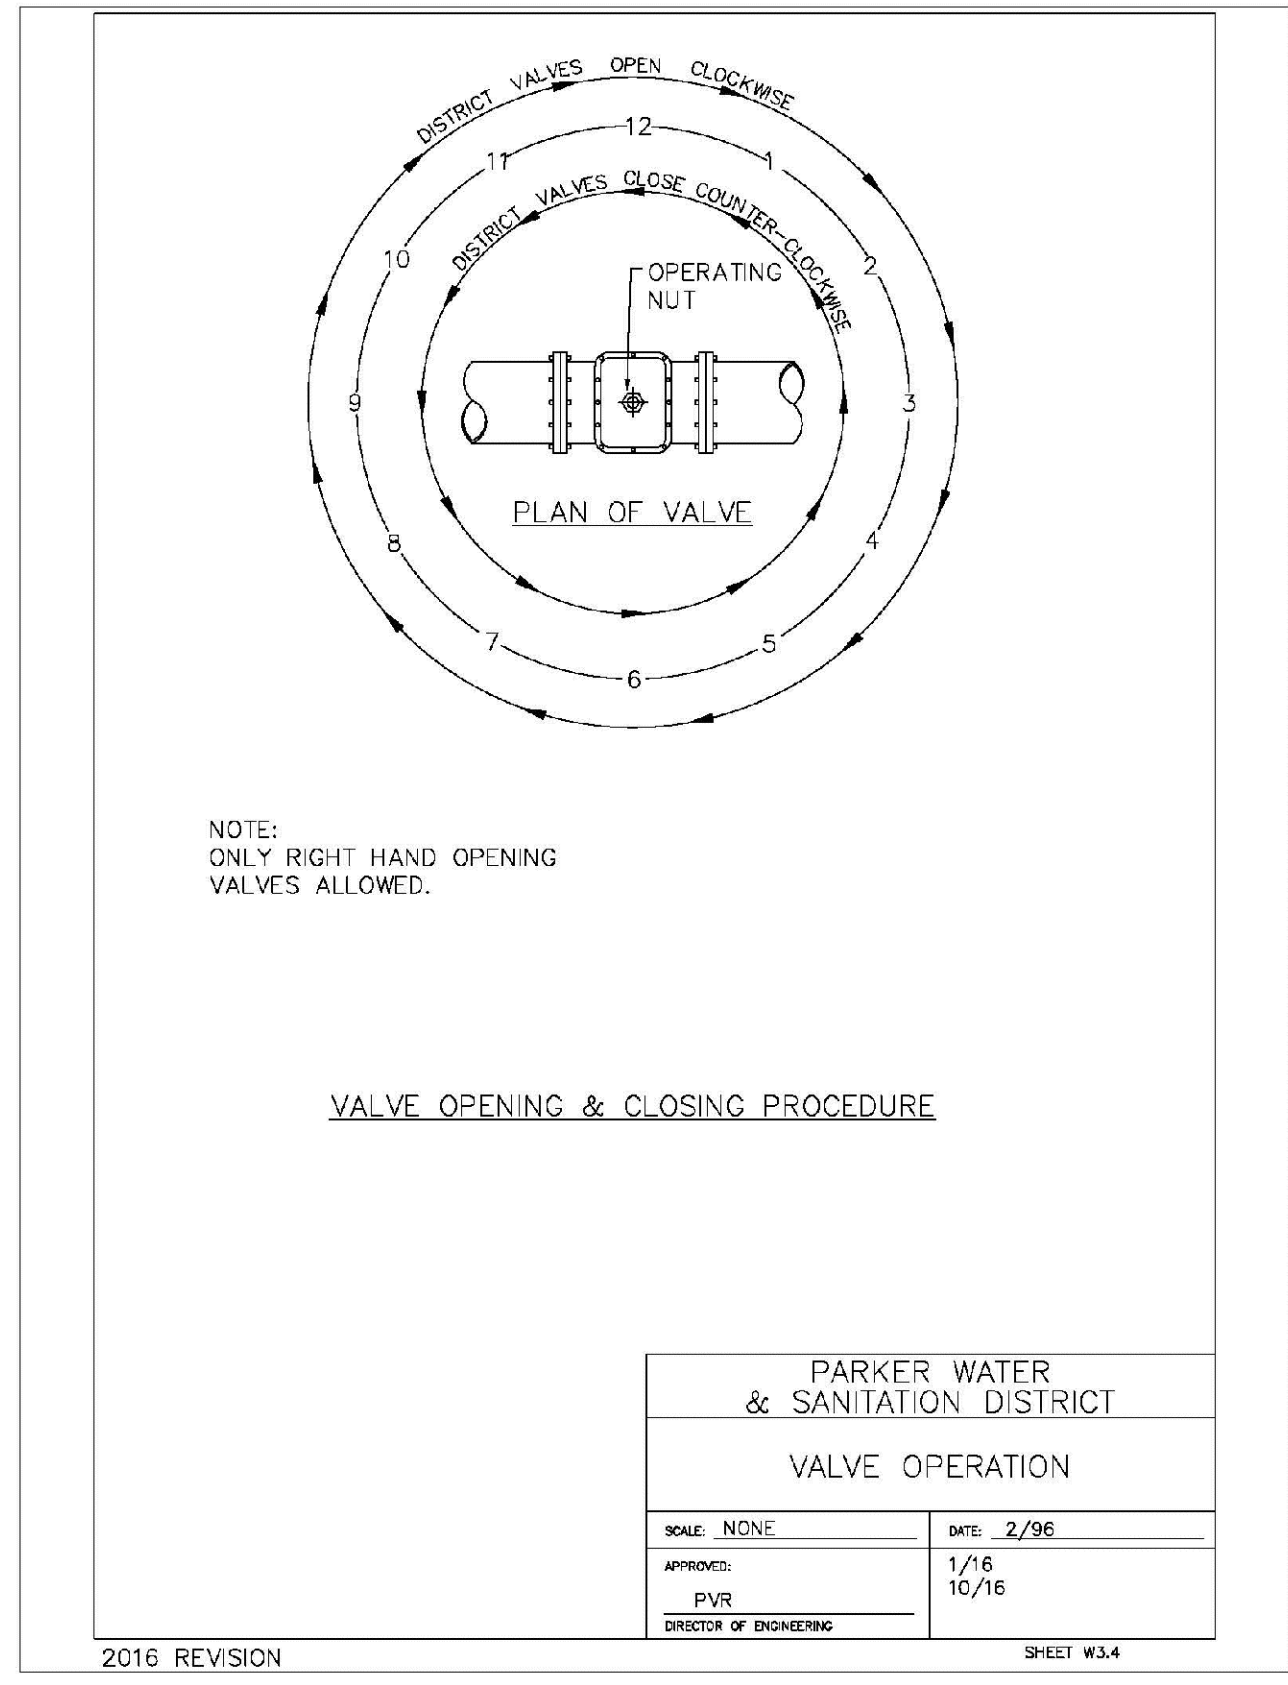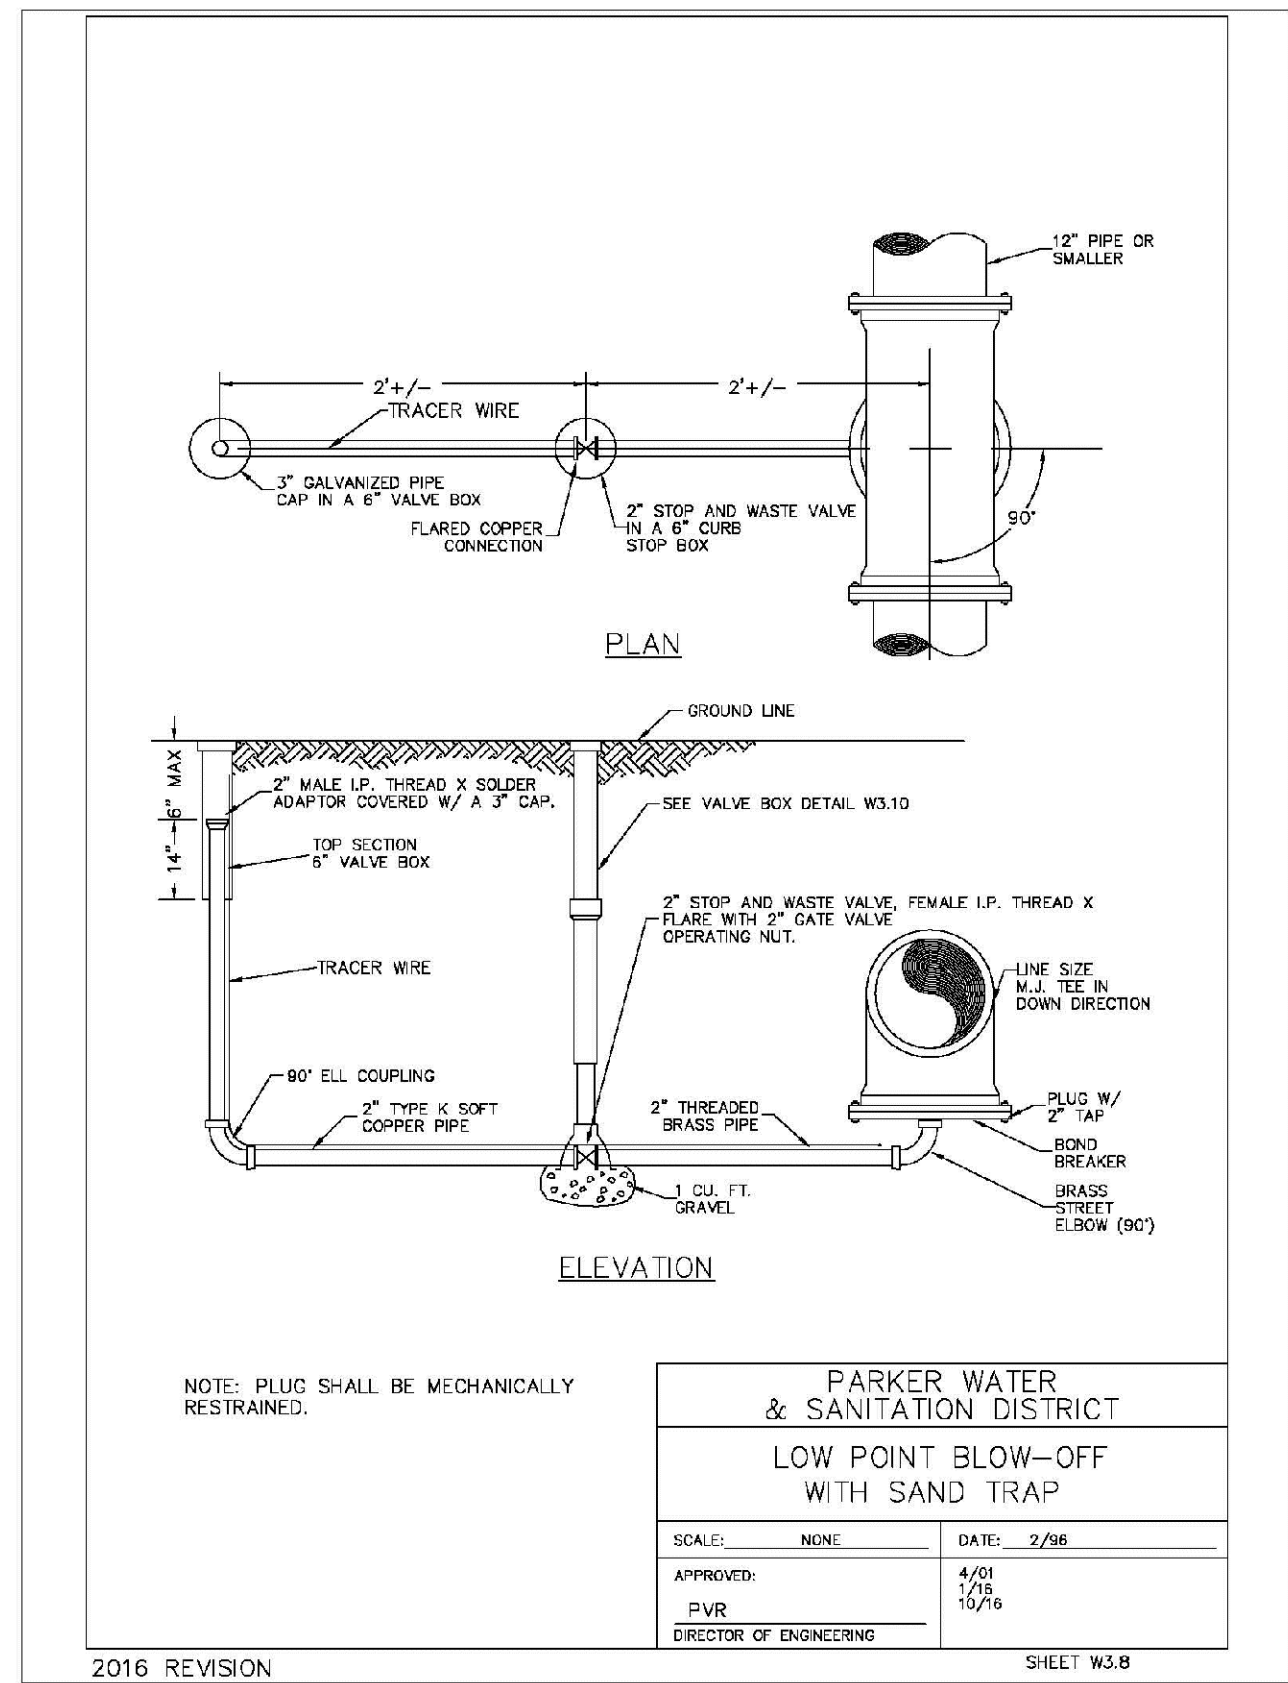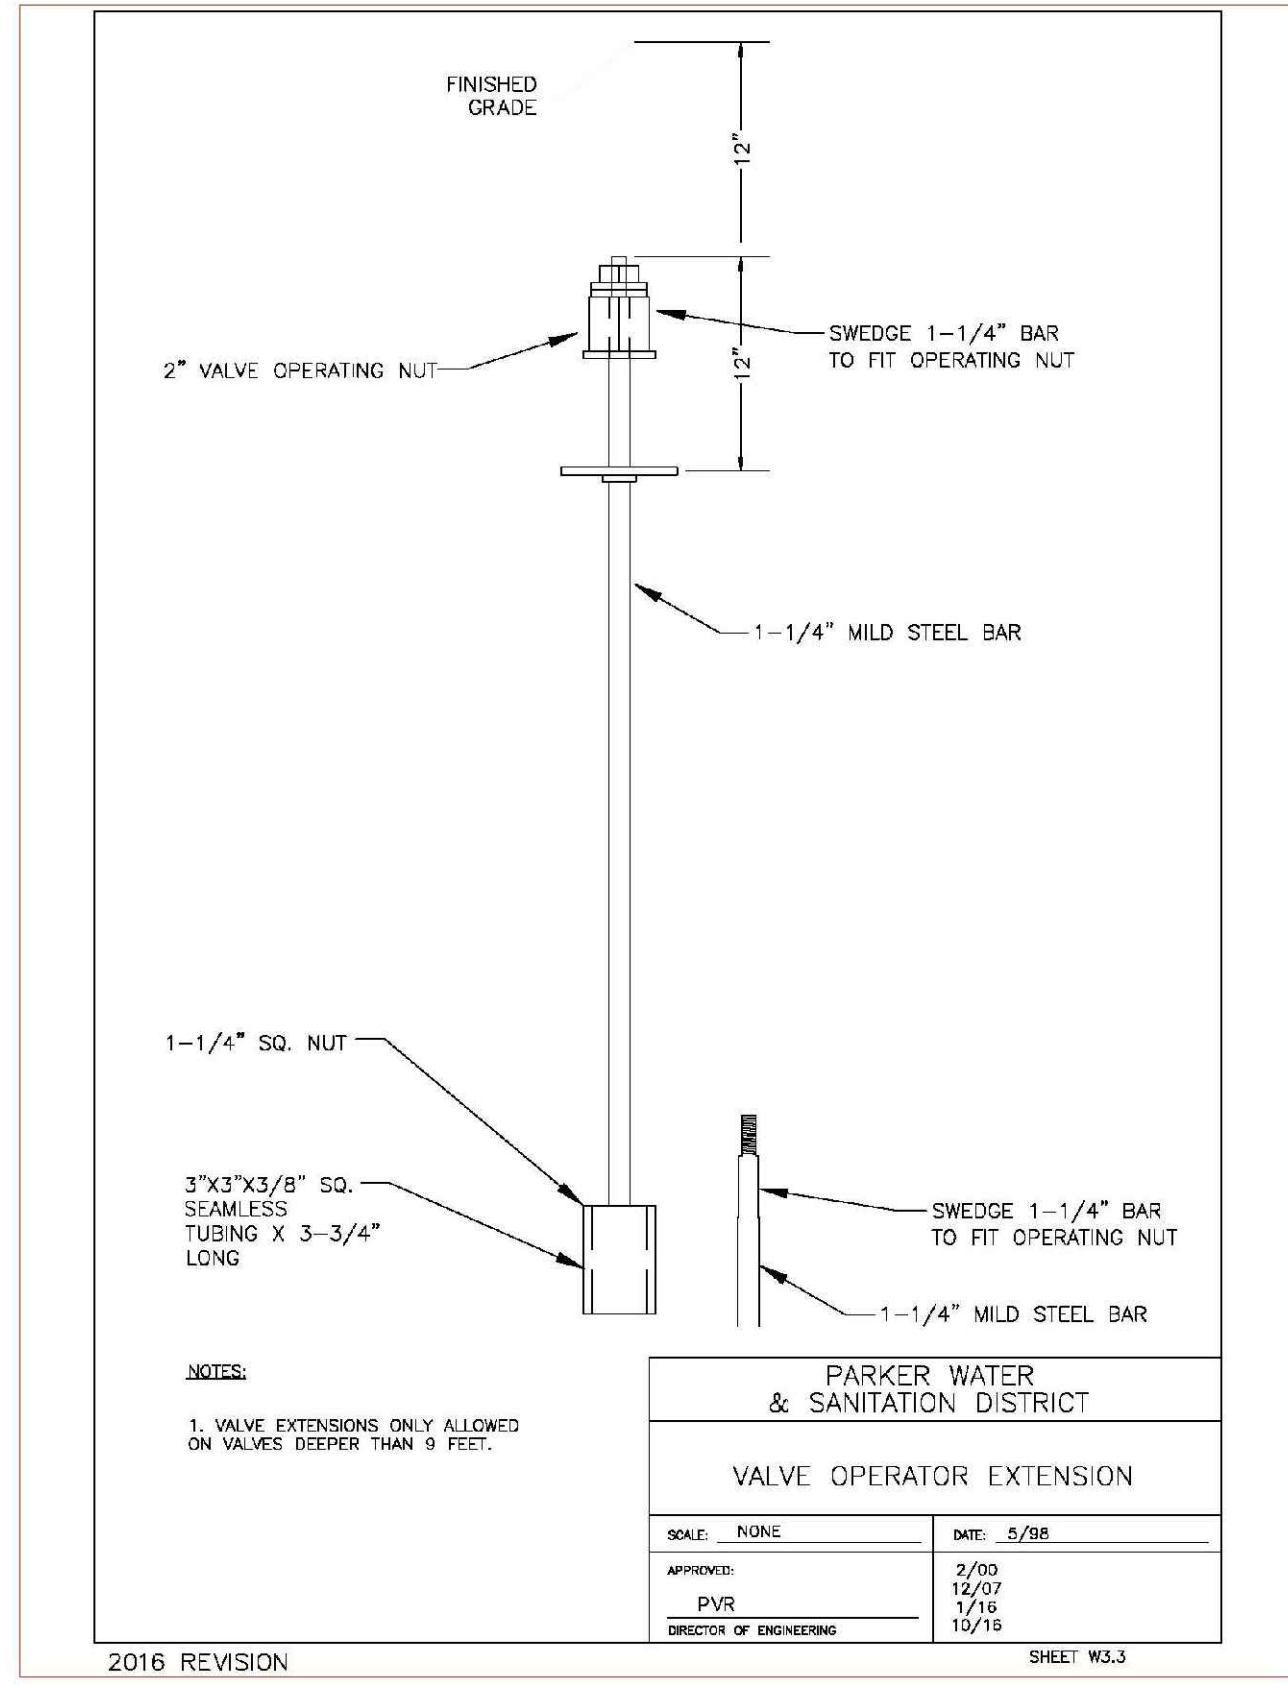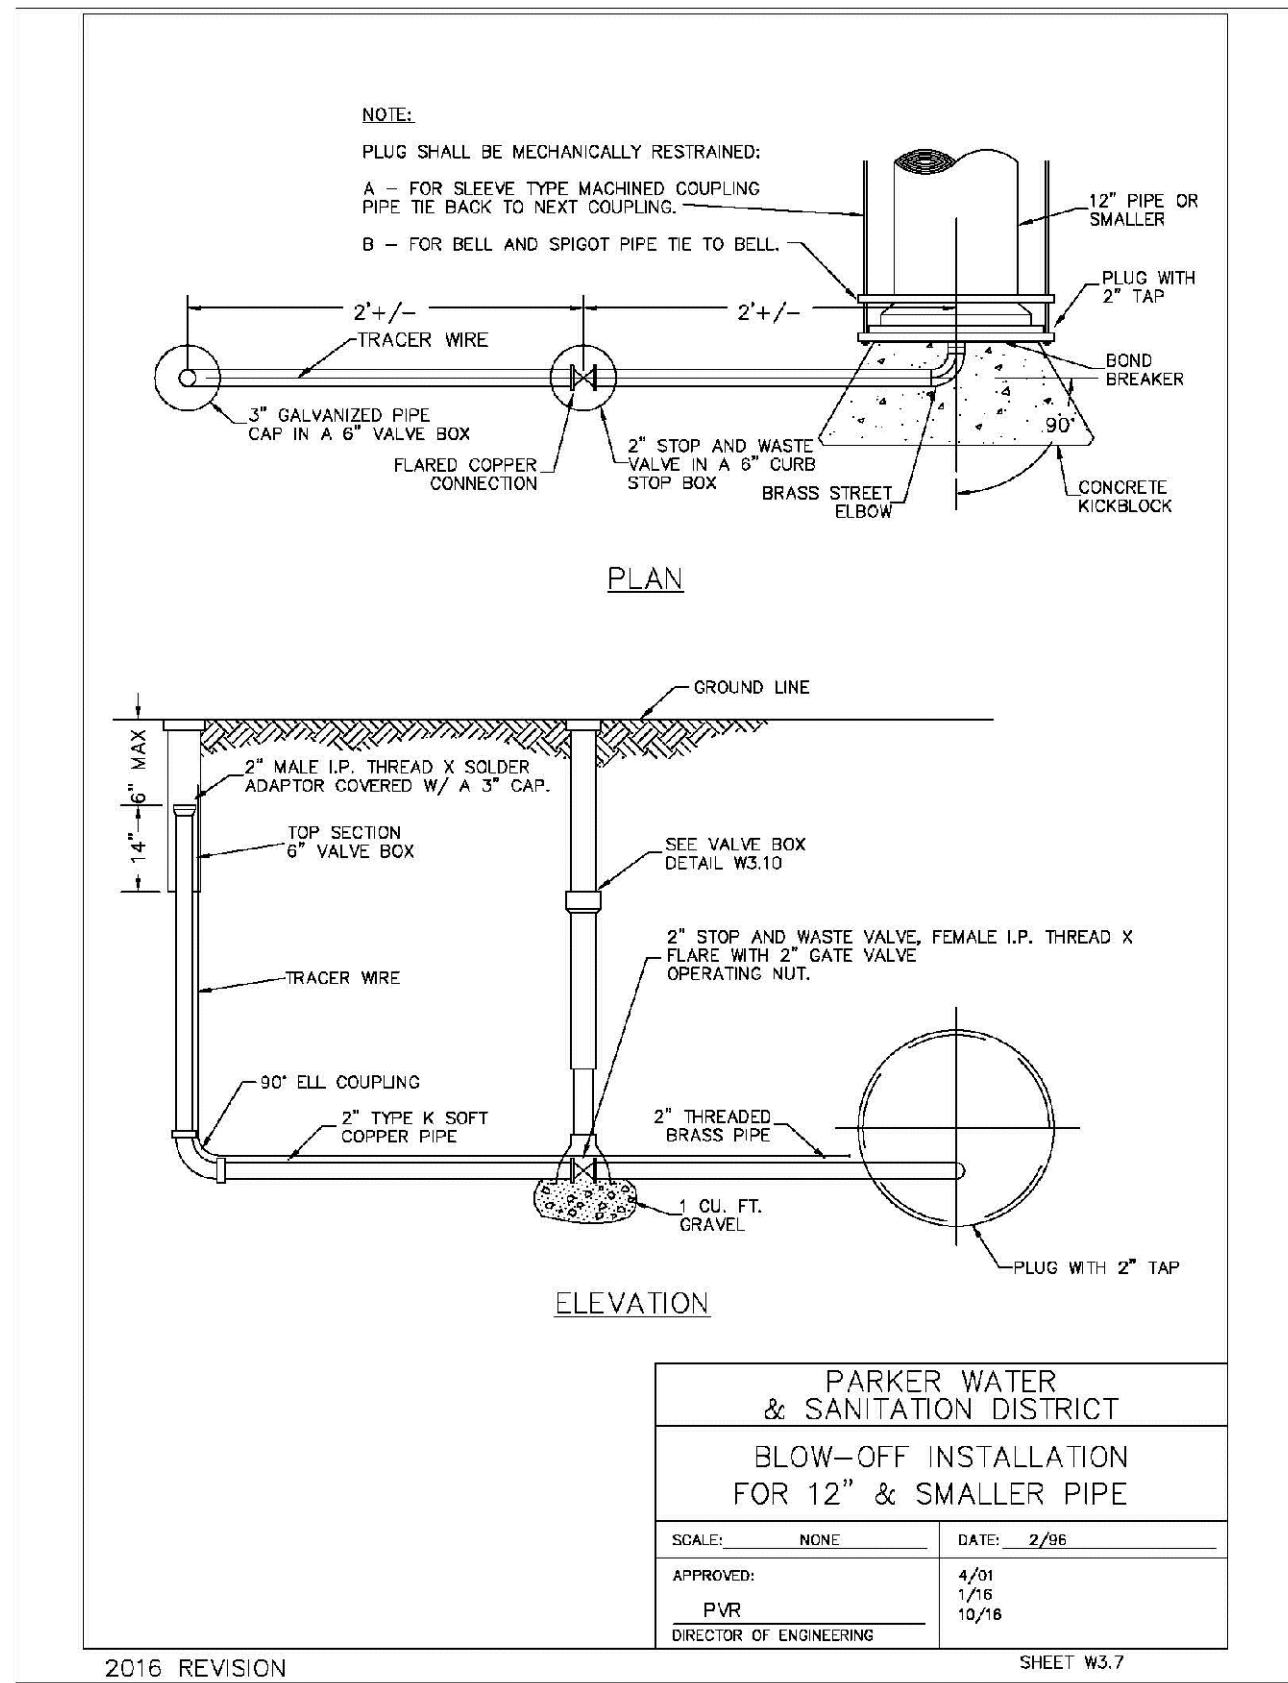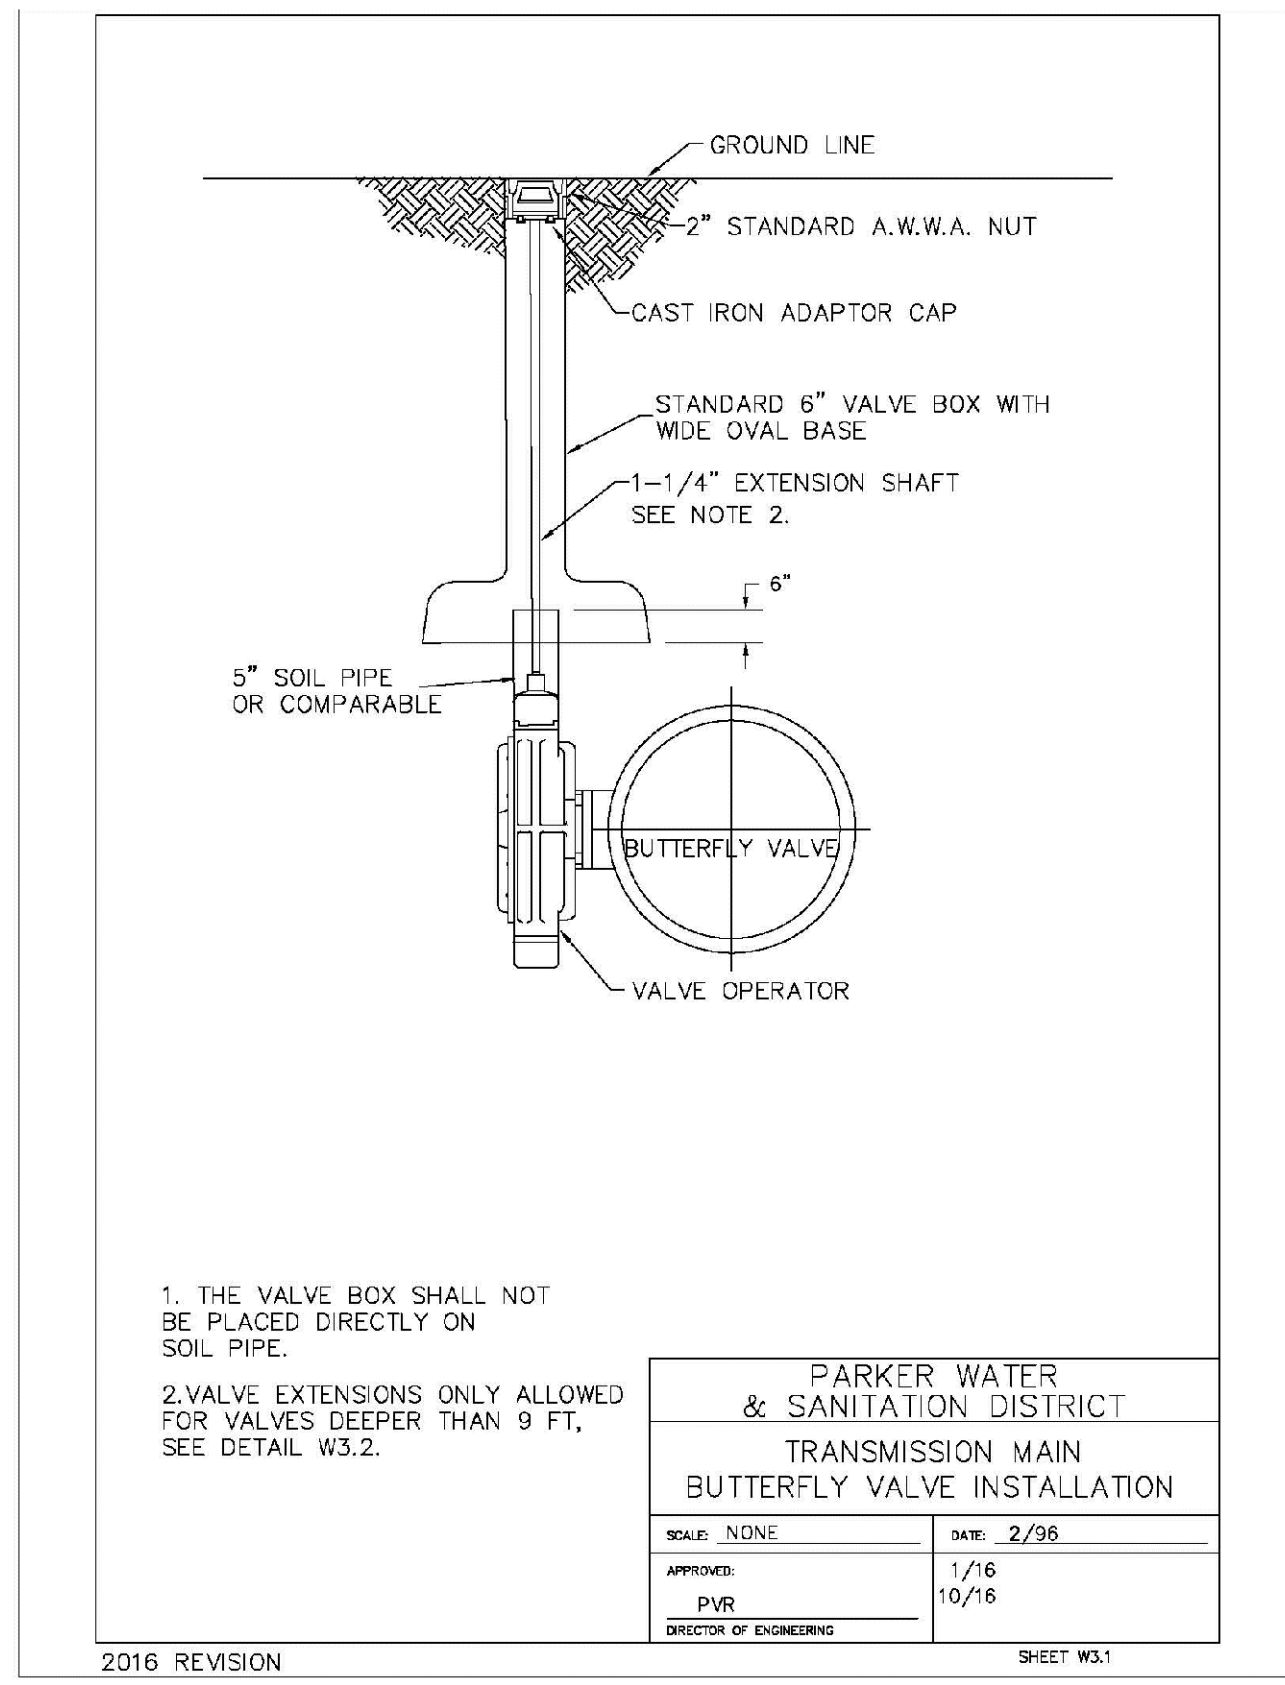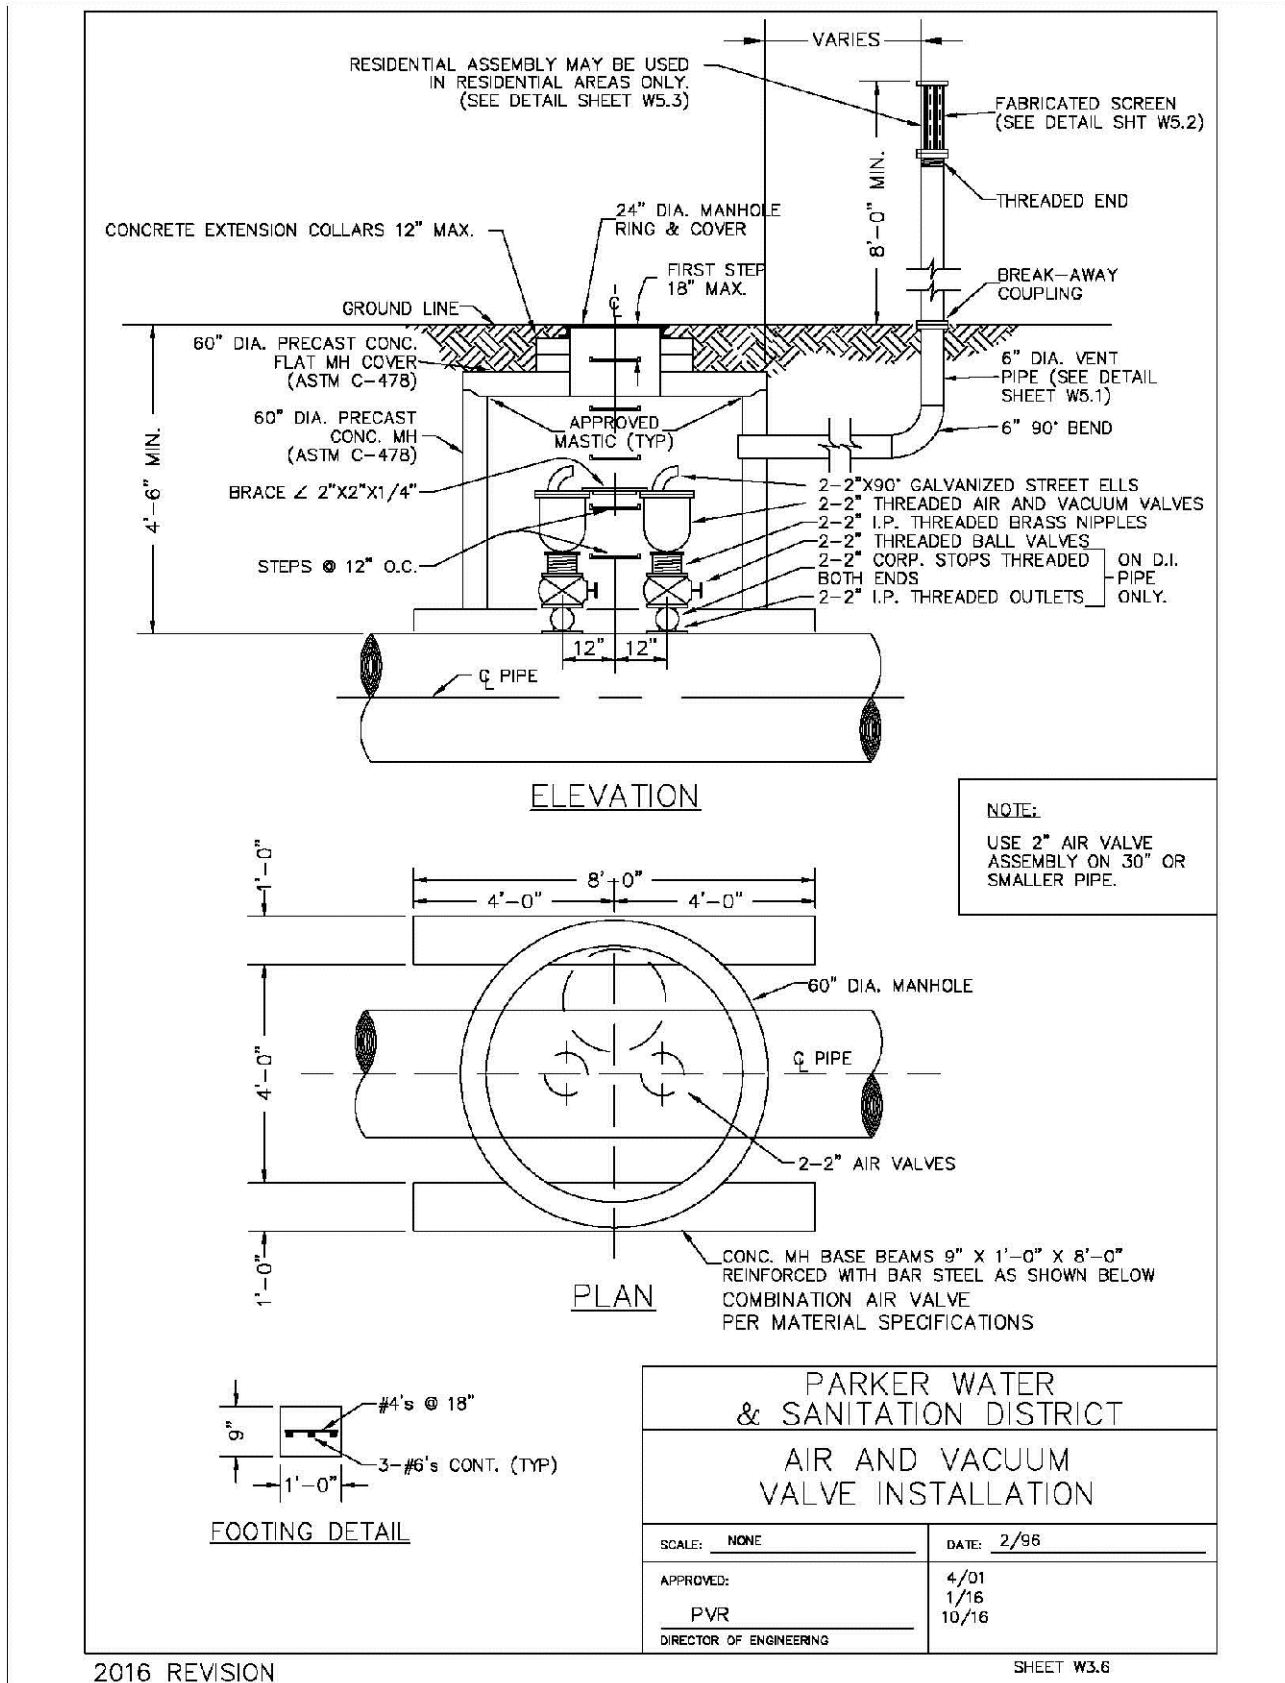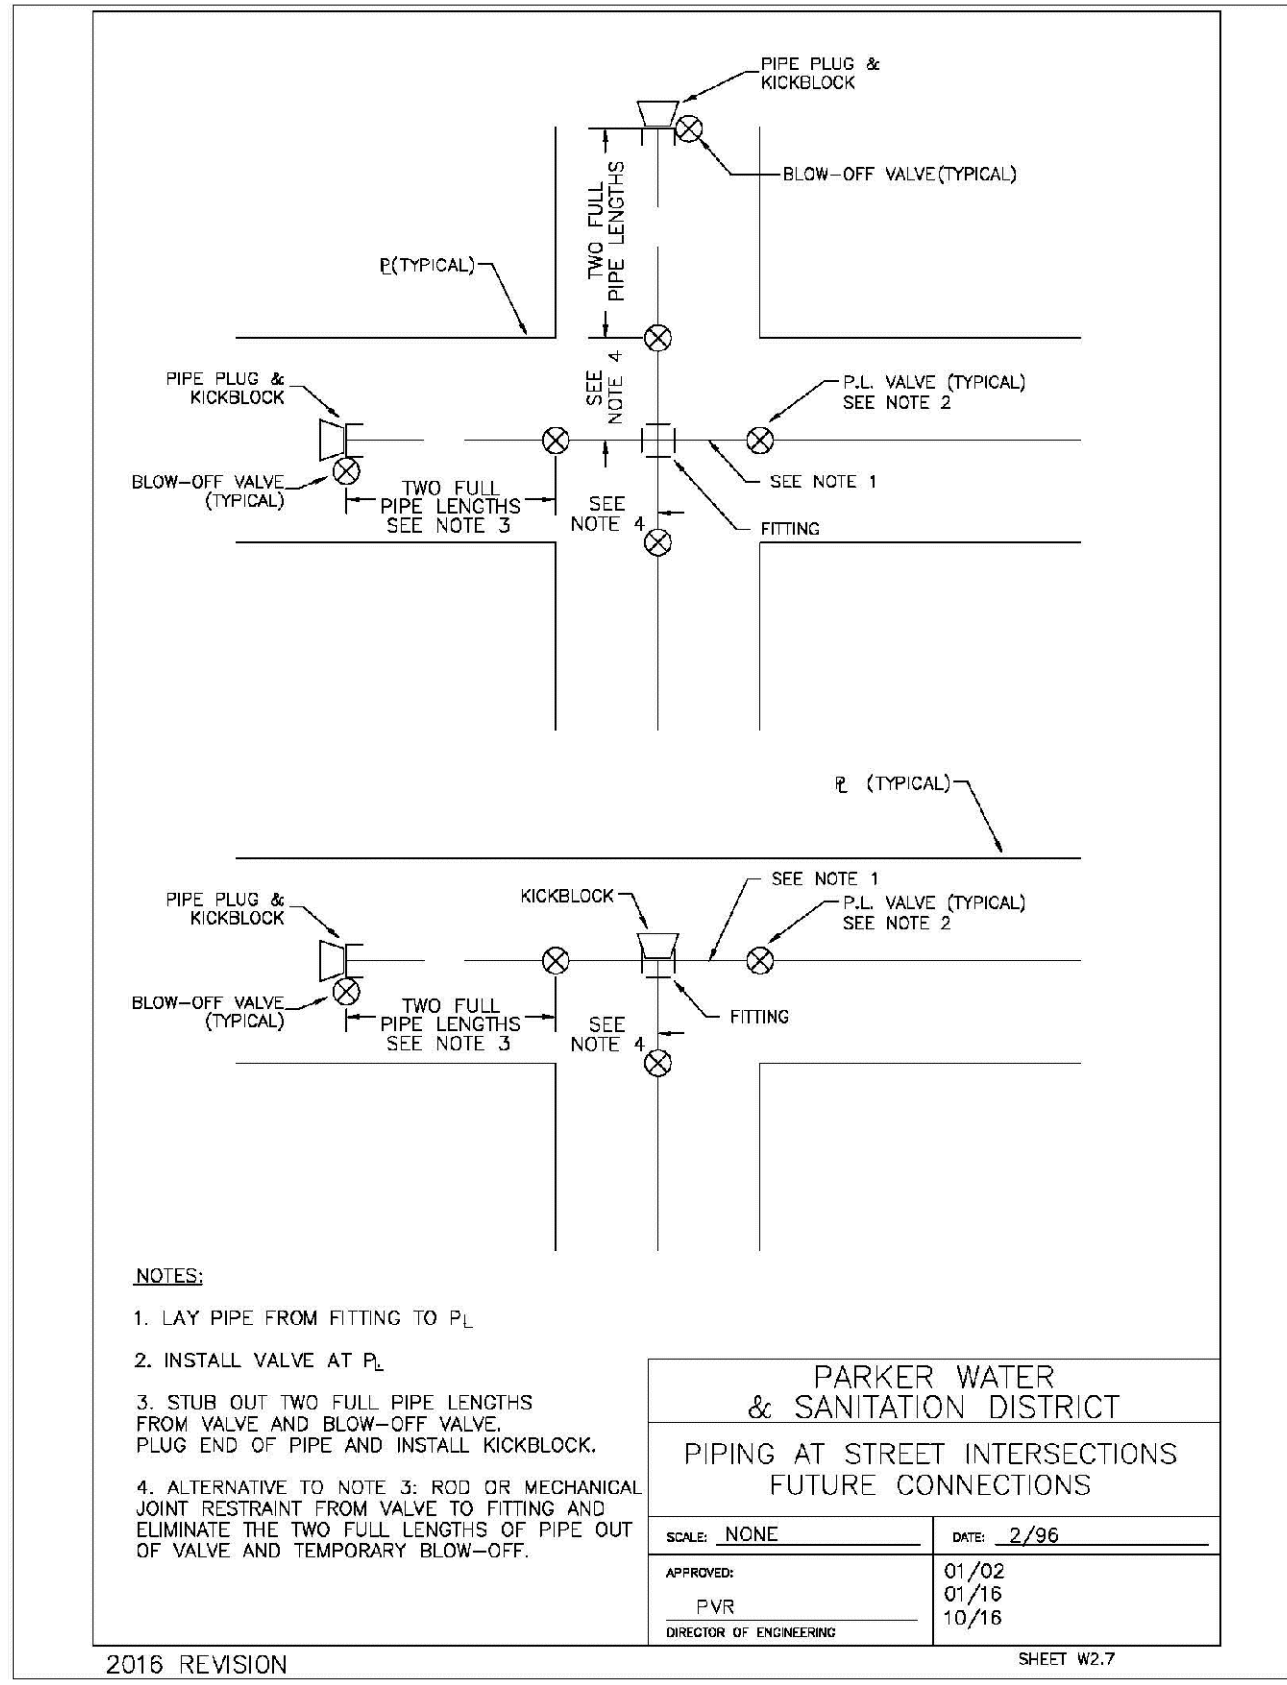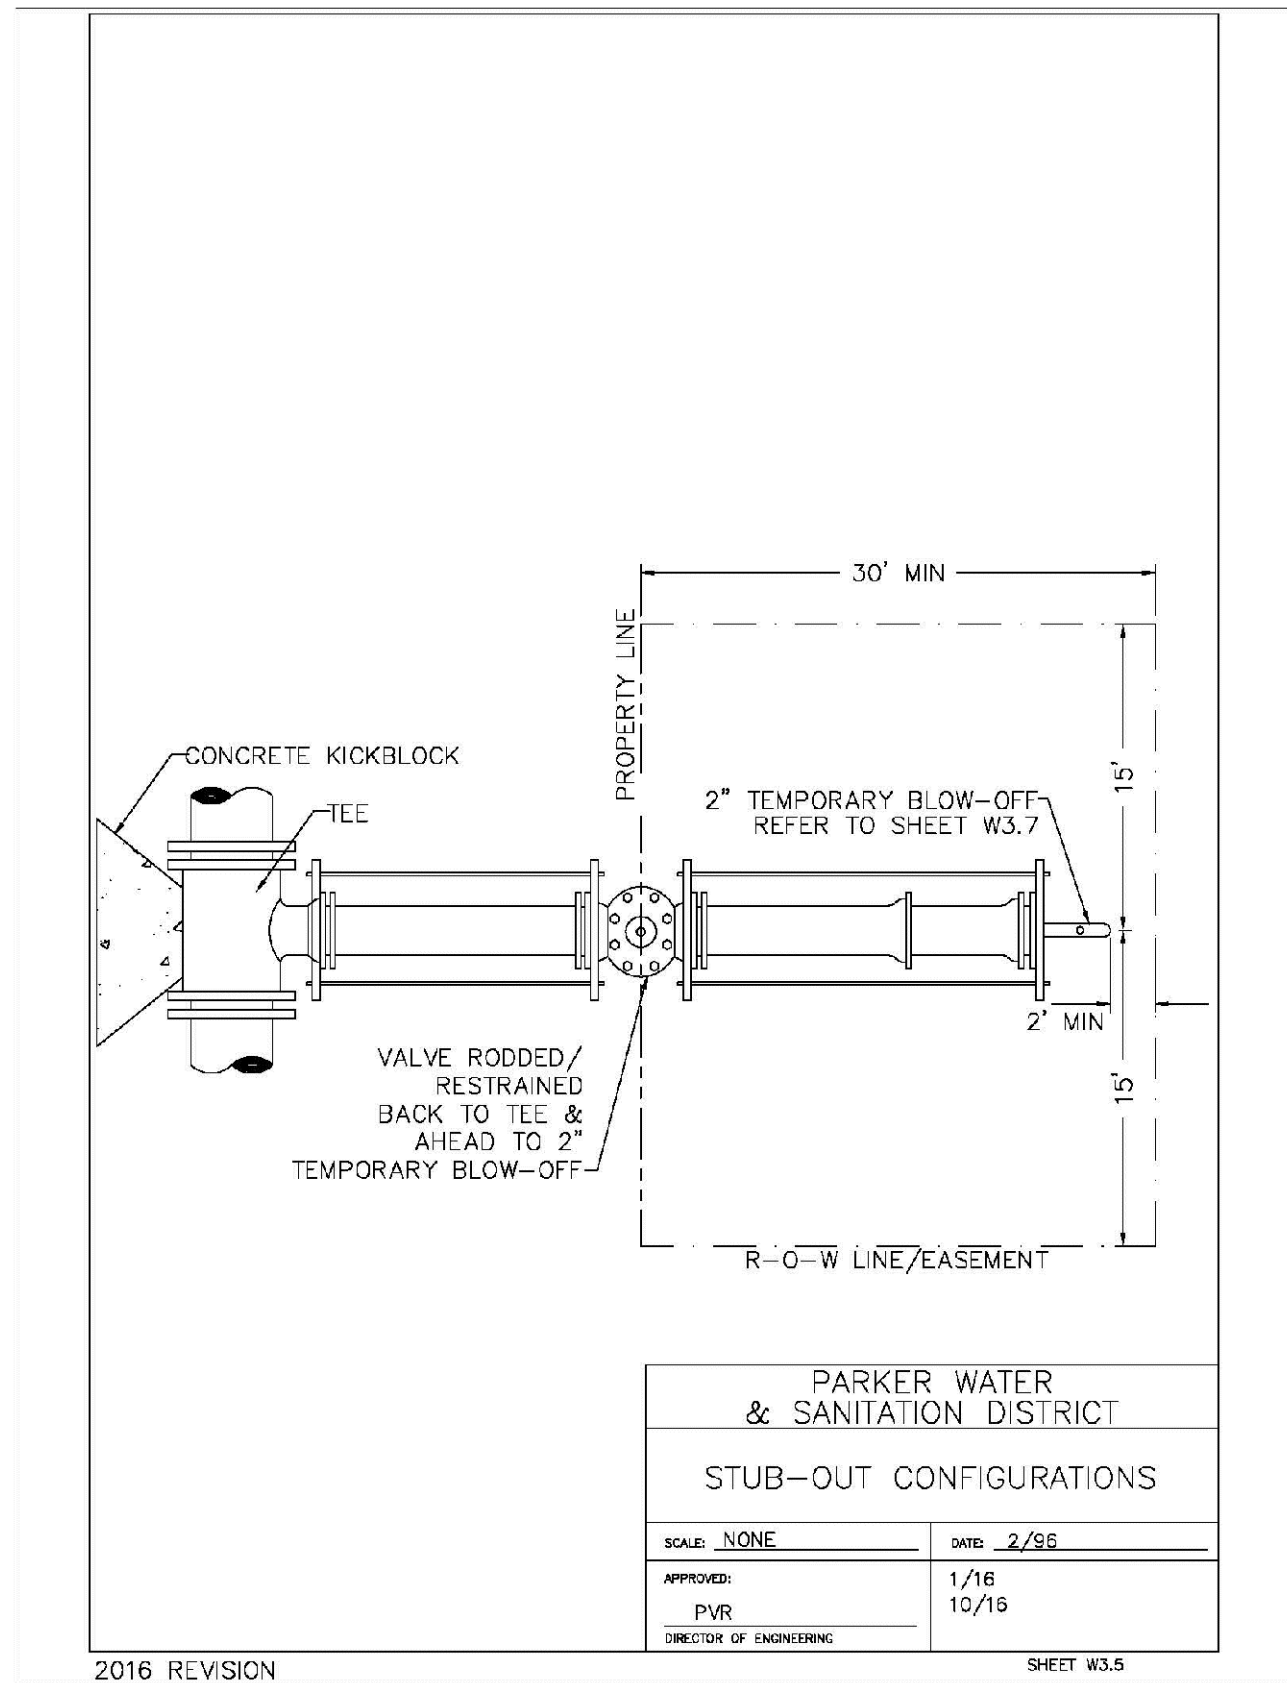

DRAWN BY: JF
CHECKED BY: JJJ
DATE: MAY 2017



TRAILS AT CROWFOOT
FILING 9 CONSTRUCTION DRAWINGS
WATER DETAILS




HR 935 LLC
7353 South Alton Way
CENTENNIAL, CO 80112

10333 E. Dry Creek Rd.
Suite 410
Englewood, CO 80150
Tel: (720) 482-9526
Fax: (720) 482-9548



No.	Revisions	Date	Init.	Appr.	Date

  2016 REVISION

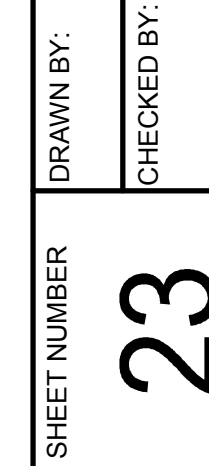  

N:\PROJECTS\SSR\BANCOC\ENGINEERING\NO SHEET SET\BODS\BWP\PARKER WATER AND SANITATION\BODS\DWG. CDDVA_2262018 6:30 PM

