

N:\PROJECTS\SSR\BANCROFT\ENGINEERING\SSHEET SET\CD\CD5\F7PARKER WATER AND SANITATION\F7 COVER.DWG, CDDVA, 3/7/2018 4:37 PM


TRAILS AT CROWFOOT FILING 7

PARKER WATER AND SANITATION CONSTRUCTION PLANS

SECTIONS 4, 8, AND 9 TOWNSHIP 7 SOUTH, RANGE 66 WEST OF THE SIXTH PRINCIPAL MERIDIAN COUNTY OF DOUGLAS, STATE OF COLORADO

Sheet List Table

Sheet Number	Sheet Title
1	COVER SHEET
2	PARKER WATER AND SANITATION NOTES
3	AREA UTILITY PLAN
4	SANITARY P&P SHASTA DAISY POINT
5	SANITARY P&P SHASTA DAISY POINT
6	SANITARY P&P HOP CLOVER STREET
7	WATER P&P SHASTA DAISY POINT
8	WATER P&P HOP CLOVER STREET
9	SANITARY SEWER DETAILS
10	SANITARY SEWER DETAILS
11	SANITARY SEWER DETAILS
12	WATER DETAILS
13	WATER DETAILS
14	WATER DETAILS
15	WATER DETAILS
16	WATER DETAILS
17	WATER DETAILS
18	WATER DETAILS

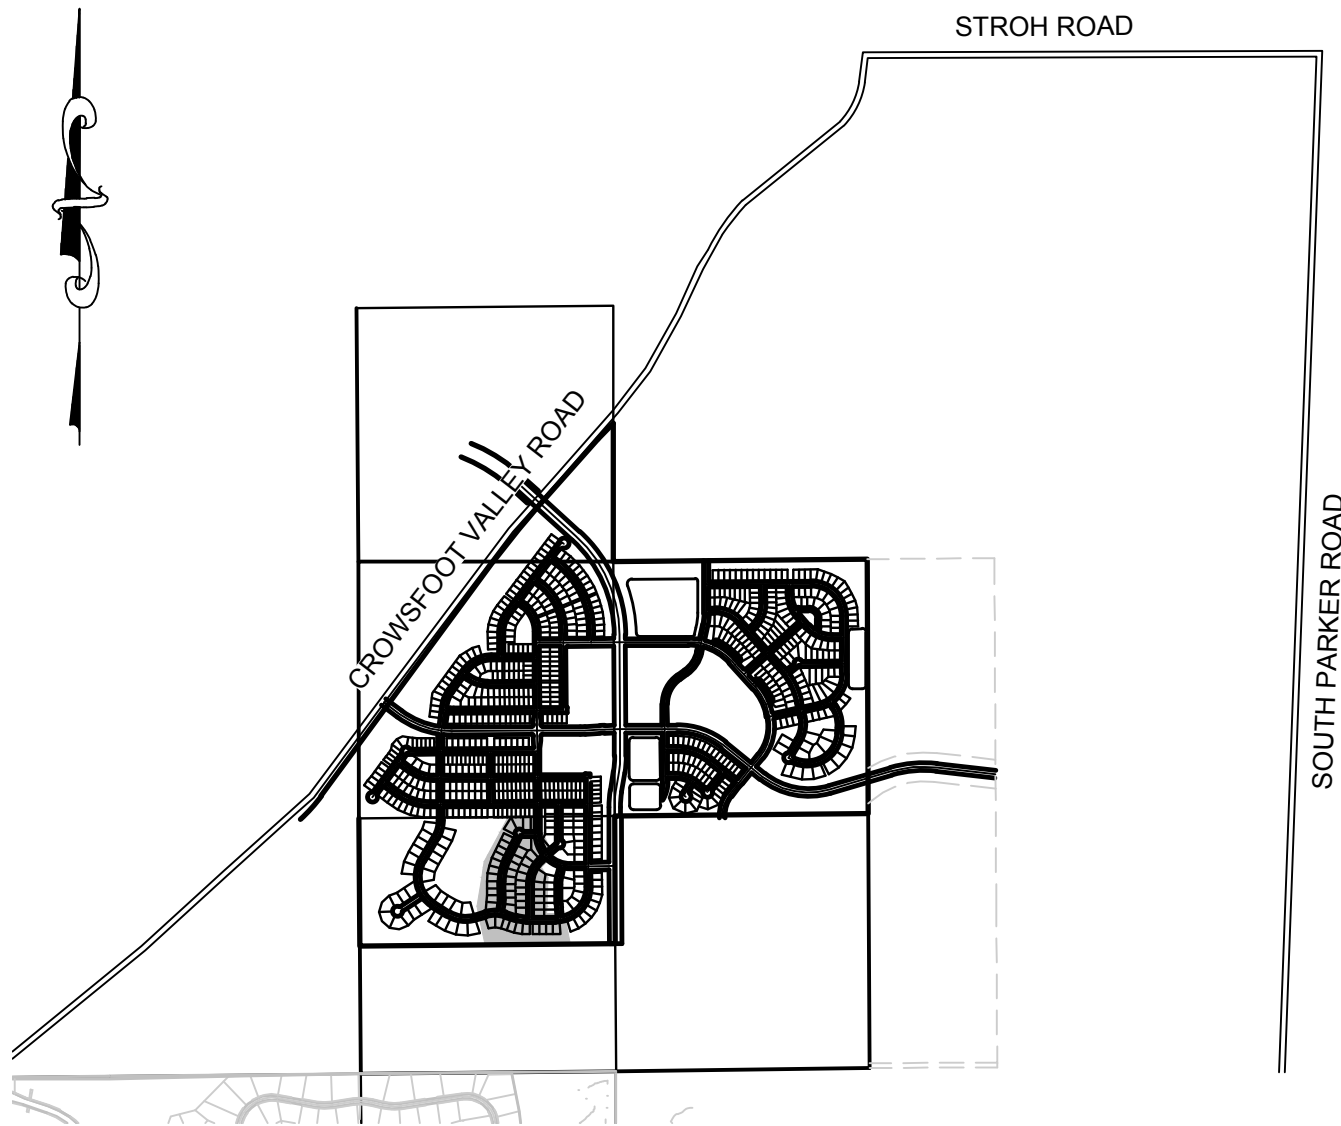

VICINITY MAP
SCALE: 1" = 2000'

MATERIALS LIST

DESCRIPTION	QUANTITY	UNIT
8" WATERPIPE (C900)	1,602	L.F.
6" WATERPIPE (DIP-FIRE HYDRANT LINE)	76	L.F.
8" GATE VALVE W/ BOX	1	EA.
6" GATE VALVE W/ BOX	3	EA.
8" MISC. VALVES	11	EA.
AIR/VAC VALVE	2	EA.
FIRE HYDRANT WITH 6" LEAD	3	EA.
CONNECTION TO EXISTING MAIN	4	EA.
WATER SERVICE LATERAL W/ WATER METER AND PIT	49	EA.
8" SEWER (SDR-35 PVC)	1,116	L.F.
4' DIA. MANHOLE	8	EA.
SEWER SERVICE LATERAL W/ WYE TAP	49	EA.
CONNECTION TO EXISTING MAIN	5	EA.

DEVELOPER

HR 935 LLC
7353 SOUTH ALTON WAY
CENTENNIAL, CO 80112
TEL: (303) 770-9111
CONTACT: MATT JANKE

PLANNER/ LANDSCAPE DESIGNER:

PCS GROUP, INC.
200 KALAMATH STREET
DENVER, CO 80233
TEL: (303) 531-4905
CONTACT: JOHN PRESTWICH

SURVEYOR/ ENGINEER:

 
CVL CONSULTANTS
OF COLORADO, INC.
10333 E. DRY CREEK RD. STE 240
ENGLEWOOD, CO 80112
TEL: (720) 482-9526
CONTACT: JIM JANNICKE

UTILITY DISTRICT

PARKER WATER AND
SANITATION DISTRICT
18100 E. WOODMAN DRIVE
PARKER, CO 80134
TEL: (303) 841-4627

FIRE DEPARTMENT APPROVAL

ALL FIRE HYDRANTS SHALL BE INSTALLED ACCORDING TO WATER UTILITY STANDARDS. THE NUMBER AND LOCATIONS OF THE FIRE HYDRANTS AS SHOWN ON THE OVERALL UTILITY PLAN ARE CORRECT AS SPECIFIED BY THE TOWN OF PARKER, COMMUNITY DEVELOPMENT DEPARTMENT.

 02/12/2020
FIRE CODE OFFICIAL OR DESIGNATED REPRESENTATIVE DATE

(NOTE - UNDERGROUND FIRE LINE (UFL) SUBMITTAL DOCUMENTS MUST MEET THE REQUIREMENT OF NFPA 24 WHEN SUBMITTING FOR REVIEW.

THE DISTRICT INSPECTOR MUST BE NOTIFIED AT LEAST 48 HOURS PRIOR TO START OF CONSTRUCTION. CALL PARKER WATER AND SANITATION DISTRICT AT 303-841-4627. THE DISTRICT WILL PROVIDE PERIODIC INSPECTIONS OF THE WORK. 24 HOUR NOTICE TO THE INSPECTOR IS REQUIRED FOR SCHEDULE INSPECTIONS. ANY WORK ACCOMPLISHED WITHOUT THE APPROVAL OF THE INSPECTOR WILL BE SUBJECT TO REJECTION.

REVIEWED FOR CONFORMANCE TO PARKER WATER AND SANITATION DISTRICT STANDARDS.

BY: _____
(DISTRICT REPRESENTATIVE)

DATE SIGNED: _____

APPROVED FOR CONSTRUCTION:
PARKER WATER AND SANITATION DISTRICT

BY: _____
(DISTRICT ENGINEER)

DATE SIGNED: _____

PREPARED UNDER THE
SUPERVISION OF



BRIAN P. WILSON
COLORADO P.E. 0050067

BENCHMARK
DOUGLAS COUNTY CONTROL POINT KNOWN AS 1.060032, BEING A 3-1/4" ALUMINUM CAP, BEING LOCATED IN THE SOUTHWEST QUARTER OF SECTION 33, TOWNSHIP 6 SOUTH, RANGE 66 WEST OF THE SIXTH PRINCIPAL MERIDIAN, HAVING A PUBLISHED ELEVATION OF 1799.2870 METERS (5903.13 FEET) NAVD '88 DATUM.

BASIS OF BEARINGS:
THE EAST LINE OF THE NORTHEAST QUARTER OF SAID SECTION 9 BEING MONUMENTED AT THE NORTHEAST CORNER OF SAID SECTION 9 BY A 3-1/4" ALUMINUM CAP STAMPED LS 23053 AND AT THE EAST QUARTER CORNER OF SAID SECTION 9 BY A 2-1/2" ALUMINUM CAP STAMPED LS 6935 BEING CONSIDERED TO BEAR SOUTH 00°15'06" EAST, 2648.70 FEET.



CALL 811
TWO WORKING DAYS
BEFORE YOU DIG
1-800-922-1987

SHEET NUMBER	DRAWN BY:	KJD	CHECKED BY:	JLJ	DATE:	AUGUST 2017	Revisions	No.	Date	Init.	Appr.	Date
1												

10333 E. Dry Creek Rd.
Suite 240
Englewood, CO 80112
Tel: (720) 482-9526
Fax: (720) 482-9546

**CVL**
CONSULTANTS

HR 935 LLC
7353 South Alton Way
CENTENNIAL, CO 80112

TRAILS AT CROWFOOT
FILING 7 CONSTRUCTION DRAWINGS
COVER SHEET

SCALE:
AS SHOWN
FILE NO:
8130283701

N:\PROJECTS\SHS8 RANCH\CAD\ENGINEERING\SHS8 SETS\CD\SDS\7P\PARKER WATER AND SANITATION\7 COVER.DWG, CDDVA, 3/2/2018 4:13 PM



CALL 811
TWO WORKING DAYS
BEFORE YOU DIG
UNCC 1-800-922-1987
UTILITY NOTIFICATION
CENTER OF COLORADO

GENERAL NOTES:

1. ALL CONSTRUCTION SHALL COMPLY WITH PARKER WATER AND SANITATION DISTRICT SPECIFICATIONS.
2. THE CONTRACTOR SHALL CONTACT ALL APPROPRIATE UTILITY COMPANIES AND THE TOWN OF PARKER PRIOR TO THE BEGINNING OF ANY CONSTRUCTION. CONTRACTOR SHALL BE RESPONSIBLE FOR LOCATING ANY EXISTING UTILITY (INCLUDING DEPTHS) WHICH MAY CONFLICT WITH THE PROPOSED CONSTRUCTION. ALL EXISTING UTILITIES SHALL BE PROTECTED FROM DAMAGE BY THE CONTRACTOR. DAMAGED UTILITIES SHALL BE REPAIRED BY THE CONTRACTOR AT HIS OWN EXPENSE.
3. ALL ITEMS SHOWN ON THE PLANS AS EXISTING ARE SHOWN IN APPROXIMATE LOCATIONS ONLY. THE ACTUAL LOCATIONS MAY VARY FROM THE PLANS, ESPECIALLY IN THE CASE OF UNDERGROUND UTILITIES. WHENEVER CONTRACTOR DISCOVERS A DISCREPANCY IN LOCATIONS, HE SHALL CONTACT THE ENGINEER IMMEDIATELY.
4. THE DISTRICT ENGINEER AND OTHER APPROVING AGENCIES ARE TO BE NOTIFIED AT LEAST 48 HOURS PRIOR TO CONSTRUCTION.
5. THE CONTRACTOR SHALL OBTAIN, AT HIS EXPENSE, ALL PERMITS THAT ARE NECESSARY TO PERFORM THE PROPOSED WORK.
6. ALL CONCRETE SHALL BE A MINIMUM OF CLASS A, 6 SACK, TYPE II, 3000-POUND COMPRESSION STRENGTH.
7. THE DESIGN ENGINEER SHALL SUBMIT ONE (1) SET OF ROLLED "AS-BUILT" BLUELINE PRINTS AND ELECTRONIC FILES TO THE DISTRICT ENGINEER FOR APPROVAL PRIOR TO PRINTING MYLAR SEPIAS FOR THE DISTRICT. AFTER APPROVAL HAS BEEN GRANTED BY THE DISTRICT ENGINEER, FULL SIZE MYLAR SEPIA PRINTS SHALL BE TRANSMITTED TO THE PARKER WATER AND SANITATION DISTRICT OFFICE.
8. ALL BACKFILL MATERIAL SHALL BE COMPACTED TO 95% STANDARD PROCTOR DENSITY. COMPACTION TESTS MUST BE SUBMITTED TO DISTRICT ENGINEER PRIOR TO PROBATIONARY ACCEPTANCE.
9. TRENCHES SHALL BE EXCAVATED AND THE PIPE EXPOSED FOR THE INSPECTION AT ANY LOCATION ON THE PROJECT IF SO ORDERED BY THE INSPECTOR.
10. THE CONTRACTOR WILL BE HELD RESPONSIBLE FOR THE PROPER FUNCTIONING OF LINES (WATER AND SEWER) FOR UP TO TWO (2) YEARS FROM THE DATE OF PROBATIONARY ACCEPTANCE OF THE LINES BY THE DISTRICT. ANY MALFUNCTION DURING THIS PERIOD OF GUARANTEE SHALL BE REMEDIED BY THE CONTRACTOR TO THE SATISFACTION OF THE DISTRICT ENGINEER AT NO EXPENSE TO THE DISTRICT.
11. SURFACE GRADES ARE TO BE WITHIN PLUS OR MINUS ONE FOOT OF FINISHED GRADE AND VERIFICATION OF COMPACTION RESULTS OBTAINED PRIOR TO THE INSTALLATION OF WATER AND SEWER LINES. RESULTS MUST BE SUBMITTED TO THE DISTRICT ENGINEER.
12. NO WORK SHALL BE BACKFILLED UNTIL THE CONSTRUCTION HAS BEEN INSPECTED AND APPROVED FOR BACKFILLING BY THE DISTRICT ENGINEER OR REPRESENTATIVE OF THE DISTRICT ENGINEER.
13. ALL SERVICES WILL BE PERMANENTLY MARKED ON CURB FACE AS FOLLOWS: "X" FOR SANITARY SERVICE SEWERS "V" FOR WATER SERVICES
14. NO TREES SHALL BE ALLOWED IN EASEMENTS OR WITHIN 8' OF ANY WATER OR SANITARY SEWER MAINS IN RIGHT OF WAY.
15. THE CONTRACTOR SHALL HAVE IN HIS POSSESSION AT ALL TIMES ONE (1) SIGNED COPY OF THE PLANS WHICH HAVE BEEN APPROVED BY THE PARKER WATER AND SANITATION DISTRICT AND THE DISTRICT ENGINEER AND ONE (1) COPY OF THE LATEST PARKER WATER AND SANITATION DISTRICT SPECIFICATION MANUAL.

WATER MAIN NOTES:

1. ALL MATERIALS AND WORKMANSHIP SHALL BE IN CONFORMANCE WITH THE PARKER WATER AND SANITATION DISTRICT ENGINEERING STANDARDS AND SPECIFICATIONS, LATEST REVISIONS. ALL WORK SHALL BE INSPECTED AND APPROVED BY PERSONNEL OF THE PARKER WATER SANITATION DISTRICT AND THE DISTRICT ENGINEER.
2. ALL WATER MAINS SHALL BE PER PWSO MATERIALS SPECIFICATIONS.
3. ALL BENDS, PLUGS, REDUCERS, AND FIRE HYDRANTS TO BE RODDED OR MEGA-LUGGED. ALL FITTINGS SHALL BE WRAPPED WITH 8-MIL MINIMUM THICKNESS POLYETHYLENE MATERIAL PER PWSO MATERIALS SPECIFICATIONS.
4. THERE SHALL BE A MINIMUM COVER OF 4.5 FEET OVER ALL WATER MAINS.
5. FIRE HYDRANTS SHALL CONFORM TO AWWA C-502 "DRY BARREL FIRE HYDRANTS" PIPE HYDRANT ASSEMBLIES SHALL INCLUDE ALL PIPE, FITTINGS, VALVES, MATERIALS, AND LABOR WHICH ARE NECESSARY TO INSTALL THE HYDRANT COMPLETE IN PLACE. SEE MATERIALS SPECIFICATIONS FOR APPROVED MODELS
6. ALL BENDS, TEES, FIRE HYDRANTS, BLOW-OFFS AND PLUGS AT DEAD END MAINS SHALL BE PROTECTED FROM THRUST BY USING CONCRETE THRUST BLOCKS.
7. PRECAUTIONS SHALL BE TAKEN TO PROTECT THE INTERIOR OF PIPES, FITTINGS, AND VALVES AGAINST CONTAMINATION. ALL OPENINGS IN THE PIPELINE SHALL BE CLOSED WITH WATERTIGHT PLUGS WHEN PIPE LAYING IS STOPPED AT THE CLOSE OF THE DAY'S WORK OR FOR OTHER REASONS, SUCH AS REST BREAKS OR MEAL PERIODS. THE MORE CLOSELY THE RATE OF DELIVERY IS CORRELATED TO THE RATE OF PIPE LAYING, THE LOWER THE RISK OF CONTAMINATION.
8. CHLORINATION AND FLUSHING: ALL WATER MAINS SHALL BE INSTALLED AND CHLORINATED PER PARKER WATER AND SANITATION STANDARDS AND SPECIFICATIONS. THE LINES SHALL BE CHLORINATED IN ACCORDANCE WITH ANSI/AWWA C-651-92., "DISINFECTING WATER MAINS." PARKER WATER AND SANITATION DISTRICT REQUIRES THE INITIAL DOSAGE RATE OF DISINFECTION BE AT LEAST 50 MG PER LITER. CHLORINE TABLETS SHOULD BE ADHERED TO THE TOP OF THE PIPE SECTION WITH PERMATRX NO.1 (RED). THE CHLORINATION OF ANY FINISHED PIPELINE SHALL BE DONE PRIOR TO THE HYDROSTATIC TESTING.
9. HYDROSTATIC TESTING: ALL WATER MAINS SHALL BE TESTED PER THE REQUIREMENTS OF THE PARKER WATER AND SANITATION DISTRICT STANDARDS AND SPECIFICATIONS. ALL PIPE SHALL BE FIELD PRESSURE TESTED TO A MINIMUM OF 150 PSI. ALL TESTING SHALL BE DONE IN THE PRESENCE OF A PARKER WATER AND SANITATION DISTRICT INSPECTOR. LEAKAGE FOR EACH SECTION OF PIPE BETWEEN LINES VALVES SHALL NOT EXCEED THE LIMITS SET FOURTH IN THE PARKER WATER AND SANITATION DISTRICT STANDARDS AND SPECIFICATIONS.
10. VALVES IN STREETS ARE TO BE LOCATED AT PROPERTY LINE EXTENSIONS EXCEPT FOR TAPPING TEES WHERE AN ADDITIONAL VALVES SHALL BE PLACED ON THE TAPPING TEE. OTHER VALVE LOCATIONS, SUCH AS WHERE CROSS PANS EXIST, ARE SHOWN ON THE PLANS.
11. WHEN NECESSARY TO LOWER OR RAISE WATER LINES AT STORM DRAINS AND OTHER UTILITY CROSSING, A MINIMUM CLEARANCE OF 1.50 FEET SHALL BE MAINTAINED BETWEEN OUTSIDE OF PIPES.
12. THE CONTRACTOR SHALL NOTIFY THE PARKER WATER AND SANITATION DISTRICT AND THE DISTRICT ENGINEER AT LEAST 48 HOURS PRIOR TO ANY CONSTRUCTION. IF WORK IS SUSPENDED FOR ANY PERIOD OF TIME AFTER INITIAL START-UP, THE CONTRACTOR MUST NOTIFY THE DISTRICT ENGINEER 48 HOURS PRIOR TO RE-START.
13. PIPE BEDDING SHALL BE A CLEAN, WELL-GRADED SAND OR SQUEEGEE SAND IN ACCORDANCE WITH PARKER WATER AND SANITATION DISTRICT STANDARDS AND SPECIFICATIONS, LATEST REVISION.
14. THE CONTRACTOR SHALL NOTIFY THE PUBLIC UTILITY COMPANIES AND DETERMINED THE LOCATION OF ALL EXISTING UNDERGROUND UTILITIES PRIOR TO PROCEEDING WITH THE EXCAVATION. ALL WORK PERFORMED IN THE AREA OF THE PUBLIC UTILITIES SHALL BE PERFORMED ACCORDING TO THE REQUIREMENTS OF THESE AGENCIES.
15. COMPACTION OF ALL TRENCHES MUST BE ATTAINED IN ACCORDANCE WITH THE SOILS REPORTS AND COMPACTION TEST RESULTS SUBMITTED TO THE DISTRICT ENGINEER PRIOR TO PROBATIONARY ACCEPTANCE.
16. VALVE BOXES: TYLER SCREW-TYPE 6 INCHES CAST IRON VALVE BOX ASSEMBLY SERIES 6860 WITH NO. 160 OVAL BASE. CLAY AND BAILEY SCREW-TYPE 6 INCH CAST IRON VALVE BOX ASSEMBLY NO. P-108 WITH NO. 106 LARGE OVAL BASE.
17. ALL PIPE LENGTHS ARE APPROXIMATE.
18. AT LEAST FIVE (5) DAYS PRIOR TO THE START OF CONSTRUCTION, A PRE-CONSTRUCTION MEETING WILL BE HELD AT THE OFFICE OF THE DISTRICT ENGINEER AND ATTENDED BY THE CONTRACTOR AND REPRESENTATIVE OF OTHER APPROVING AGENCIES. IT WILL BE THE RESPONSIBILITY OF THE CONTRACTOR TO CONTACT THE DISTRICT ENGINEER.

SANITARY SEWER NOTES:

1. ALL SANITARY SEWER CONSTRUCTION SHALL CONFORM TO THE PARKER WATER AND SANITATION DISTRICT SPECIFICATION.
2. ALL SEWER MAINS SHALL BE PVC, ASTM D-3034, SDR 35 OR APPROVED EQUAL. ALL SEWER MAIN SIZE IS 8" IN DIAMETER UNLESS OTHERWISE NOTED.
3. SEWER LINES SHALL BE INSTALLED 5.0 FEET SOUTH OR WEST OF STREET CENTERLINE, UNLESS OTHERWISE SHOWN ON PLANS. SEWER LINES SHALL BE 10.00 FEET FROM WATER LINES EXCEPT WHEN CROSSING EACH OTHER. SEWER LINES WHICH CROSS LESS THAN 1.50 FEET VERTICALLY FROM THE WATER MAIN SHALL BE ENCASED IN CONCRETE AS PER PARKER WATER AND SANITATION DISTRICT STANDARD AND SPECIFICATIONS. USE RUBBER GASKETS FOR PVC ENCASEMENT.
4. SEWER RIM ELEVATIONS SHOWN ARE APPROPRIATE ONLY AND ARE NOT TO BE TAKEN AS FINAL ELEVATIONS. RING AND COVER SHALL BE SET IN CENTERED CONCRETE RINGS WITH RAM-NECK FOR ADJUSTMENT TO MATCH FINAL PAVEMENT ELEVATIONS.
5. THE CONTRACTOR AND SURVEY CREW SHALL VERIFY ELEVATIONS OF EXISTING SEWER LINES AND MANHOLES TO BE TIED TO PRIOR TO CONSTRUCTION OR STAKING OF SANITARY SEWER.
6. NO UNDERDRAIN SYSTEM WILL BE ALLOWED TO BE PLACED IN MAINLINE OR SEWER SERVICE TRENCHES.
7. SEWER SERVICE TEES FOR EACH UNIT SHALL BE STAKED BY A SURVEY CREW AND FURNISHED AND INSTALLED BY THE CONTRACTOR. THE CONTRACTOR SHALL FURNISH TO THE ENGINEER "AS CONSTRUCTED" LOCATION OF TEES. SEWER WYES SHALL BE USED RATHER THAN TEES.
8. ALL MANHOLES SHALL BE 48-INCHES IN DIAMETER WITH 24-INCH RING AND COVER, ECCENTRIC CONE UNLESS OTHERWISE SPECIFIED.
9. PIPE BEDDING SHALL BE CLASS "B" AND SHALL CONFORM TO ASTM C-33 OR D-448 GRADATION NO. 6 OR NO. 67.
10. AT LEAST FIVE (5) DAYS PRIOR TO THE START OF CONSTRUCTION, A PRE-CONSTRUCTION MEETING WILL BE HELD AT THE OFFICE OF THE DISTRICT ENGINEER AND ATTENDED BY THE CONTRACTOR AND REPRESENTATIVES OF THE OTHER APPROVING AGENCIES. IT WILL BE THE RESPONSIBILITY OF THE CONTRACTOR TO CONTACT THE DISTRICT ENGINEER TO SCHEDULE THIS MEETING.
11. ALL PIPE LENGTHS ARE APPROXIMATE.
12. THE CONTRACTOR SHALL HAVE IN HIS POSSESSION AT ALL TIMES ONE (1) SIGNED COPY OF THE PLANS WHICH HAVE BEEN APPROVED BY THE PARKER WATER AND SANITATION DISTRICT AND THE DISTRICT ENGINEER AND ONE (1) COPY OF THE LATEST PARKER WATER AND SANITATION DISTRICT SPECIFICATION MANUAL.
13. ALL MANHOLES SHALL HAVE SHAPED INVERTS.
14. ALL SEWER LINES SHALL BE TESTED IN ACCORDANCE WITH THE PARKER WATER AND SANITATION DISTRICT STANDARDS AND SPECIFICATIONS PRIOR TO ACCEPTANCE OR ANY CONNECTION TO AN EXISTING SEWER LINE.
15. PRIOR TO START WORK WHERE SEWER MAIN TO BE INSTALLED INTO EXISTING DISTRICT SEWER SYSTEMS. THE NEAREST MANHOLE TO THE POINT OF TIE-IN SHALL BE PLUGGED WITH A PLUMBER'S PLUG ON THE INLET SIDE BY THE CONTRACTOR. THIS PLUG SHALL REMAIN IN PLACE UNTIL FINAL ACCEPTANCE BY THE DISTRICT. ITS PURPOSE SHALL BE TO PREVENT ANY MUD, WATER OR OTHER MATERIALS FROM ENTERING THE LINE DURING CONSTRUCTION. THE CONTRACTOR SHALL BE RESPONSIBLE FOR PUMPING AND CLEANING THESE MANHOLES AND REMOVING THE PLUG WHEN SO INSTRUCTED BY THE DISTRICT.
16. PRIOR TO PROBATIONARY ACCEPTANCE WALK-THROUGH, THE CLIENT SHALL JET CLEAN THE ENTIRE SANITARY SEWER SYSTEM AND PUMP OUT AT THE PLUGGED MANHOLE.

DISTRICT ACCEPTANCE NOTES:

1. UPON COMPLETION OF SANITARY SEWER AND WATER CONSTRUCTION AND TESTING, THE DEVELOPER OR CONTRACTOR SHALL CONTACT THE DISTRICT FOR PROBATIONARY ACCEPTANCE INSPECTION. A PUNCHLIST WILL BE PROVIDED THE DEVELOPER AND CONTRACTOR UPON COMPLETION OF THE INITIAL WALK-THRU AND PROBATIONARY ACCEPTANCE WILL BE ISSUED FOLLOWING COMPLETION AND ACCEPTANCE OF THE WORK OUTLINED IN THE PUNCHLIST.
2. THE CONTRACTOR WILL BE HELD RESPONSIBLE FOR THE PROPER FUNCTIONING OF THE LINES FOR UP TO TWO (2) YEARS FROM THE DATE OF PROBATIONARY ACCEPTANCE OF THE LINES BY THE DISTRICT. ANY MALFUNCTION DURING THIS PERIOD OF GUARANTEE SHALL BE REMEDIED BY THE CONTRACTOR TO THE SATISFACTION OF THE DISTRICT ENGINEER AT NO EXPENSE TO THE DISTRICT.
3. THE DATE OF FINAL ACCEPTANCE WILL BE INDICATED IN THE CONDITIONS OF THE PROBATIONARY ACCEPTANCE LETTER. THE DEVELOPER SHALL BE RESPONSIBLE FOR CONTACTING THE DISTRICT FOR FINAL INSPECTION AND FINAL ACCEPTANCE.

BENCHMARK
DOUGLAS COUNTY CONTROL POINT KNOWN AS 1.060032, BEING A 3-1/4" ALUMINUM CAP, BEING LOCATED IN THE SOUTHWEST QUARTER OF SECTION 33, TOWNSHIP 6 SOUTH, RANGE 66 WEST OF THE SIXTH PRINCIPAL MERIDIAN, HAVING A PUBLISHED ELEVATION OF 1799.2870 METERS (5903.13 FEET) NAVD '88 DATUM.


BASIS OF BEARINGS:
THE EAST LINE OF THE NORTHEAST QUARTER OF SAID SECTION 9 BEING MONUMENTED AT THE NORTHEAST CORNER OF SAID SECTION 9 BY A 3-1/4" ALUMINUM CAP STAMPED LS 23053 AND AT THE EAST QUARTER CORNER OF SAID SECTION 9 BY A 2-1/2" ALUMINUM CAP STAMPED LS 6935 BEING CONSIDERED TO BEAR SOUTH 00°15'06" EAST, 2648.70 FEET.



DRAWN BY: KJD
CHECKED BY: JJJ
DATE: AUGUST 2017
SCALE: AS SHOWN
FILE NO: 8130283701

TRAILS AT CROWFOOT
FILING 7 CONSTRUCTION DRAWINGS
PARKER WATER AND SANITATION NOTES

HR 935 LLC
7353 South Alton Way
CENTENNIAL, CO 80112

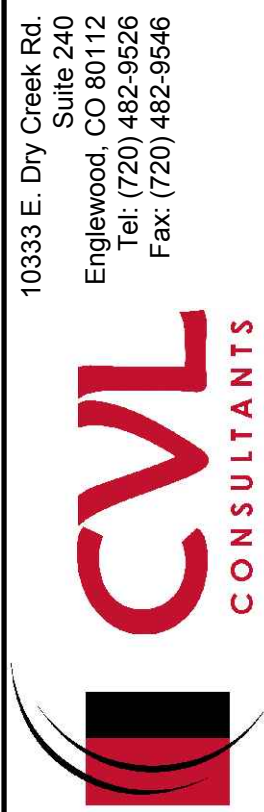

No.	Revisions	Date	Init.	Appr.	Date

N:\PROJECTS\BESS RANCH\CD\ENGINEERING\CD\SET\BESS\CD\PARKER WATER AND SANITATION\7 AREA UTILITY PLANDWG. CDDVA_3/5/2019 4:18 PM



CALL 811
TWO WORKING DAYS
BEFORE YOU DIG
UNCC 1-800-922-1987

FIRE DEPARTMENT APPROVAL

ALL FIRE HYDRANTS SHALL BE INSTALLED ACCORDING TO WATER UTILITY STANDARDS. THE NUMBER AND LOCATIONS OF THE FIRE HYDRANTS AS SHOWN ON THE OVERALL UTILITY PLAN ARE CORRECT AS SPECIFIED BY THE TOWN OF PARKER, COMMUNITY DEVELOPMENT DEPARTMENT.

FIRE CODE OFFICIAL OR DESIGNATED REPRESENTATIVE


02/12/2020

DATE

(NOTE - UNDERGROUND FIRE LINE (UFL) SUBMITTAL DOCUMENTS MUST MEET THE REQUIREMENT OF NFPA 24 WHEN SUBMITTING FOR REVIEW.)

WATER SERVICE TABLE		
FILING, BLOCK, LOT	STREET	STATIONING
F7.B1.L1	SHASTA DAISY PT	19+68.64
F7.B1.L2	SHASTA DAISY PT	18+70.03
F7.B1.L3	SHASTA DAISY PT	18+49.19
F7.B1.L4	SHASTA DAISY PT	17+90.70
F7.B1.L5	SHASTA DAISY PT	17+20.70
F7.B1.L6	SHASTA DAISY PT	16+50.70
F7.B1.L7	SHASTA DAISY PT	15+80.70
F7.B1.L8	SHASTA DAISY PT	15+12.51
F7.B1.L9	SHASTA DAISY PT	14+50.21
F7.B1.L10	SHASTA DAISY PT	13+81.74
F7.B1.L11	SHASTA DAISY PT	12+77.71
F7.B1.L12	SHASTA DAISY PT	12+07.71
F7.B1.L13	SHASTA DAISY PT	11+22.90
F7.B1.L14	SHASTA DAISY PT	10+60.90
F7.B2.L1	SHASTA DAISY PT	19+70.69
F7.B2.L2	SHASTA DAISY PT	17+36.15
F7.B2.L3	SHASTA DAISY PT	16+38.62
F7.B2.L4	SHASTA DAISY PT	15+63.62
F7.B2.L5	SHASTA DAISY PT	14+69.94
F7.B2.L6	SHASTA DAISY PT	13+81.74
F7.B2.L7	SHASTA DAISY PT	12+52.20
F7.B2.L8	SHASTA DAISY PT	11+82.20
F7.B2.L9	SHASTA DAISY PT	11+24.16
F7.B2.L10	SHASTA DAISY PT	10+58.41
F7.B2.L11	HOP CLOVER ST	10+63.00
F7.B2.L12	HOP CLOVER ST	11+40.98
F7.B2.L13	HOP CLOVER ST	12+10.98
F7.B2.L14	HOP CLOVER ST	12+80.98
F7.B2.L15	HOP CLOVER ST	13+50.98
F7.B2.L16	HOP CLOVER ST	14+19.09
F7.B2.L17	HOP CLOVER ST	15+09.65
F7.B2.L18	HOP CLOVER ST	15+76.97
F7.B2.L19	HOP CLOVER ST	16+38.73
F7.B3.L1	HOP CLOVER ST	15+48.44
F7.B3.L2	HOP CLOVER ST	13+32.50
F7.B3.L3	HOP CLOVER ST	12+62.50
F7.B3.L4	HOP CLOVER ST	11+92.50
F7.B3.L5	HOP CLOVER ST	11+22.50
F7.B3.L6	HOP CLOVER ST	10+61.00
F7.B4.L1	ROSE MALLOW AVE	38+03.97
F7.B4.L2	ROSE MALLOW AVE	37+13.31
F7.B4.L3	ROSE MALLOW AVE	37+81.82
F7.B4.L4	ROSE MALLOW AVE	38+50.26
F7.B4.L5	ROSE MALLOW AVE	39+07.86
F7.B4.L6	ROSE MALLOW AVE	39+65.65
F7.B4.L7	ROSE MALLOW AVE	40+76.73
F7.B4.L8	ROSE MALLOW AVE	41+46.73
F7.B4.L9	ROSE MALLOW AVE	42+16.73
F7.B4.L10	ROSE MALLOW AVE	42+79.53

SANITARY SERVICE TABLE		
FILING, BLOCK, LOT	STREET	STATIONING
F7.B1.L1	SHASTA DAISY PT	19+68.64
F7.B1.L2	SHASTA DAISY PT	18+70.03
F7.B1.L3	SHASTA DAISY PT	18+49.19
F7.B1.L4	SHASTA DAISY PT	17+90.70
F7.B1.L5	SHASTA DAISY PT	17+20.70
F7.B1.L6	SHASTA DAISY PT	16+50.70
F7.B1.L7	SHASTA DAISY PT	15+80.70
F7.B1.L8	SHASTA DAISY PT	15+12.51
F7.B1.L9	SHASTA DAISY PT	14+50.21
F7.B1.L10	SHASTA DAISY PT	13+81.74
F7.B1.L11	SHASTA DAISY PT	12+77.71
F7.B1.L12	SHASTA DAISY PT	12+07.71
F7.B1.L13	SHASTA DAISY PT	11+22.90
F7.B1.L14	SHASTA DAISY PT	10+60.90
F7.B2.L1	SHASTA DAISY PT	19+70.69
F7.B2.L2	SHASTA DAISY PT	17+36.15
F7.B2.L3	SHASTA DAISY PT	16+38.62
F7.B2.L4	SHASTA DAISY PT	15+63.62
F7.B2.L5	SHASTA DAISY PT	14+69.94
F7.B2.L6	SHASTA DAISY PT	13+81.74
F7.B2.L7	SHASTA DAISY PT	12+52.20
F7.B2.L8	SHASTA DAISY PT	11+82.20
F7.B2.L9	SHASTA DAISY PT	11+24.16
F7.B2.L10	SHASTA DAISY PT	10+58.41
F7.B2.L11	HOP CLOVER ST	10+63.00
F7.B2.L12	HOP CLOVER ST	11+40.98
F7.B2.L13	HOP CLOVER ST	12+10.98
F7.B2.L14	HOP CLOVER ST	12+80.98
F7.B2.L15	HOP CLOVER ST	13+50.98
F7.B2.L16	HOP CLOVER ST	14+19.09
F7.B2.L17	HOP CLOVER ST	15+09.65
F7.B2.L18	HOP CLOVER ST	15+76.97
F7.B2.L19	HOP CLOVER ST	16+38.73
F7.B3.L1	HOP CLOVER ST	15+48.44
F7.B3.L2	HOP CLOVER ST	13+32.50
F7.B3.L3	HOP CLOVER ST	12+62.50
F7.B3.L4	HOP CLOVER ST	11+92.50
F7.B3.L5	HOP CLOVER ST	11+22.50
F7.B3.L6	HOP CLOVER ST	10+61.00
F7.B4.L1	ROSE MALLOW AVE	38+03.97
F7.B4.L2	ROSE MALLOW AVE	37+13.31
F7.B4.L3	ROSE MALLOW AVE	37+81.82
F7.B4.L4	ROSE MALLOW AVE	38+50.26
F7.B4.L5	ROSE MALLOW AVE	39+07.86
F7.B4.L6	ROSE MALLOW AVE	39+65.65
F7.B4.L7	ROSE MALLOW AVE	40+76.73
F7.B4.L8	ROSE MALLOW AVE	41+46.73
F7.B4.L9	ROSE MALLOW AVE	42+16.73
F7.B4.L10	ROSE MALLOW AVE	42+79.53

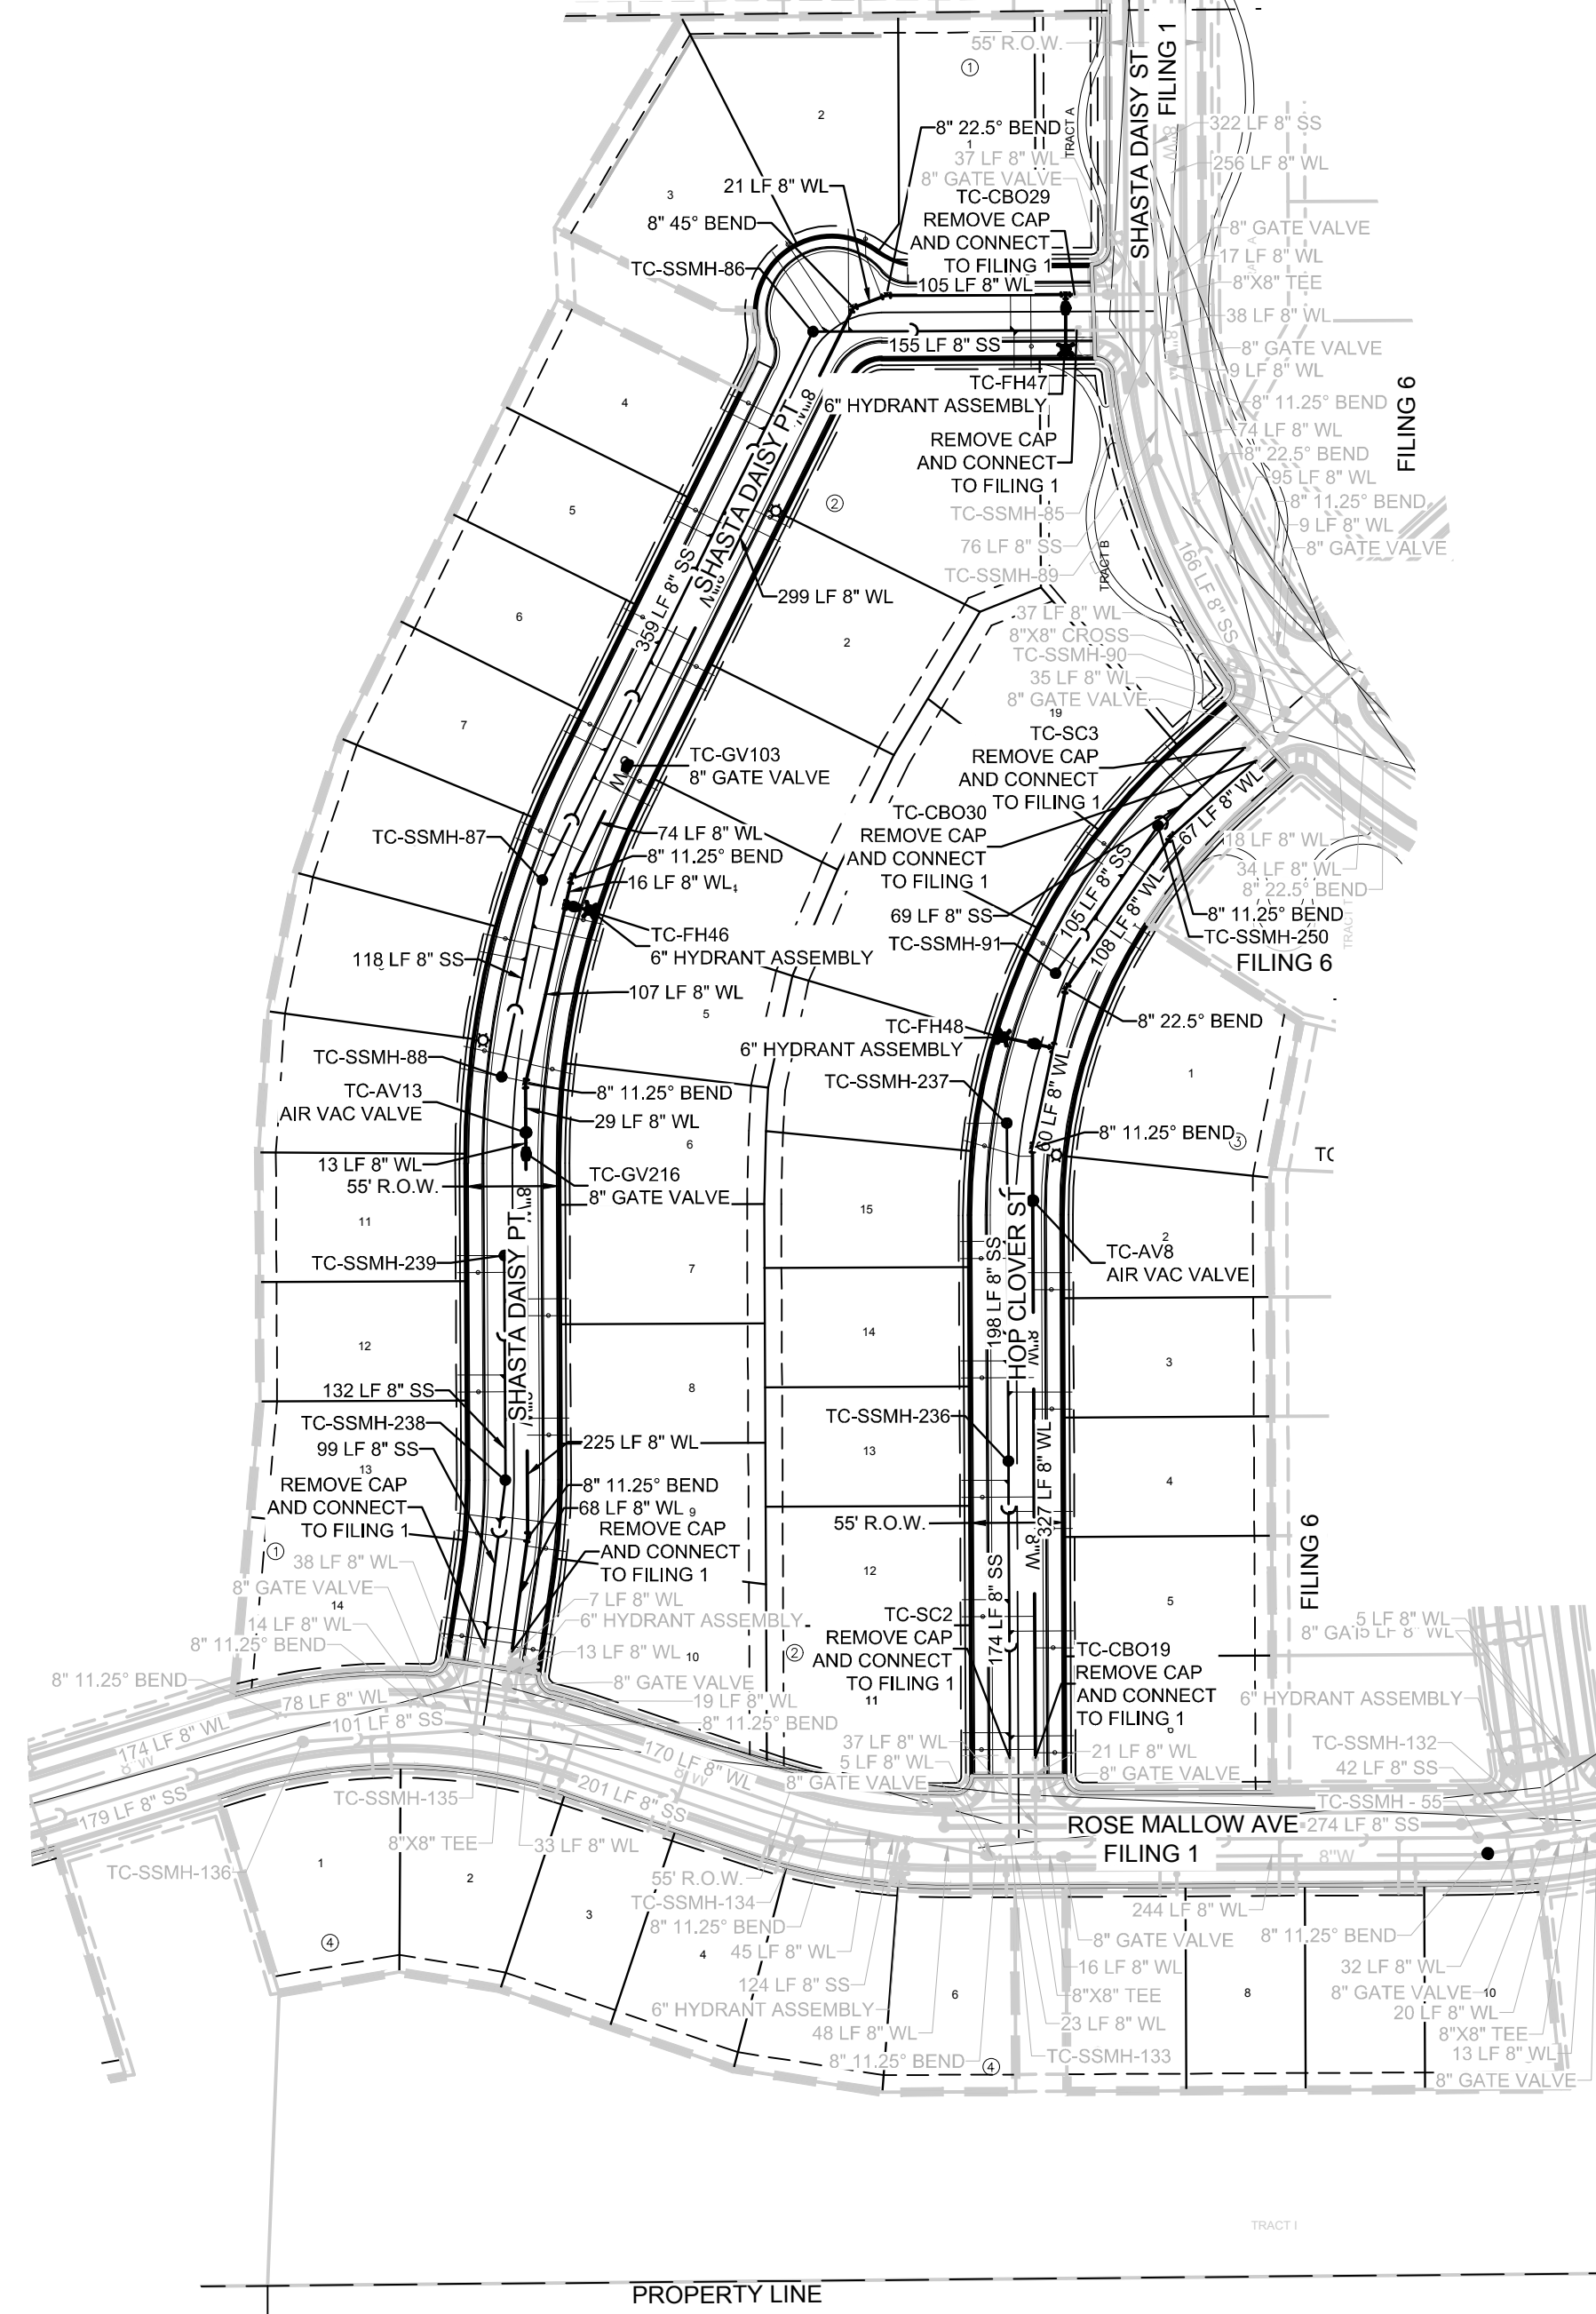

THE TOWN OF PARKER REVIEW CONSTITUTES GENERAL COMPLIANCE WITH THE TOWN'S STANDARDS AND APPROVED VARIANCES. SUBJECT TO THESE PLANS BEING STAMPED, SIGN, AND DATED BY THE PROFESSIONAL ENGINEER OF RECORD. REVIEW BY THE TOWN DOES NOT CONSTITUTE APPROVAL OF THE PLAN DESIGN OR ACCURACY AND CORRECTNESS OF ENGINEERING CALCULATIONS. ERRORS IN THE DESIGN OR CALCULATIONS REMAIN THE RESPONSIBILITY OF THE REGISTERED PROFESSIONAL ENGINEER WHOSE STAMP AND SIGNATURE ARE AFFIXED TO THIS DOCUMENT.

THIS REVIEW DOES NOT CONSTITUTE APPROVAL OF ANY PRIVATE ON-SITE IMPROVEMENTS WHICH MAY BE SHOWN. CONSTRUCTION CANNOT COMMENCE UNTIL ALL REQUIRED DRAINAGE/TRAFFIC REPORT(S), FINAL DEVELOPMENT PLAN(S), SPECIAL REVIEW(S), GRADING PERMIT, AND/OR OTHER PERMITS ARE COMPLETE, APPROVED AND ON FILE WITH THE TOWN OF PARKER.

TOWN OF PARKER, DIRECTOR OF ENGINEERING

DATE

PREPARED UNDER THE SUPERVISION OF

BRIAN P. WILSON
COLORADO P.E. 0050067

0050067
BRIAN P. WILSON
PROFESSIONAL ENGINEER

THE DISTRICT INSPECTOR MUST BE NOTIFIED AT LEAST 48 HOURS PRIOR TO START OF CONSTRUCTION. CALL PARKER WATER AND SANITATION DISTRICT AT 303-841-4627. THE DISTRICT WILL PROVIDE PERIODIC INSPECTIONS OF THE WORK. 24 HOUR NOTICE TO THE INSPECTOR IS REQUIRED FOR SCHEDULELINE INSPECTIONS. ANY WORK ACCOMPLISHED WITHOUT THE APPROVAL OF THE INSPECTOR WILL BE SUBJECT TO REJECTION.

REVIEWED FOR CONFORMANCE TO PARKER WATER AND SANITATION DISTRICT STANDARDS.

BY: (DISTRICT REPRESENTATIVE)

DATE

APPROVED FOR CONSTRUCTION:
PARKER WATER AND SANITATION DISTRICT

BY: (DISTRICT ENGINEER)

DATE

2

A

6

PROPOSED BUTTERFLY VALVE

PROPOSED CAP WITH END OF LINE BLOWOFF

PROPOSED REDUCER

PROPOSED VALVE

PROPOSED FIRE HYDRANT

PROPOSED WL FITTING WITH THRUST BLOCK

PROPOSED FLARED END SECTION

PROPOSED LOW POINT BLOW-OFF

PROPOSED AIR VALVE

FUTURE PHASE VALVE

FUTURE FIRE HYDRANT

PROPOSED LIGHT POLE

PROPOSED SIDEWALK

PROPOSED SIDEWALK RAMP

10.00

EXISTING ELEVATION

10.00

PROPOSED DESIGN ELEVATION

PROPOSED STORM DRAIN INLET

4 5 6

PROPOSED STORM DRAIN MANHOLE

PROPOSED RANGE POINT

CENTERLINE

RIGHT-OF-WAY

PROPERTY LINE

EDGE OF PAVEMENT

PROPOSED DIRECTION OF FLOW

PROPOSED SLOPE & DIRECTION

EXISTING 5' CONTOUR

EXISTING 1' CONTOUR

PROPOSED 5' CONTOUR

PROPOSED 1' CONTOUR

PROPOSED STORM DRAIN

PROPOSED SEWER LINE WITH MANHOLE

PROPOSED SEWER LATERAL

PROPOSED WATER LINE

PROPOSED WATER LATERAL W/ METER

SECTION LINE

FILING BOUNDARY

EXISTING FIBER OPTIC LINE

EXISTING OVERHEAD POWER

EXISTING TELEPHONE LINE

ABBREVIATIONS

AD

AV

BVC

BVP

CBO

CRR

EL

EP

EVC

EVP

FG

FH

FL

GV

HCR

HP

INV

K

LF

ANGLE DIFFERENCE

AIR VAC RELEASE VALVE

BEGIN VERTICAL CURVE

BEGIN VERTICAL PROFILE

CAP WITH BLOW OFF

CURB RETURN RADIUS

ELEVATION

EDGE OF PAVEMENT

END VERTICAL CURVE

END VERTICAL PROFILE

FINISHED GROUND

FIRE HYDRANT

FLOW LINE

GATE VALVE

HANDICAP CURB RAMP

HIGH POINT

INVERT

CURVATURE COEFFICIENT

LINEAR FEET

MH

N.T.S.

NOT TO SCALE

PVC

PT. OF VERTICAL INTERSECTION

PVT

POINT OF VERTICAL TANGENT

RCBC

REINFORCED CONCRETE BOX CULVERT

RCP

REINFORCED CONCRETE PIPE

ROW

RIGHT OF WAY

SC

SANITARY CAP

SD

STORM DRAIN

SL

SECTION LINE

SS

SANITARY SEWER

STA

STATION

T.O.P.

TOP OF PIPE

UE

UTILITY EASEMENT

VC

VERTICAL CURVE

WL


WATER LINE

WLC

WATER LINE CONNECTION


WSE

WATER SURFACE ELEVATION

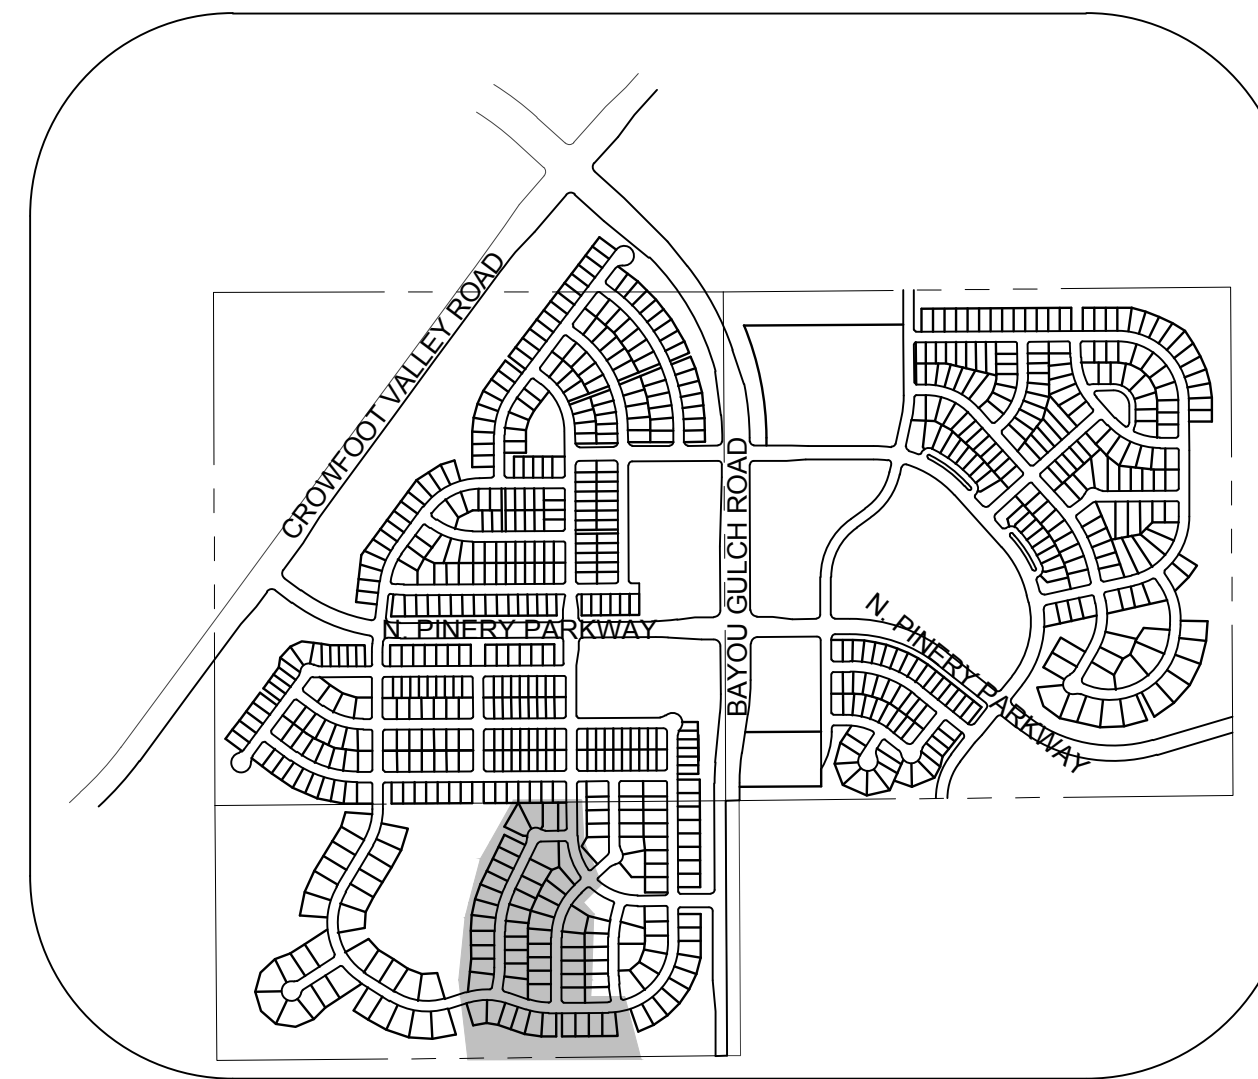

KEYMAP N.T.S. LEGEND

10338 E. Dry Creek Rd.
Denver, CO 80140
Englewood, CO 80110
Tel: (720) 482-9526
Fax: (720) 482-9546

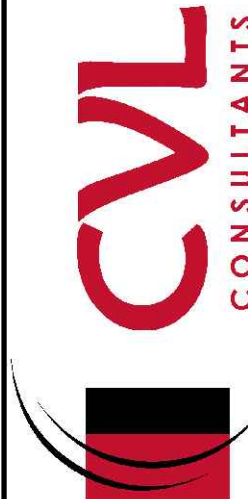


HR 935 LLC
7353 South Alton Way
CENTENNIAL, CO 80112

TRAILS AT CROWFOOT
FILING 7 CONSTRUCTION DRAWINGS
AREA UTILITY PLAN

SCALE:
AS SHOWN
FILE NO:
8130283701

DRAWN BY: JLR
CHECKED BY: JJJ
DATE: AUGUST 2017

SHEET NUMBER
3

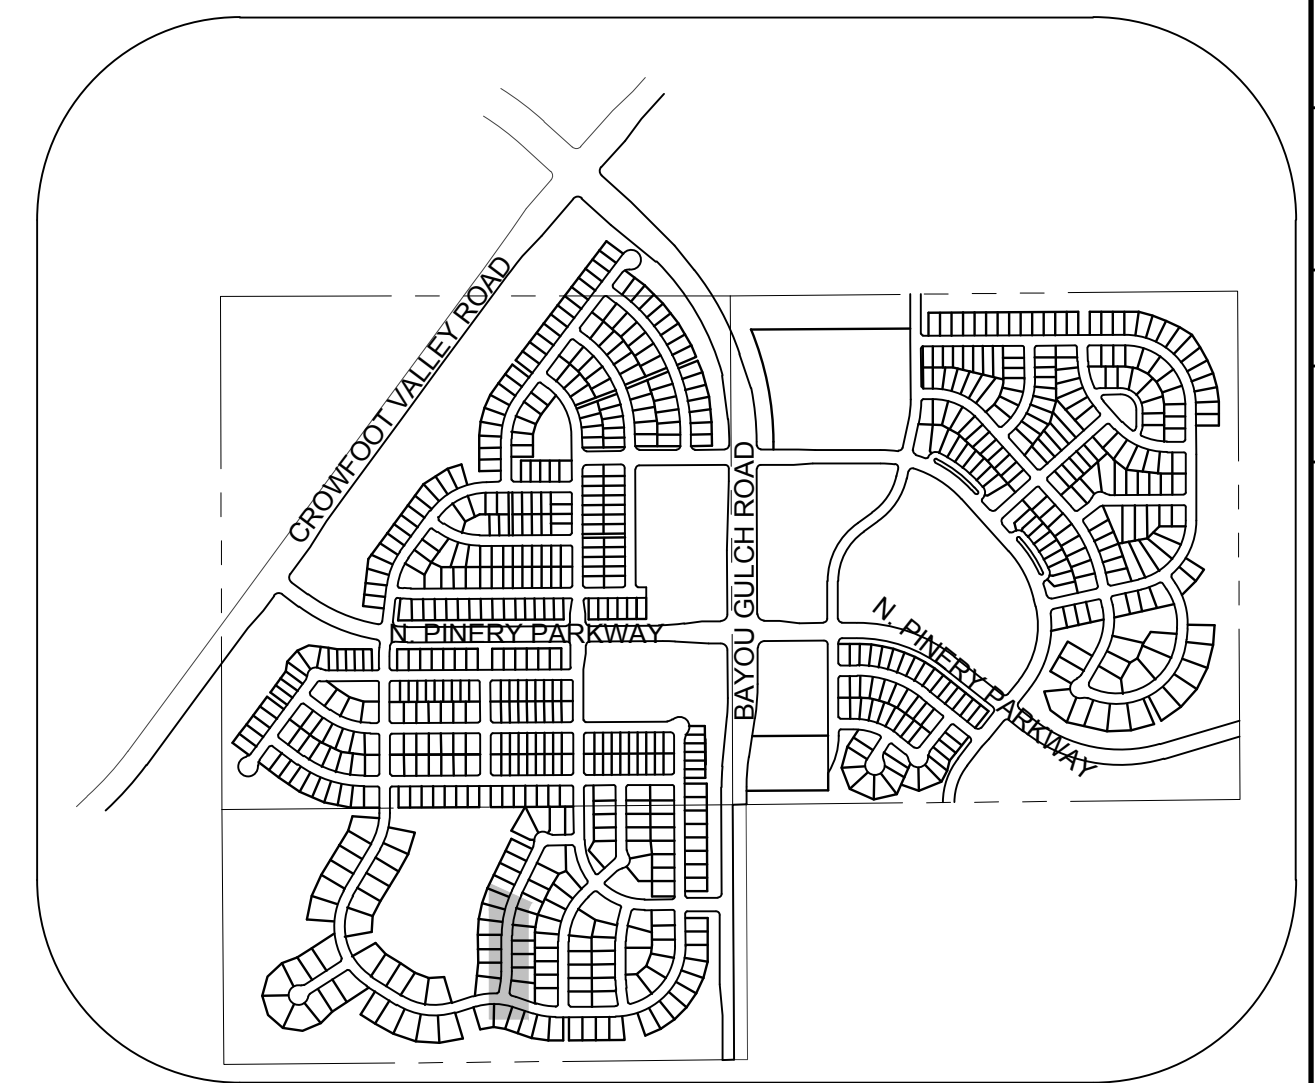

HP ELEV = 6175.67
HP STA = 13+34.46
PVI ELEV = 6178.92
PVI STA = 13+69.18
AD = -11.00%
K = 23.17
255.0' VC




BASIS OF BEARINGS:
THE EAST LINE OF THE NORTHEAST QUARTER OF SAID SECTION 9 BEING MONUMENTED AT THE NORTHEAST CORNER OF SAID SECTION 9 BY A 3-1/4" ALUMINUM CAP STAMPED LS 23053 AND AT THE EAST QUARTER CORNER OF SAID SECTION 9 BY A 2-1/2" ALUMINUM CAP STAMPED LS 6935 BEING CONSIDERED TO BEAR SOUTH 00°15'06" EAST, 2648.70 FEET.

ABBREVIATIONS			
AD	ANGLE DIFFERENCE	MH	MANHOLE
AV	AIR VAC RELEASE VALVE	N.T.S.	NOT TO SCALE
BVC	BEGIN VERTICAL CURVE	PVC	POLYVINYL CHLORIDE
BVP	BEGIN VERTICAL PROFILE	PT	POINT OF VERTICAL INTERSECTION
CBO	CAP WITH BLOW OFF	PVT	POINT OF VERTICAL TANGENT
CRB	CURB RETURN RADIUS	RCCB	REINFORCED CONCRETE BOX CULVERT
EL	ELEVATION	RCP	REINFORCED CONCRETE PIPE
EP	EDGE OF PAVEMENT	ROW	RIGHT OF WAY
EVC	END VERTICAL CURVE	SC	SANITARY CAP
EVP	END VERTICAL PROFILE	SD	STORM DRAIN
FG	FINISHED GROUND	SL	SECTION LINE
FH	FIRE HYDRANT	SS	SANITARY SEWER
FL	FLOW LINE	STA	STATION
GV	GATE VALVE	T.O.P.	TOP OF PIPE
HCR	HANDICAP CURB RAMP	UE	UTILITY EASEMENT
HP	HIGH POINT	VC	VERTICAL CURVE
INV	INVERT	WL	WATER LINE
K	CURVATURE COEFFICIENT	WLC	WATER LINE CONNECTION
LF	LINEAR FEET	WSE	WATER SURFACE ELEVATION


4



\\PROJECTS\HSS RANCH\CAD\ENGINEERING\3\17\PARKER WATER AND SANITATION\SANITARY PLAN AND PROFILE\17 SHASTA DAISY TERRACE SANITARY.DWG, CODYA, 3/5/2018 4:22 PM

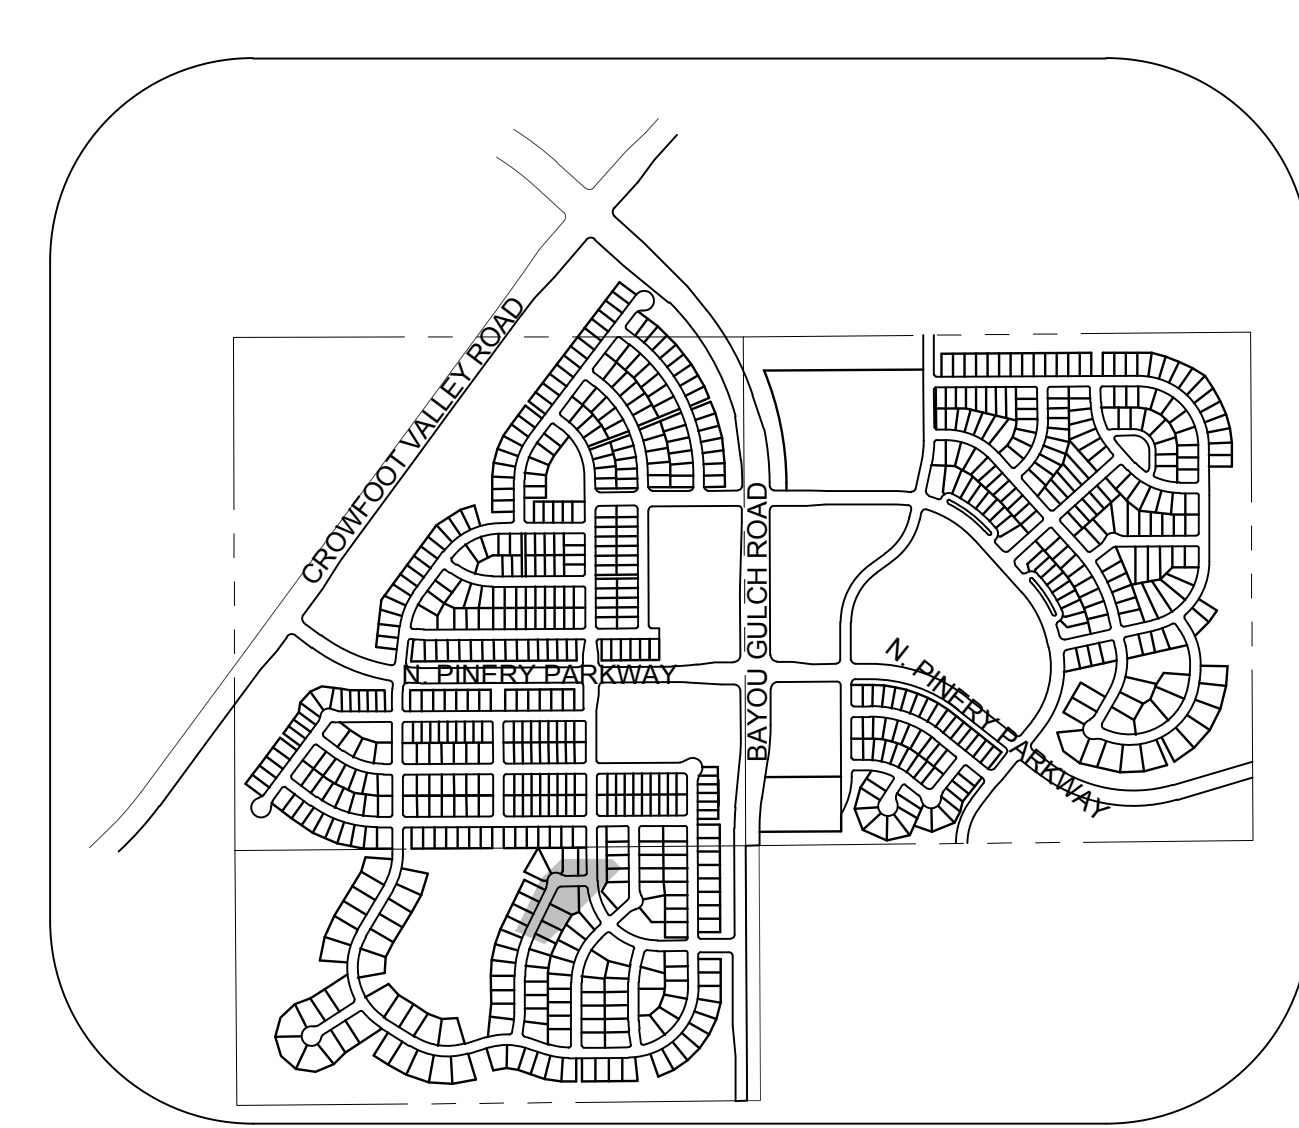

PLAN: SHASTA DAISY POINT STA: 15+50.00 TO 22+00.00
HORIZONTAL SCALE: 1" = 50'

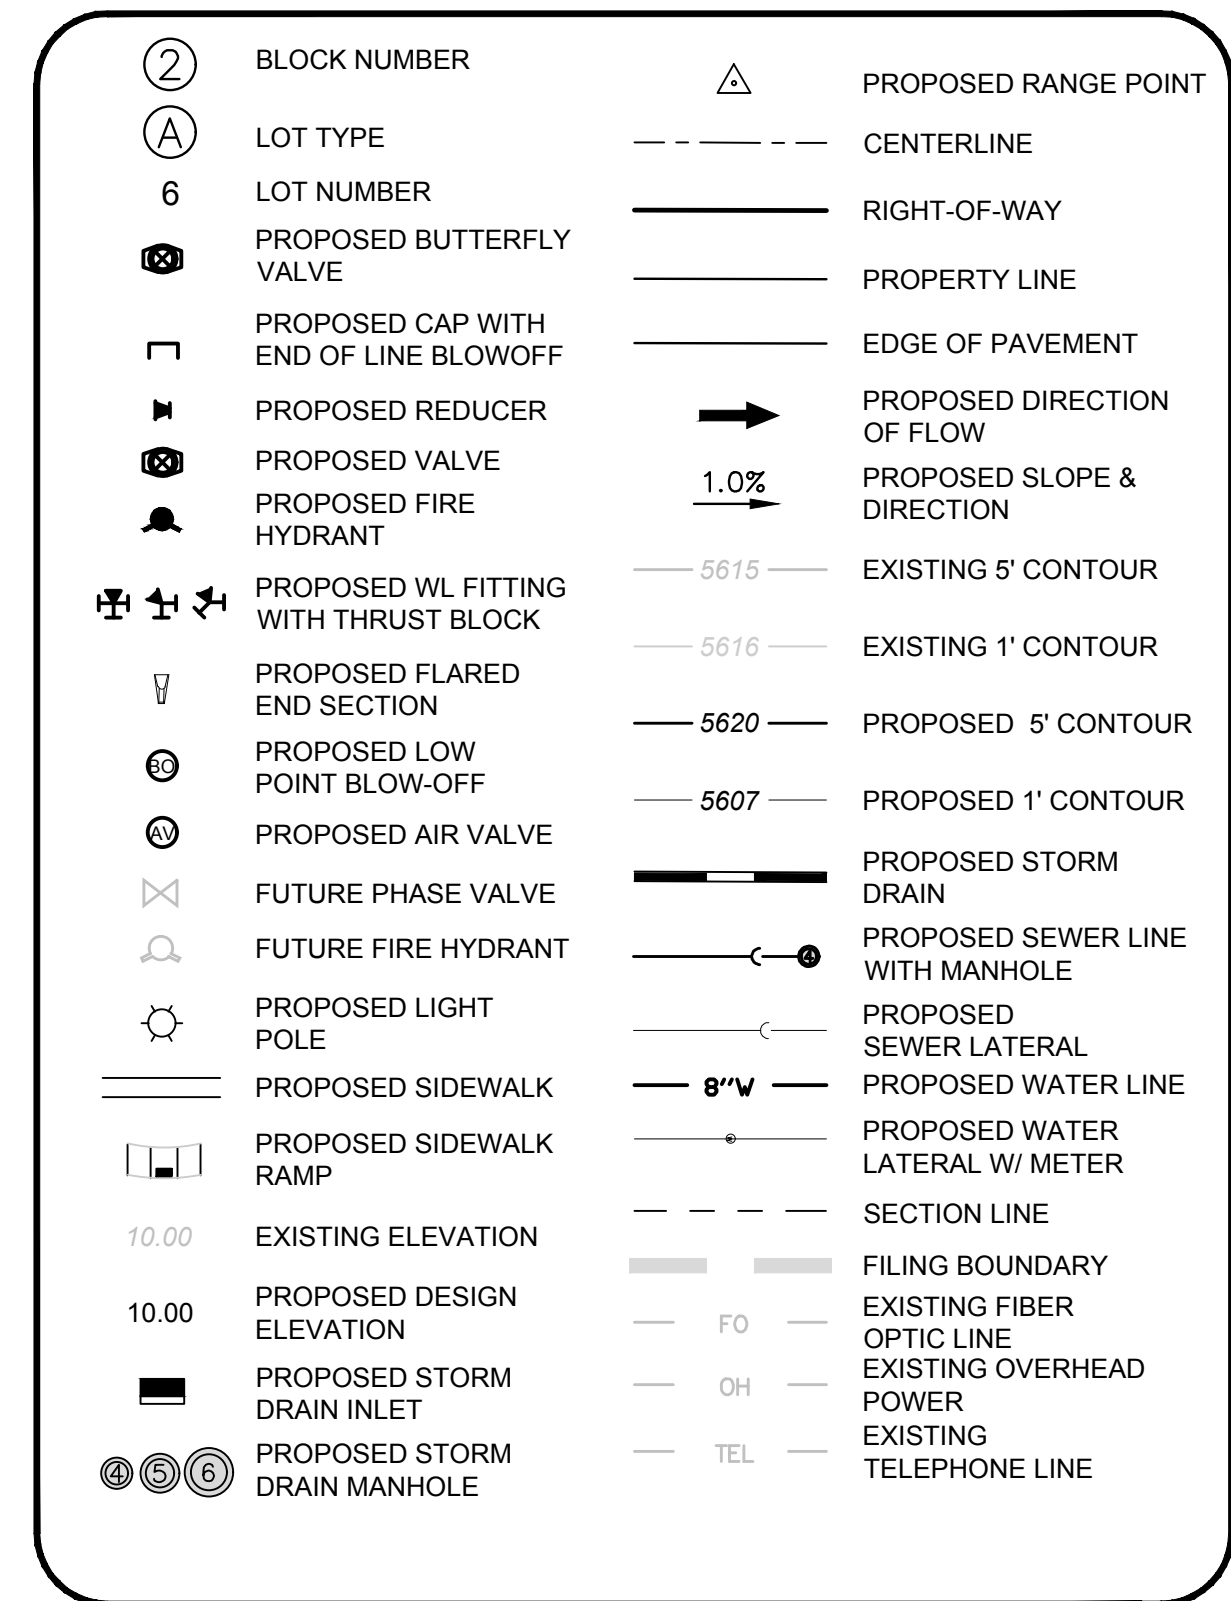


ABBREVIATIONS

AD	ANGLE DIFFERENCE	MH	MANHOLE
AV	AIR VAC RELEASE VALVE	M.T.S.	NOT TO SCALE
BVC	BEGIN VERTICAL CURVE	PVC	POLYVINYL CHLORIDE
BVP	BEGIN VERTICAL PROFILE	PVI	PT. OF VERTICAL INTERSECTION
CBR	CAP WITH BLOW OFF	PVT	POINT OF VERTICAL TANGENT
CRO	CURB RETURN RADIUS	RCBC	REINFORCED CONCRETE BOX CULVERT
EL	ELEVATION	RCP	REINFORCED CONCRETE PIPE
EP	EDGE OF PAVEMENT	ROW	RIGHT OF WAY
EVC	END VERTICAL CURVE	SC	SANITARY CAP
EVF	END VERTICAL PROFILE	SD	STORM DRAIN
FG	FINISHED GROUND	SL	SECTION LINE
FH	FIRE HYDRANT	SS	SANITARY SEWER
FL	FLOW LINE	ST	STATION
GV	GATE VALVE	T.O.P.	TOP OF PIPE
HCR	HANDICAP CURB RAMP	UE	UTILITY EASEMENT
HP	HIGH POINT	VC	VERTICAL CURVE
INV	INVERT	WL	WATER LINE
K	CURVATURE COEFFICIENT	WLC	WATER LINE CONNECTION
LF	LINEAR FEET	WSE	WATER SURFACE ELEVATION

BASIS OF BEARINGS:
THE EAST LINE OF THE NORTHEAST QUARTER OF SAID SECTION 9
BEING MONUMENTED AT THE NORTHEAST CORNER OF SAID
SECTION 9 BY A 3-1/4" ALUMINUM CAP STAMPED LS 23053 AND AT
THE EAST QUARTER CORNER OF SAID SECTION 9 BY A 2-1/2"
ALUMINUM CAP STAMPED LS 6935 BOTH BEING CONSIDERED TO BEAR
SOUTH 00°15'06" EAST, 2648.70 FEET.

 **CALL 811**
TWO WORKING DAYS
BEFORE YOU DIG
1-800-922-1987

SHEET NUMBER 5	DRAWN BY:	KJD	SCALE:	TRAILS AT CROWFOOT FILING 7 CONSTRUCTION DRAWINGS SANITARY SEWER PLAN AND PROFILE SHASTA DAISY POINT		 HR 935 LLC 7353 South Alton Way CENTENNIAL, CO 80112	10333 E. Dry Creek Rd. Suite 240 Englewood, CO 80112 Tel: (720) 482-9526 Fax: (720) 482-9546				
	CHECKED BY:	JJJ	FILE NO:								
	DATE:	AUGUST 2017	8130283701								
	No.	Revisions		Date	Init.			Appr.	Date		

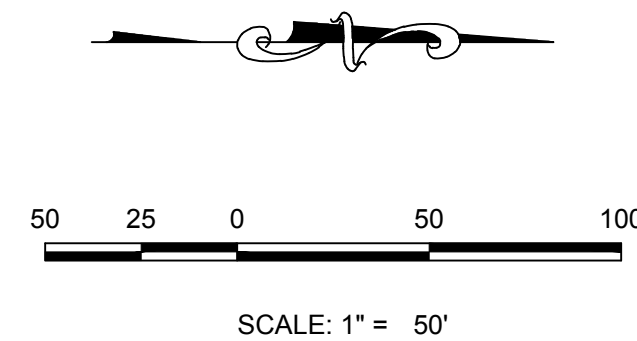

	BLOCK NUMBER		PROPOSED RANGE POINT
	LOT TYPE	- - - - -	CENTERLINE
6	LOT NUMBER		RIGHT-OF-WAY
	PROPOSED BUTTERFLY VALVE		PROPERTY LINE
	PROPOSED CAP WITH END OF LINE BLOWOFF		EDGE OF PAVEMENT
	PROPOSED REDUCER		PROPOSED DIRECTION OF FLOW
	PROPOSED VALVE		PROPOSED SLOPE & DIRECTION
	PROPOSED FIRE HYDRANT		EXISTING 5' CONTOUR
	PROPOSED WL FITTING WITH THRUST BLOCK		EXISTING 1' CONTOUR
	PROPOSED FLARED END SECTION		PROPOSED 5' CONTOUR
	PROPOSED LOW POINT BLOW-OFF		PROPOSED 1' CONTOUR
	PROPOSED AIR VALVE		PROPOSED STORM DRAIN
	FUTURE PHASE VALVE		PROPOSED SEWER LINE WITH MANHOLE
	FUTURE FIRE HYDRANT		PROPOSED SEWER LATERAL
	PROPOSED LIGHT POLE		PROPOSED WATER LINE
	PROPOSED SIDEWALK		PROPOSED WATER LATERAL W/ METER
	PROPOSED SIDEWALK RAMP	- - - - -	SECTION LINE
10.00	EXISTING ELEVATION		FILING BOUNDARY
10.00	PROPOSED DESIGN ELEVATION		EXISTING FIBER OPTIC LINE
	PROPOSED STORM DRAIN INLET		EXISTING OVERHEAD POWER
	PROPOSED STORM DRAIN MANHOLE		EXISTING TELEPHONE LINE

AD	ANGLE DIFFERENCE	MH	MANHOLE
AV	AIR VAC RELEASE VALVE	N.T.S.	NOT TO SCALE
BVC	BEGIN VERTICAL CURVE	PVC	POLYVINYL CHLORIDE
BVP	BEGIN VERTICAL PROFILE	PVI	POINT OF VERTICAL INTERSECTION
CBO	CAP WITH BLOW OFF	PVT	POINT OF VERTICAL TANGENT
CRR	CURB RETURN RADIUS	RCBT	REINFORCED CONCRETE BOX CULVERT
EL	ELEVATION	RCP	REINFORCED CONCRETE PIPE
EP	EDGE OF PAVEMENT	ROW	RIGHT OF WAY
EVC	END VERTICAL CURVE	SC	SANITARY CAP
EVP	END VERTICAL PROFILE	SD	STORM DRAIN
FG	FINISHED GROUND	SL	SECTION LINE
FH	FIRE HYDRANT	SS	SANITARY SEWER
FL	FLOW LINE	STA	STATION
GV	GATE VALVE	T.O.P.	TOP OF PIPE
HCR	HANDICAP CURB RAMP	UE	UTILITY EASEMENT
HP	HIGH POINT	VC	VERTICAL CURVE
INV	INVERT	WL	WATER LINE
K	CURVATURE COEFFICIENT	WLC	WATER LINE CONNECTION
LF	LINEAR FEET	WSE	WATER SURFACE ELEVATION





BASIS OF BEARINGS:
THE EAST LINE OF THE NORTHEAST QUARTER OF SAID SECTION 9
BEING MONUMENTED AT THE NORTHEAST CORNER OF SAID
SECTION 9 BY A 3-1/4" ALUMINUM CAP STAMPED LS 23053 AND AT
THE EAST QUARTER CORNER OF SAID SECTION 9 BY A 2-1/2"
ALUMINUM CAP STAMPED LS 6935 BEING CONSIDERED TO BEAR
SOUTH 00°15'06" EAST, 2648.70 FEET.





BRIAN P. WILSON
COLORADO P.E. 0050067

N:\PROJECTS\SHASTA\ENGINEERING\SHASTA DAISY TERRACE WATER DWS, CDD\Y.A. 3/6/2018 4:30 PM

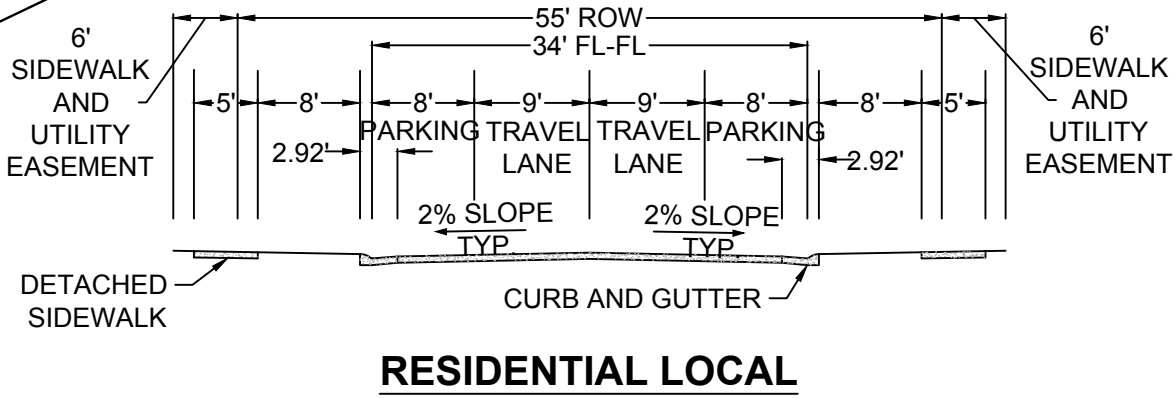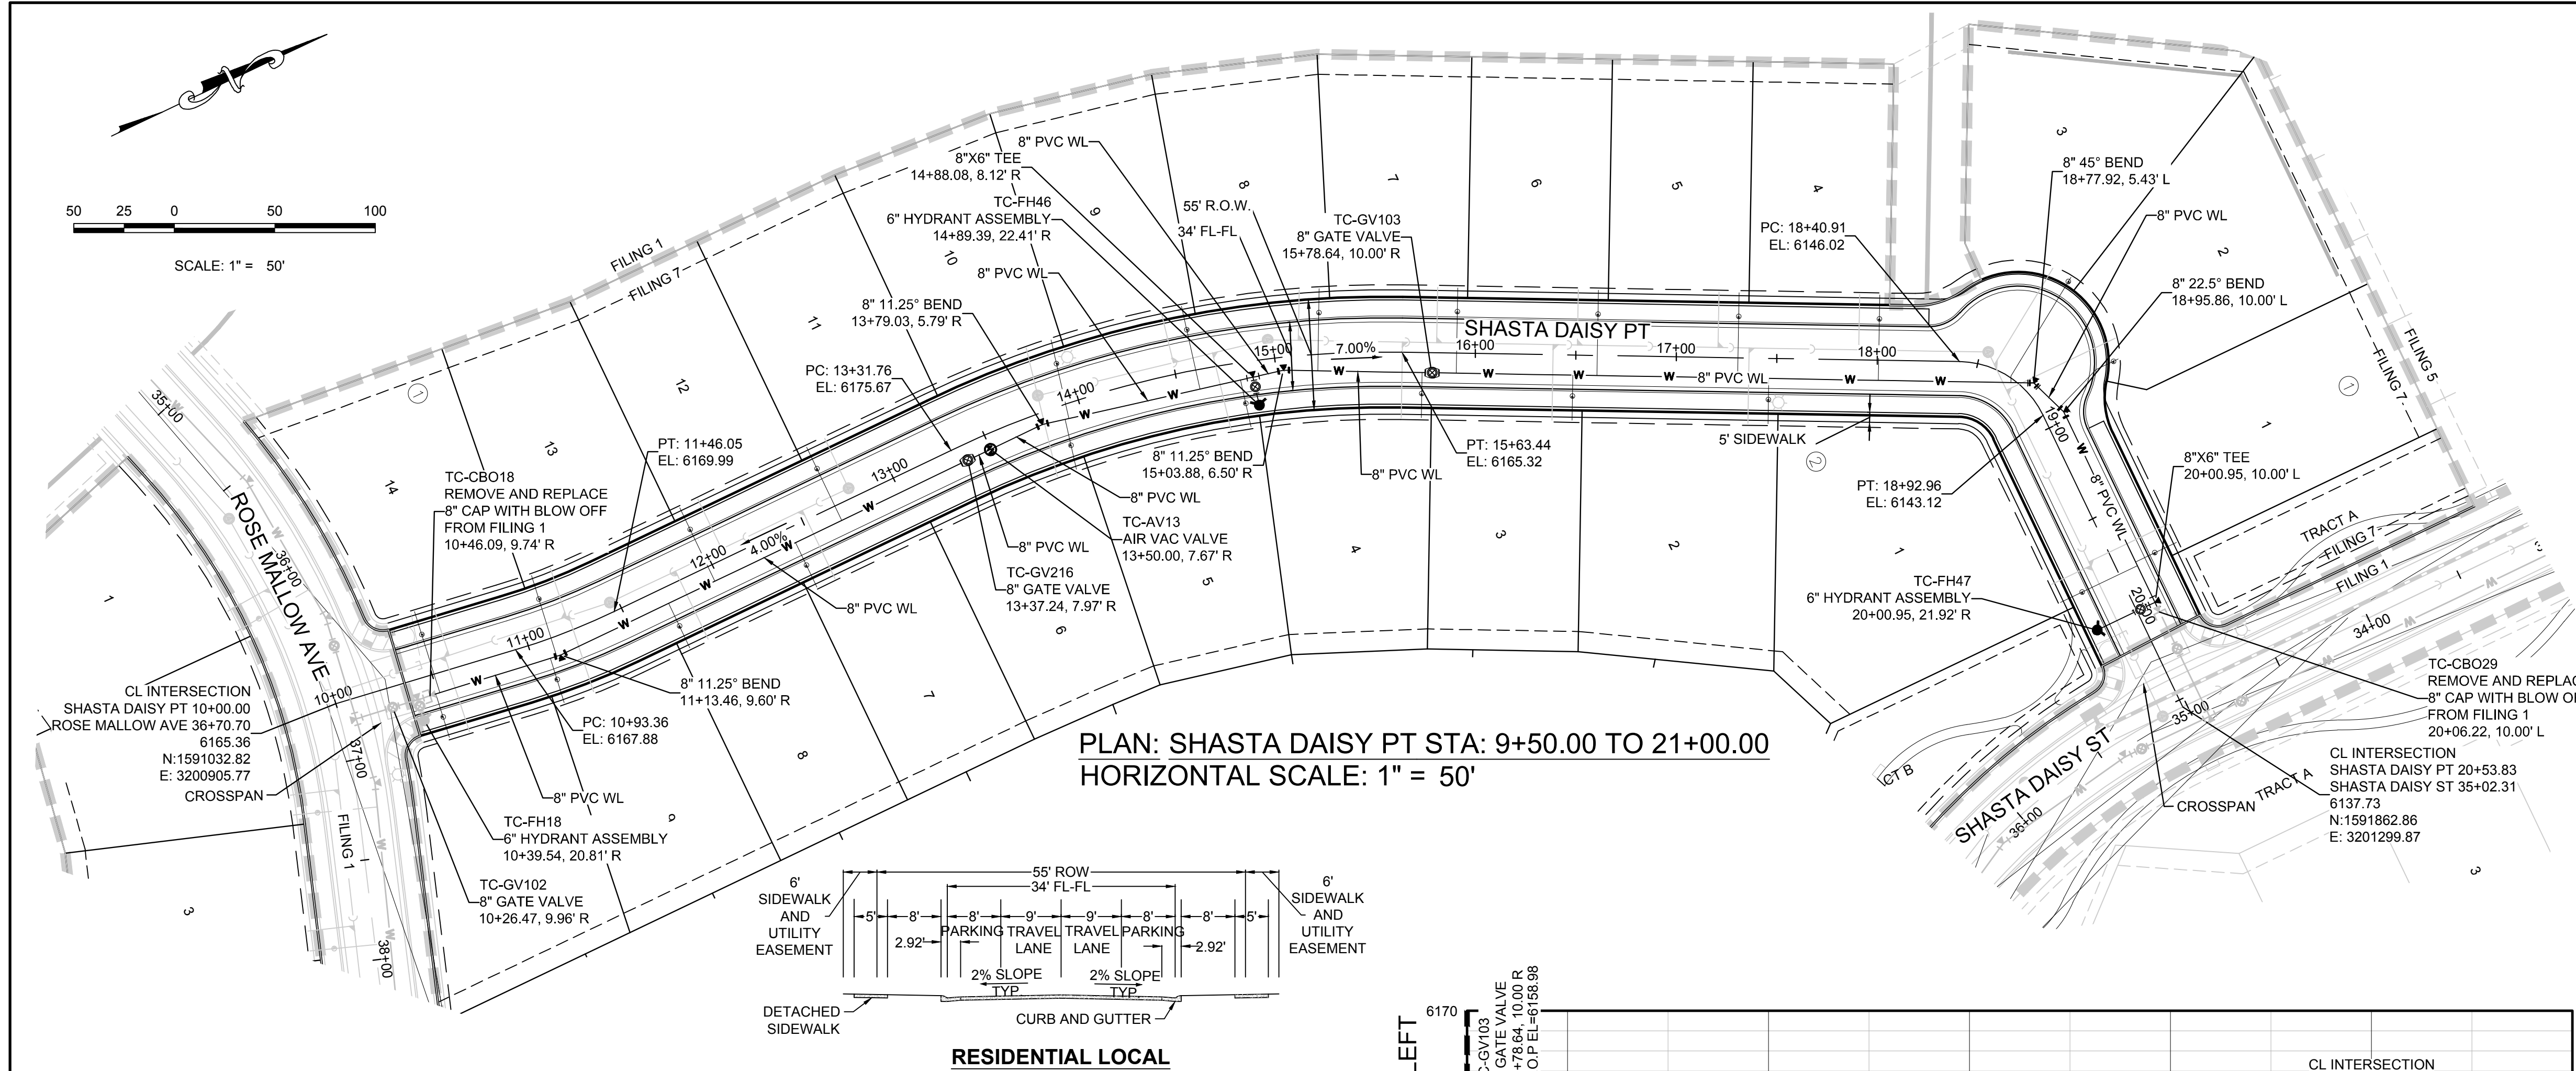

MATCHLINE - SEE LEFT

MATCHLINE - SEE RIGHT

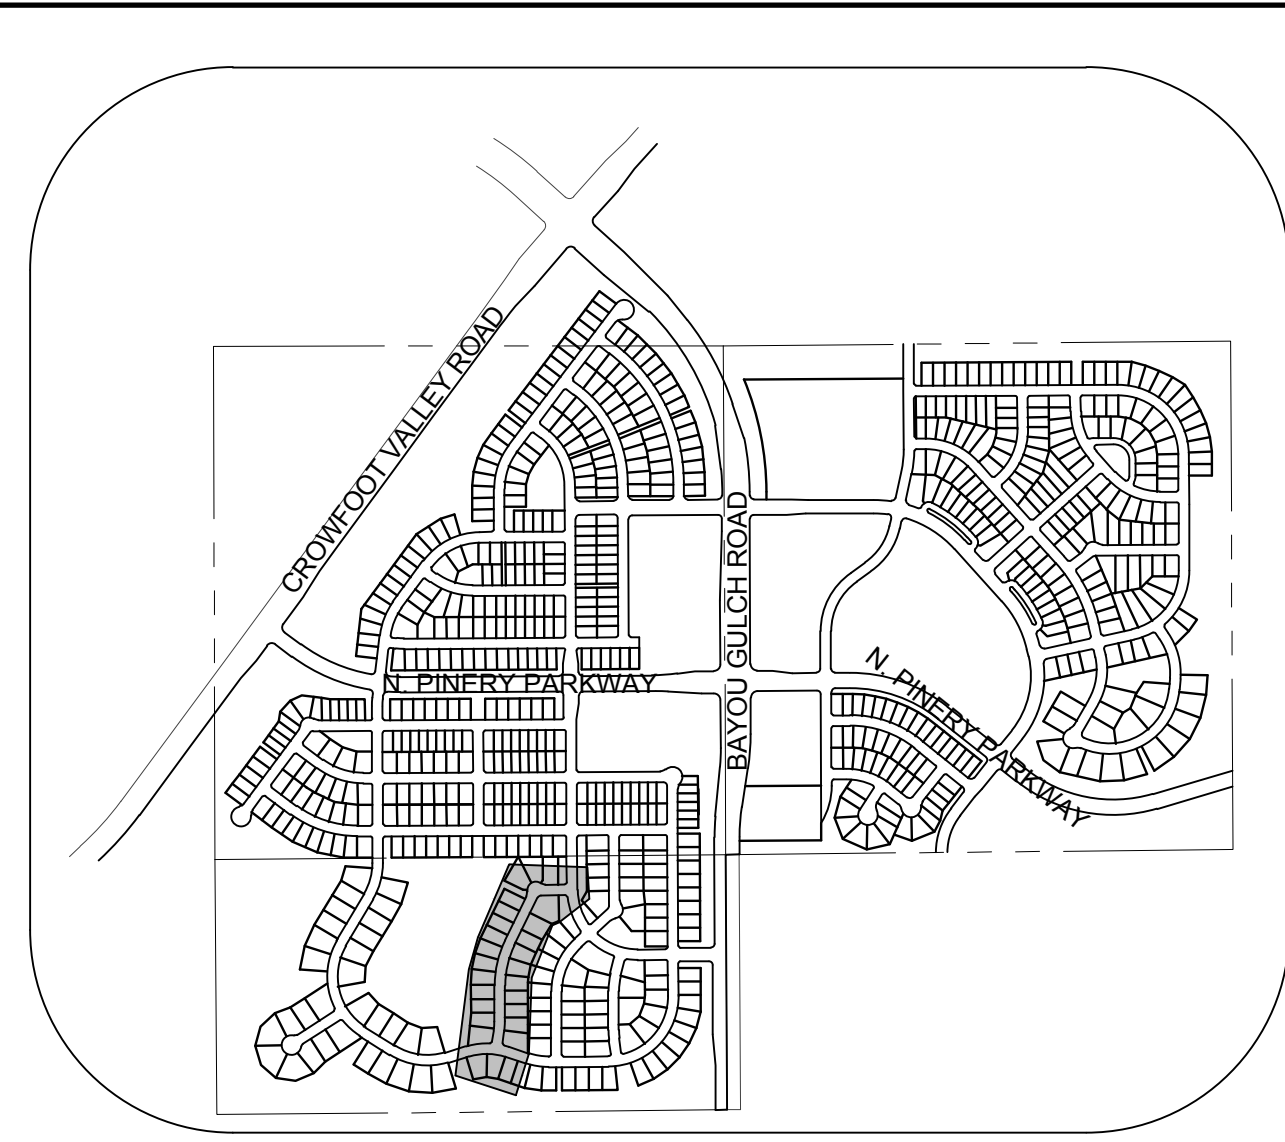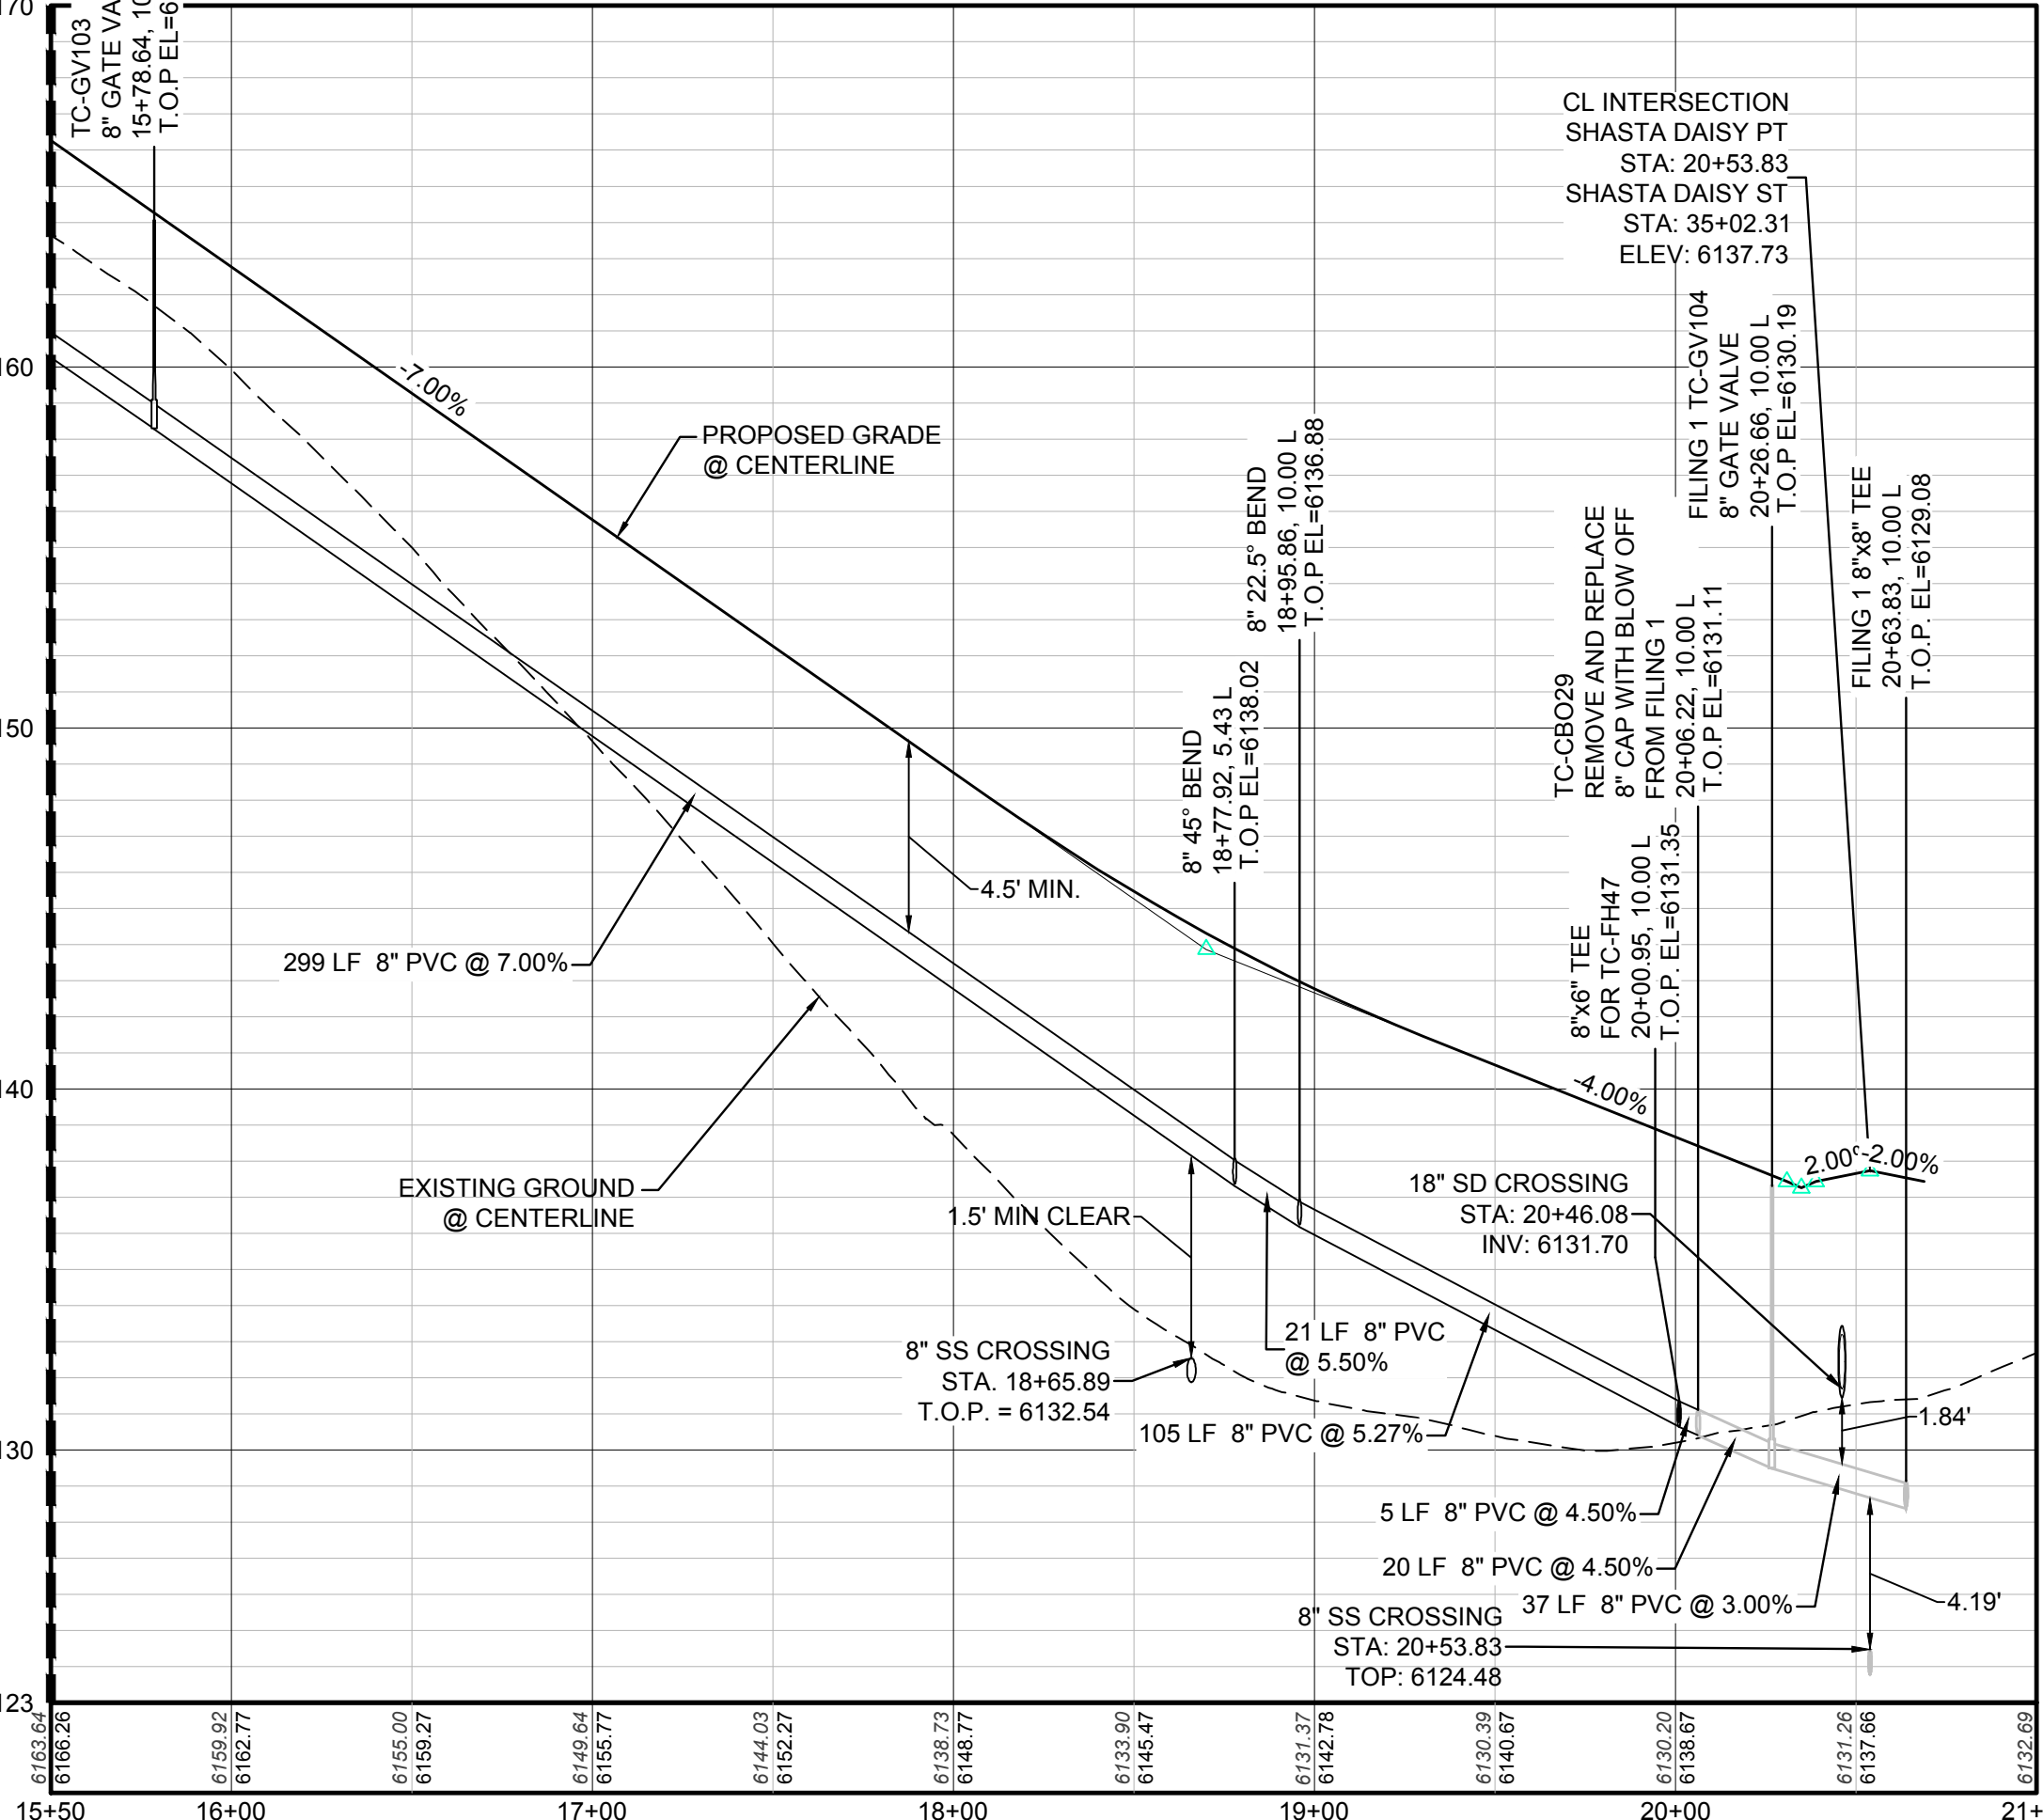

KEYMAP
N.T.S.
LEGEND

- | | |
|---|--------------------------------------|
| 2 BLOCK NUMBER | △ PROPOSED RANGE POINT |
| Ⓐ LOT TYPE | --- CENTERLINE |
| 6 LOT NUMBER | --- RIGHT-OF-WAY |
| ⊕ PROPOSED BUTTERFLY VALVE | --- PROPERTY LINE |
| ⌋ PROPOSED CAP WITH END OF LINE BLOWOFF | --- EDGE OF PAVEMENT |
| ⌋ PROPOSED REDUCER | → PROPOSED DIRECTION OF FLOW |
| ⊕ PROPOSED VALVE | 1.0% PROPOSED SLOPE & DIRECTION |
| ⊕ PROPOSED FIRE HYDRANT | 5615 EXISTING 5' CONTOUR |
| ⊕ PROPOSED WL FITTING WITH THRUST BLOCK | 5616 EXISTING 1' CONTOUR |
| ⊕ PROPOSED FLARED END SECTION | 5620 PROPOSED 5' CONTOUR |
| ⊕ PROPOSED LOW POINT BLOW-OFF | 5607 PROPOSED 1' CONTOUR |
| ⊕ PROPOSED AIR VALVE | --- PROPOSED STORM DRAIN |
| ⊕ FUTURE PHASE VALVE | --- PROPOSED SEWER LINE WITH MANHOLE |
| ⊕ FUTURE FIRE HYDRANT | --- PROPOSED SEWER LATERAL |
| ⊕ PROPOSED LIGHT POLE | --- PROPOSED WATER LINE |
| ⊕ PROPOSED SIDEWALK RAMP | --- PROPOSED WATER LATERAL W/ METER |
| 10.00 EXISTING ELEVATION | --- SECTION LINE |
| 10.00 PROPOSED DESIGN ELEVATION | --- FILING BOUNDARY |
| ⊕ PROPOSED STORM DRAIN INLET | --- FO EXISTING FIBER OPTIC LINE |
| ⊕ PROPOSED STORM DRAIN MANHOLE | --- OH EXISTING OVERHEAD POWER |
| | --- TEL EXISTING TELEPHONE LINE |

ABBREVIATIONS

- | | |
|----------------------------|--------------------------------------|
| AD ANGLE DIFFERENCE | MH MANHOLE |
| AV AIR VAC RELEASE VALVE | N.T.S. NOT TO SCALE |
| BVC BEGIN VERTICAL CURVE | PVC POLYVINYL CHLORIDE |
| BVP BEGIN VERTICAL PROFILE | PVI PT. OF VERTICAL INTERSECTION |
| CBO CAP WITH BLOW OFF | PVT POINT OF VERTICAL TANGENT |
| CRR CURB RETURN RADIUS | RCBC REINFORCED CONCRETE BOX CULVERT |
| EL ELEVATION | RCP REINFORCED CONCRETE PIPE |
| EP EDGE OF PAVEMENT | ROP RIGHT OF WAY |
| EVC END VERTICAL CURVE | SC SANITARY CAP |
| EVP END VERTICAL PROFILE | SD STORM DRAIN |
| FG FINISHED GROUND | SL SECTION LINE |
| FH FIRE HYDRANT | SS SANITARY SEWER |
| FL FLOW LINE | STA STATION |
| GV GATE VALVE | T.O.P. TOP OF PIPE |
| HCR HANDICAP CURB RAMP | UE UTILITY EASEMENT |
| HP HIGH POINT | VC VERTICAL CURVE |
| INV INVERT | WL WATER LINE |
| K CURVATURE COEFFICIENT | WLC WATER LINE CONNECTION |
| LF LINEAR FEET | WSE WATER SURFACE ELEVATION |

CALL 811
TWO WORKING DAYS
BEFORE YOU DIG
UNCC 1-800-922-1987

BENCHMARK
DOUGLAS COUNTY CONTROL POINT KNOWN AS 1.060032, BEING A 3-1/4" ALUMINUM CAP, BEING LOCATED IN THE SOUTHWEST QUARTER OF SECTION 33, TOWNSHIP 6 SOUTH, RANGE 66 WEST OF THE SIXTH PRINCIPAL MERIDIAN, HAVING A PUBLISHED ELEVATION OF 1799.2870 METERS (5903.13 FEET) NAVD '88 DATUM.

BASIS OF BEARINGS:
THE EAST LINE OF THE NORTHEAST QUARTER OF SAID SECTION 9 BEING MONUMENTED AT THE NORTHEAST CORNER OF SAID SECTION 9 BY A 3-1/4" ALUMINUM CAP STAMPED LS 23053 AND AT THE EAST QUARTER CORNER OF SAID SECTION 9 BY A 2-1/2" ALUMINUM CAP STAMPED LS 6935 BEING CONSIDERED TO BEAR SOUTH 00°15'06" EAST, 2648.70 FEET.

PREPARED UNDER THE SUPERVISION OF
BRIAN P. WILSON
COLORADO P.E. 0050067

SHEET NUMBER	DRAWN BY:	CHECKED BY:	DATE:	SCALE:	AS SHOWN	FILE NO:	Revisions	Date	Appr.	Date
7	RHR	JU	AUGUST 2017			8130283701				

TRAILS AT CROWFOOT
FILING 7 CONSTRUCTION DRAWINGS
WATER PLAN & PROFILE
SHASTA DAISY POINT

HR 935 LLC
7353 South Alton Way
CENTENNIAL, CO 80112


10333 E. Dry Creek Rd.
Englewood, CO 80110
Tel: (720) 482-9526
Fax: (720) 482-9546
CVL CONSULTANTS

N:\PROJECTS\SSR\BANCROFT\ENGINEERING\SSR\BANCROFT\WATER AND SANITATION\WATER PLAN AND PROFILE\7 DAMES ROCKET STREET WATER.DWG, CDDVA, 3/6/2018 4:33 PM



CALL 811
TWO WORKING DAYS
BEFORE YOU DIG
UNCC 1-800-922-1987

UTILITY NOTIFICATION
CENTER OF COLORADO

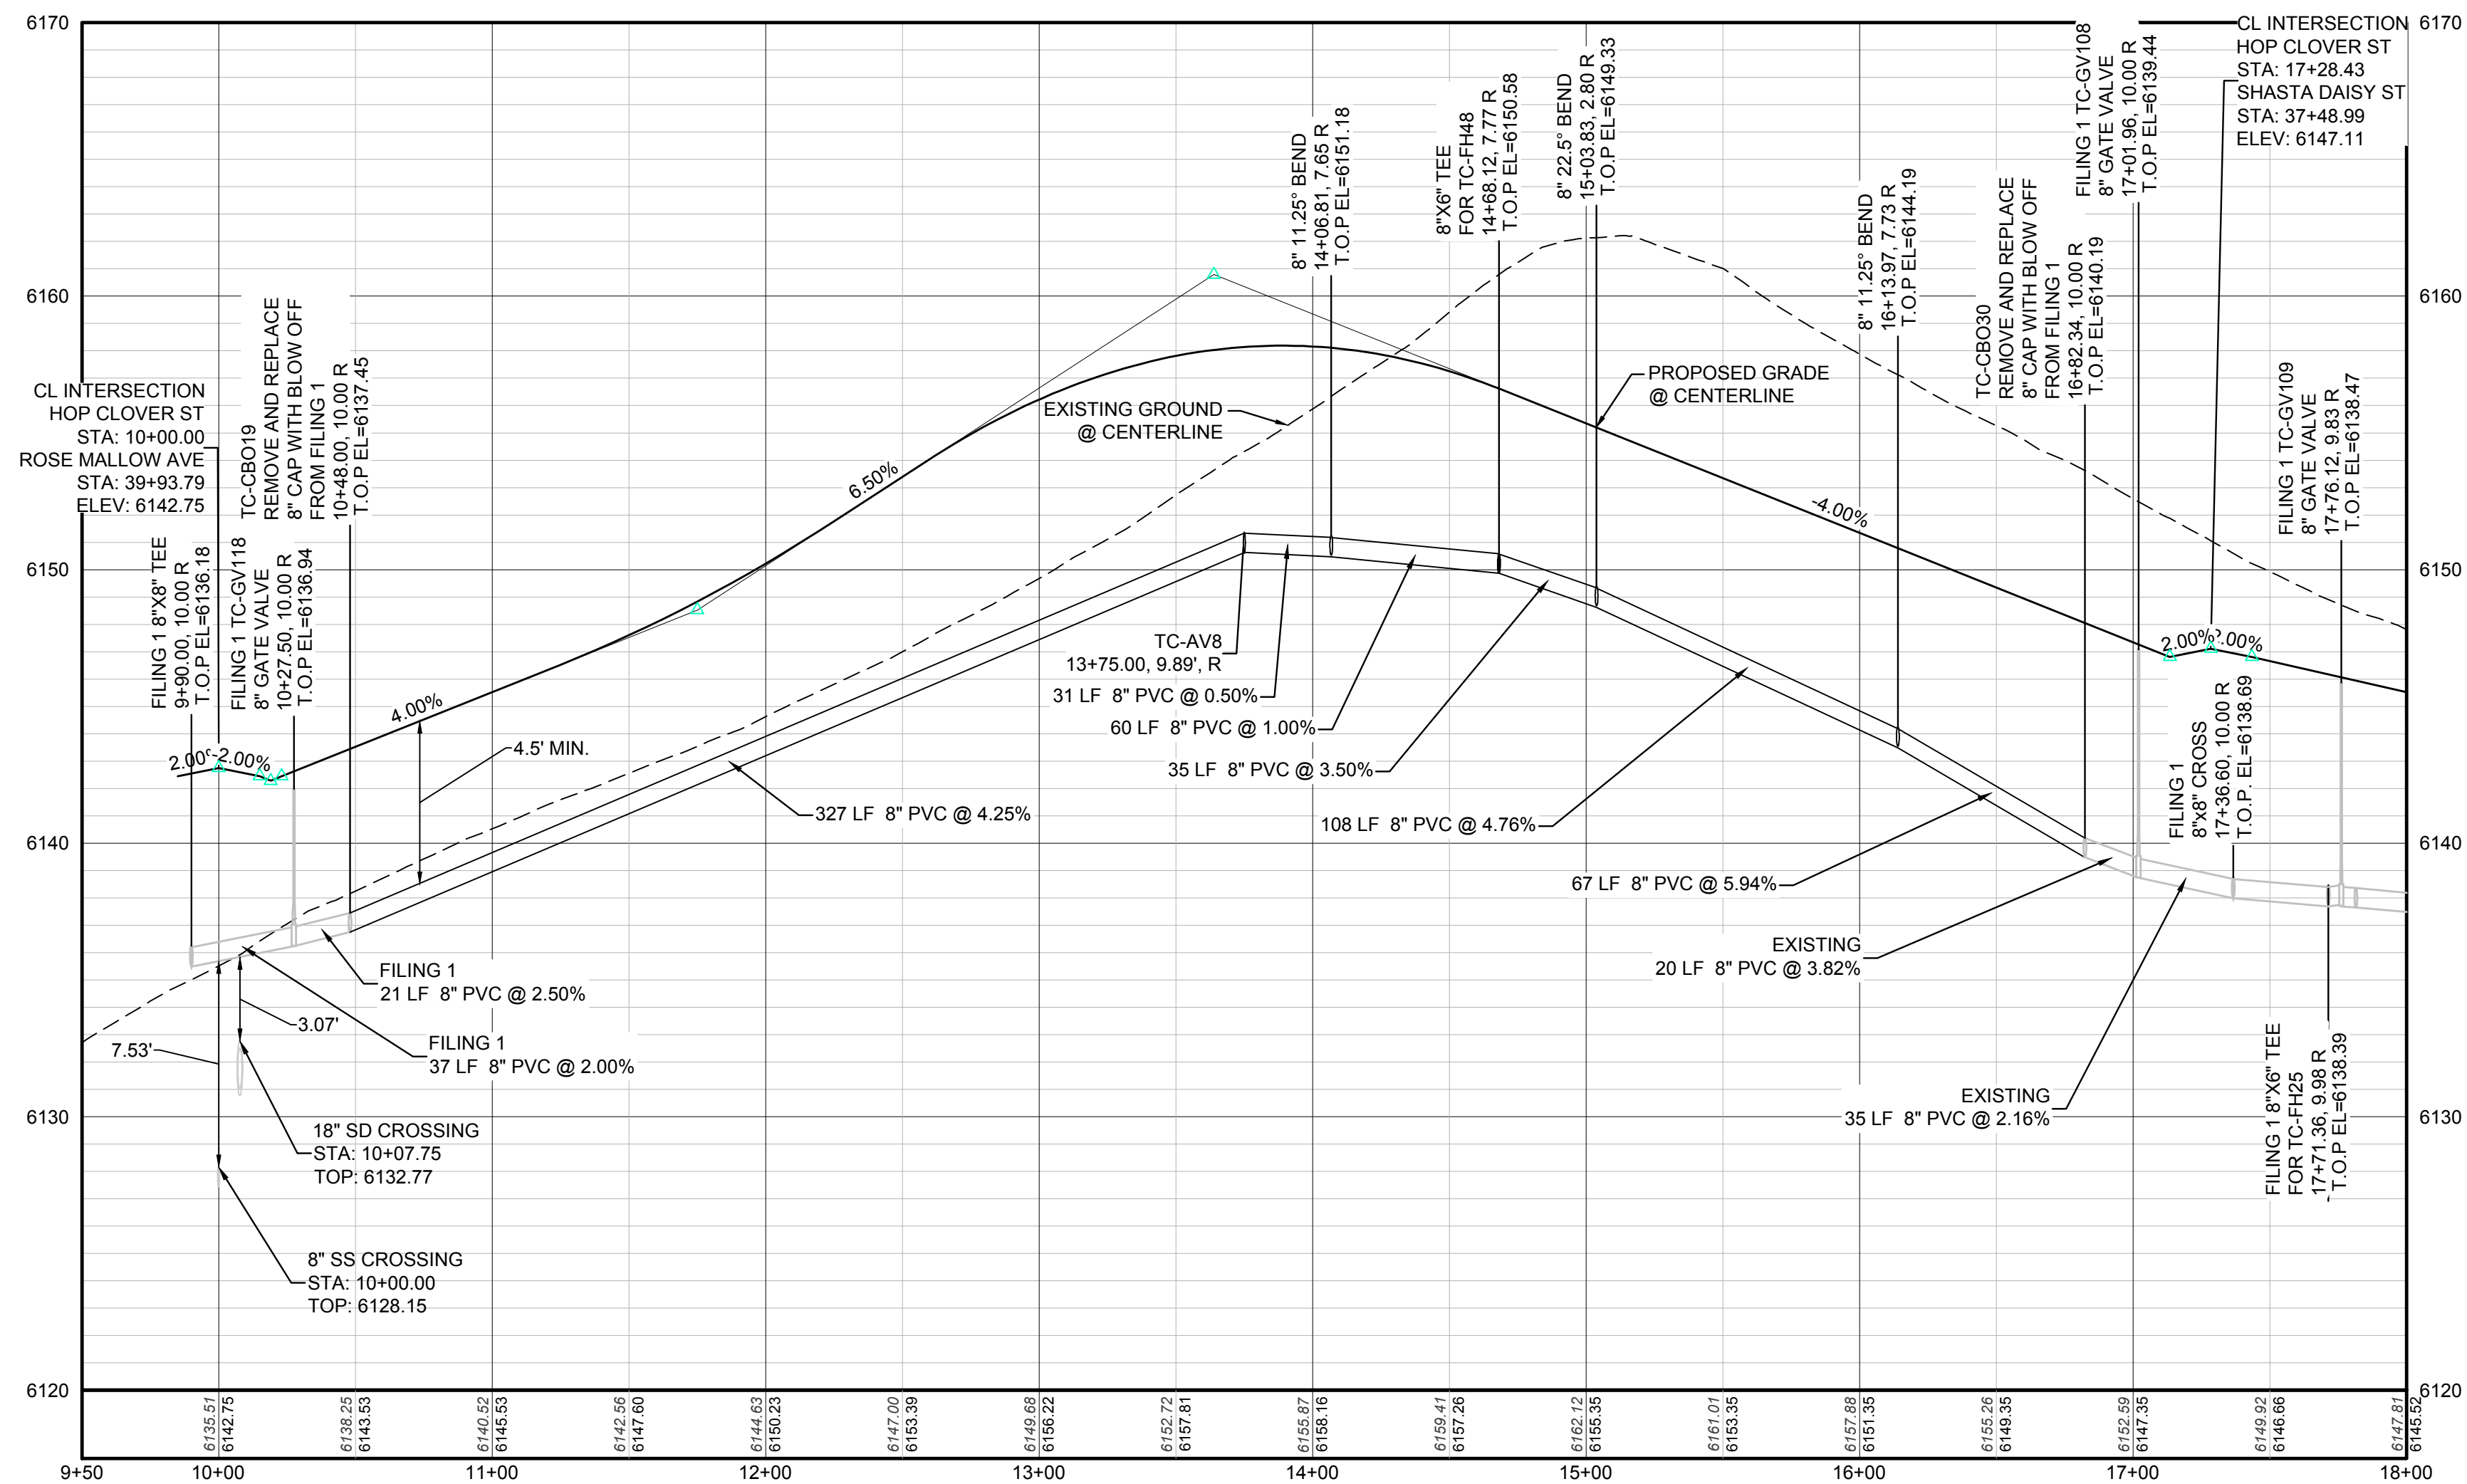


PROFILE: HOP CLOVER ST STA: 9+50.00 TO 18+00.00
HORIZONTAL SCALE: 1" = 50'
VERTICAL SCALE: 1" = 5'

BENCHMARK
DOUGLAS COUNTY CONTROL POINT KNOWN AS 1.060032, BEING A 3-1/4" ALUMINUM CAP, BEING LOCATED IN THE SOUTHWEST QUARTER OF SECTION 33, TOWNSHIP 6 SOUTH, RANGE 66 WEST OF THE SIXTH PRINCIPAL MERIDIAN, HAVING A PUBLISHED ELEVATION OF 1799.2870 METERS (5903.13 FEET) NAVD '88 DATUM.


BASIS OF BEARINGS:
THE EAST LINE OF THE NORTHEAST QUARTER OF SAID SECTION 9 BEING MONUMENTED AT THE NORTHEAST CORNER OF SAID SECTION 9 BY A 3-1/4" ALUMINUM CAP STAMPED LS 23053 AND AT THE EAST QUARTER CORNER OF SAID SECTION 9 BY A 2-1/2" ALUMINUM CAP STAMPED LS 6935 BEING CONSIDERED TO BEAR SOUTH 00°15'06" EAST, 2648.70 FEET.

PREPARED UNDER THE
SUPERVISION OF

BRIAN P. WILSON
COLORADO P.E. 00050067

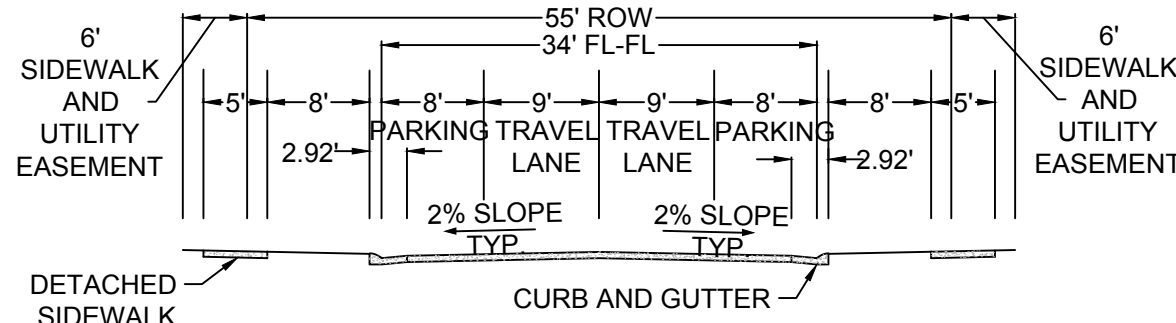

RESIDENTIAL LOCAL

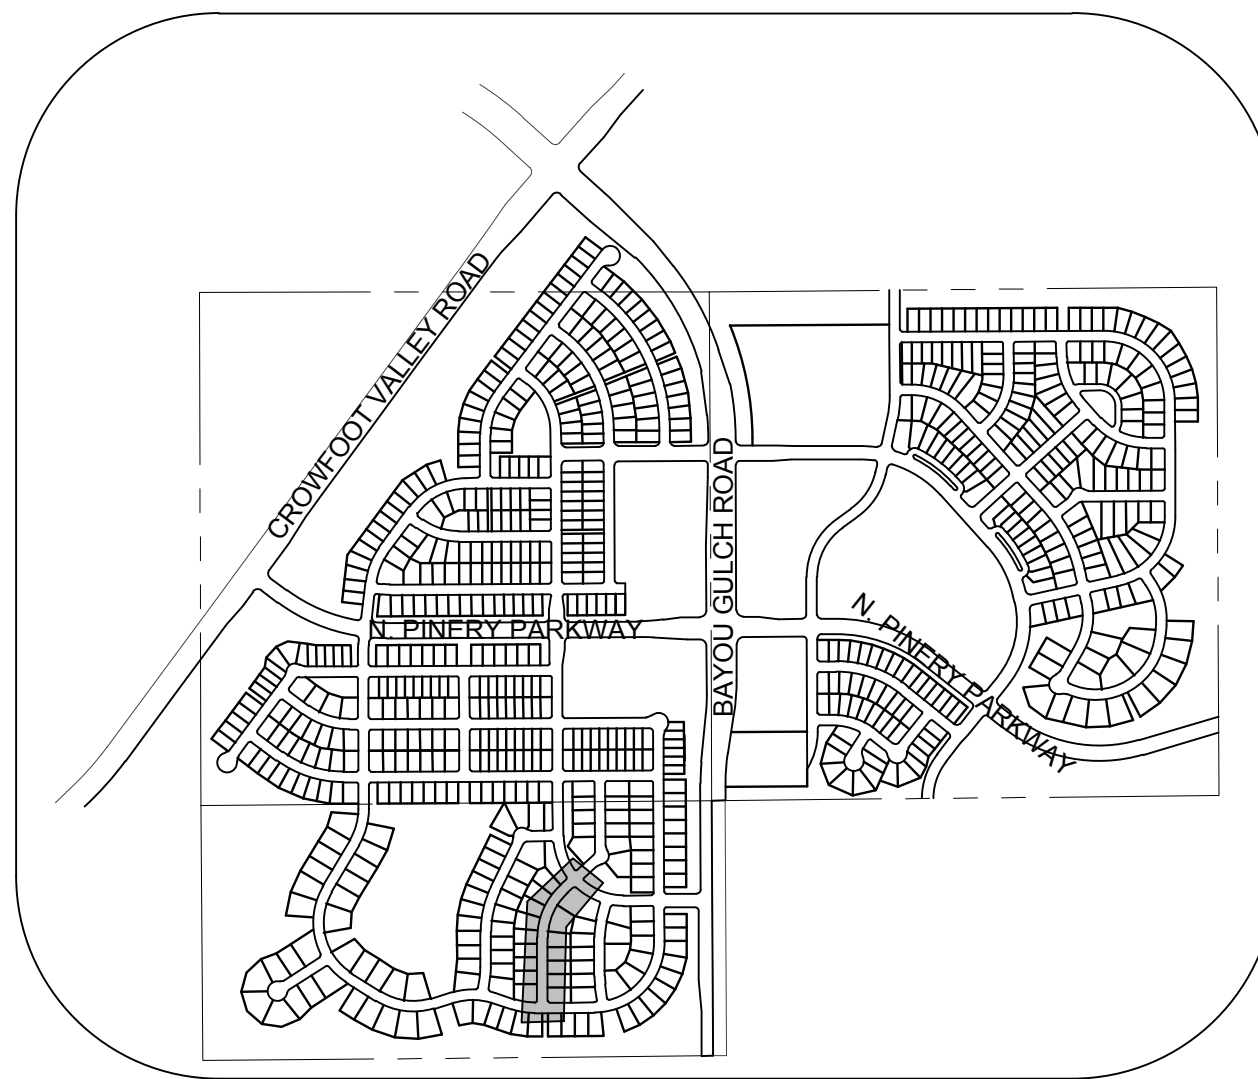


KEYMAP
N.T.S.
LEGEND

- | | | | |
|-------|---------------------------------------|------|----------------------------------|
| ② | BLOCK NUMBER | △ | PROPOSED RANGE POINT |
| Ⓐ | LOT TYPE | --- | CENTERLINE |
| 6 | LOT NUMBER | --- | RIGHT-OF-WAY |
| ⊗ | PROPOSED BUTTERFLY VALVE | --- | PROPERTY LINE |
| ⌈ | PROPOSED CAP WITH END OF LINE BLOWOFF | --- | EDGE OF PAVEMENT |
| ⌋ | PROPOSED REDUCER | → | PROPOSED DIRECTION OF FLOW |
| ⊗ | PROPOSED VALVE | 1.0% | PROPOSED SLOPE & DIRECTION |
| ⌚ | PROPOSED FIRE HYDRANT | 5615 | EXISTING 5' CONTOUR |
| ⌚ | PROPOSED WL FITTING WITH THRUST BLOCK | 5616 | EXISTING 1' CONTOUR |
| ⌚ | PROPOSED FLARED END SECTION | 5620 | PROPOSED 5' CONTOUR |
| ⊗ | PROPOSED LOW POINT BLOW-OFF | 5607 | PROPOSED 1' CONTOUR |
| ⊗ | PROPOSED AIR VALVE | --- | PROPOSED STORM DRAIN |
| ⊗ | FUTURE PHASE VALVE | --- | PROPOSED SEWER LINE WITH MANHOLE |
| ⊗ | FUTURE FIRE HYDRANT | --- | PROPOSED SEWER LATERAL |
| ⊗ | PROPOSED LIGHT POLE | --- | PROPOSED WATER LINE |
| ⊗ | PROPOSED SIDEWALK | --- | PROPOSED WATER LATERAL W/ METER |
| ⊗ | PROPOSED SIDEWALK RAMP | --- | SECTION LINE |
| 10.00 | EXISTING ELEVATION | --- | FILING BOUNDARY |
| 10.00 | PROPOSED DESIGN ELEVATION | --- | EXISTING FIBER OPTIC LINE |
| ⊗ | PROPOSED STORM DRAIN INLET | --- | EXISTING OVERHEAD POWER |
| ⊗ | PROPOSED STORM DRAIN MANHOLE | --- | EXISTING TELEPHONE LINE |

ABBREVIATIONS

- | | | | |
|-----|------------------------|--------|---------------------------------|
| AD | ANGLE DIFFERENCE | MH | MANHOLE |
| AV | AIR VAC RELEASE VALVE | N.T.S. | NOT TO SCALE |
| BVC | BEGIN VERTICAL CURVE | PVC | POLYVINYL CHLORIDE |
| BVP | BEGIN VERTICAL PROFILE | PVI | PT. OF VERTICAL INTERSECTION |
| CBO | CAP WITH BLOW OFF | PVT | POINT OF VERTICAL TANGENT |
| CRR | CURB RETURN RADIUS | RCBC | REINFORCED CONCRETE BOX CULVERT |
| EL | ELEVATION | RCP | REINFORCED CONCRETE PIPE |
| EP | EDGE OF PAVEMENT | ROW | RIGHT OF WAY |
| EVC | END VERTICAL CURVE | SC | SANITARY CAP |
| EVP | END VERTICAL PROFILE | SD | STORM DRAIN |
| FG | FINISHED GROUND | SL | SECTION LINE |
| FH | FIRE HYDRANT | SS | SANITARY SEWER |
| FL | FLOW LINE | STA | STATION |
| GV | GATE VALVE | T.O.P. | TOP OF PIPE |
| HCR | HANDICAP CURB RAMP | UE | UTILITY EASEMENT |
| HP | HIGH POINT | VC | VERTICAL CURVE |
| INV | INVERT | WL | WATER LINE |
| K | CURVATURE COEFFICIENT | WLC | WATER LINE CONNECTION |
| LF | LINEAR FEET | WSE | WATER SURFACE ELEVATION |

10333 E. Dry Creek Rd.
Suite 110
Englewood, CO 80110
Tel: (720) 482-9526
Fax: (720) 482-9546

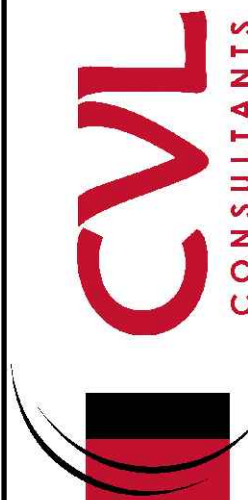

HR 935 LLC
7353 South Alton Way
CENTENNIAL, CO 80112

TRAILS AT CROWFOOT
FILING 7 CONSTRUCTION DRAWINGS
WATER PLAN & PROFILE
HOP CLOVER STREET

SCALE: AS SHOWN
DRAWN BY: RHR
CHECKED BY: JJ
FILE NO: 8130283701
DATE: AUGUST 2017

SHEET NUMBER
8

INSPECTION POLICY:

1. ALL SERVICE INSPECTIONS MUST BE SCHEDULED WITH THE DISTRICT OFFICE AT LEAST 24 HOURS IN ADVANCE OF THE REQUESTED INSPECTION.
2. IF THE CONTRACTOR IS NOT READY FOR INSPECTION WHEN THE INSPECTOR ARRIVES AT THE SITE, A RE-INSPECTION WILL HAVE TO BE SCHEDULED IN ACCORDANCE WITH NOTE 1 ABOVE AND A RE-INSPECTION FEE CHARGED.
3. SHOULD THE SERVICE LINES BE DAMAGED BY LATER CONSTRUCTION, AN INSPECTION OF THE REPAIR WILL BE REQUIRED IN ACCORDANCE WITH NOTES 1 AND 2 ABOVE.
4. THE CONTRACTOR SHALL LEAVE ALL PIPE AND FITTINGS EXPOSED FOR THE INSPECTOR TO OBSERVE. INSPECTORS WILL NOT ENTER ANY EXCAVATIONS TO CHECK MATERIALS. THE TOP LAYER OF BEDDING CAN BE ADDED AFTER THE INSPECTION HAS BEEN COMPLETED.
5. ALL EXCAVATIONS SHALL BE IN ACCORDANCE WITH OSHA STANDARDS.
6. LOTS WITHOUT BUILDING ADDRESSES OR LOT AND BLOCK NUMBERS BEFORE DISTRICT INSPECTION OR METER SET WILL FAIL AUTOMATICALLY.
7. CONTRACTOR MUST BE PRESENT AT TIME OF INSPECTION UNLESS COORDINATED WITH DISTRICT INSPECTOR.


INSTALLATION NOTES:

SEWER


1. ACCEPTABLE PIPE MATERIALS ARE TO BE SDR 35 PVC PIPE, ABS PIPE AND PVC SCHD 40 PIPE. APPROVED BEDDING IS TO BE SQUEEGEE.
2. NO-HUB CLAMPS SHALL BE USED TO JOIN 2 MALE PIPE ENDS WITH A MAXIMUM DEFLECTION OF 3'.
3. MINIMUM GRADE SHALL BE 2%.
4. INSTALLATION SHALL INCLUDE NO MORE THAN 3 BENDS. 90° BENDS ARE NOT ALLOWED. SOLVENT WELDED PIPE WILL NOT BE ALLOWED.
5. CLEAN-OUTS SHALL BE INSTALLED AT 100' INTERVALS AND EVERY CHANGE IN DIRECTION. CLEAN-OUTS ARE NOT REQUIRED FOR SERVICES LESS THAN 100' UNLESS THERE ARE CHANGES IN DIRECTION. PROVIDE DUAL CLEAN-OUT WITHIN 5 FEET OF FOUNDATION.
6. STRESSING OF THE PIPE BETWEEN FITTINGS WILL NOT BE ALLOWED.
7. SEWER SERVICE LINE SHALL NOT BE LOCATED UNDER CONCRETE SURFACE.
8. ALL SERVICES WILL BE PERMANENTLY MARKED ON CURB FACE AS FOLLOWS:
"X" FOR SANITARY SEWER SERVICE
"V" FOR WATER SERVICES

PARKER WATER & SANITATION DISTRICT			
DISTRICT POLICIES & INSTALLATION NOTES FOR SEWER SERVICES			
SCALE: NONE	DATE: 2/96		
APPROVED: PVR	01/02 01/08 1/16		
DIRECTOR OF ENGINEERING			

SHEET S1.1

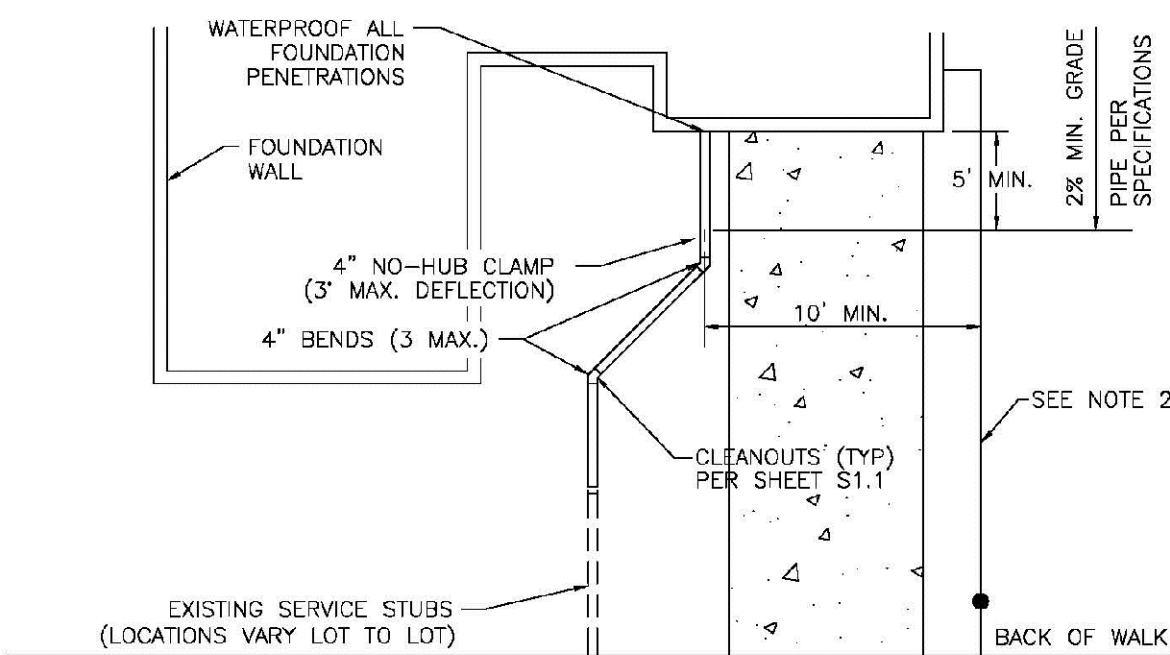

TYPICAL SERVICES PLAN VIEW

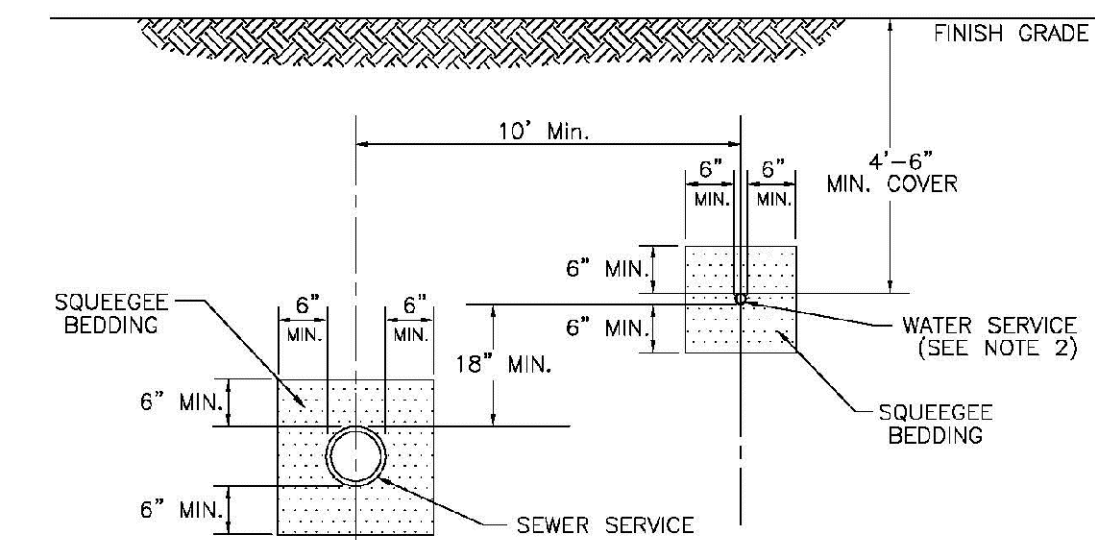


TYPICAL SERVICES SECTION

- NOTE:
1. SEE SHEET S1.1 FOR DISTRICT POLICIES AND INSTALLATION NOTES.
 2. TYPICAL WATER SERVICES SHOWN ON SHEET W1.2 IN WATER DETAILS.

PARKER WATER & SANITATION DISTRICT			
TYPICAL SEWER SERVICES			
SCALE: NONE	DATE: 2/96		
APPROVED: PVR	2/00 01/02 01/16 10/18		
DIRECTOR OF ENGINEERING			


SHEET S1.2

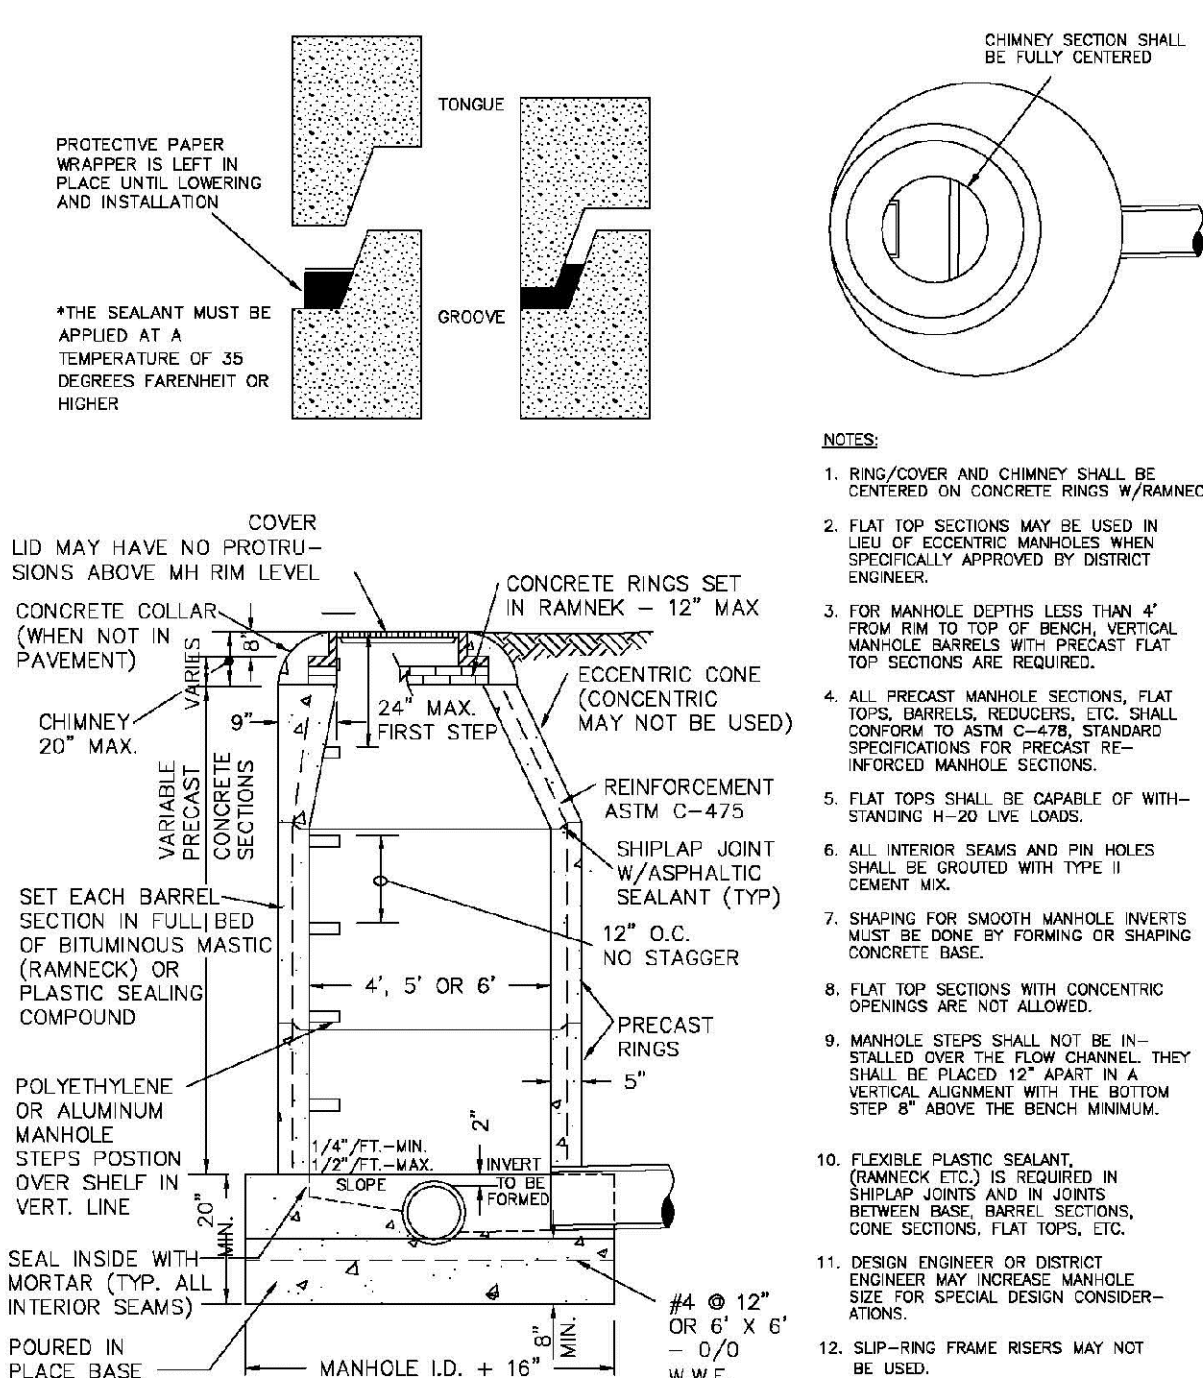

PARKER WATER & SANITATION DISTRICT
PARKER MANHOLE
ECCENTRIC CONE

SCALE: NONE	DATE: 2/96
APPROVED: PVR	4/01 01/02 1/08 1/16
DIRECTOR OF ENGINEERING	


SHEET S3.1

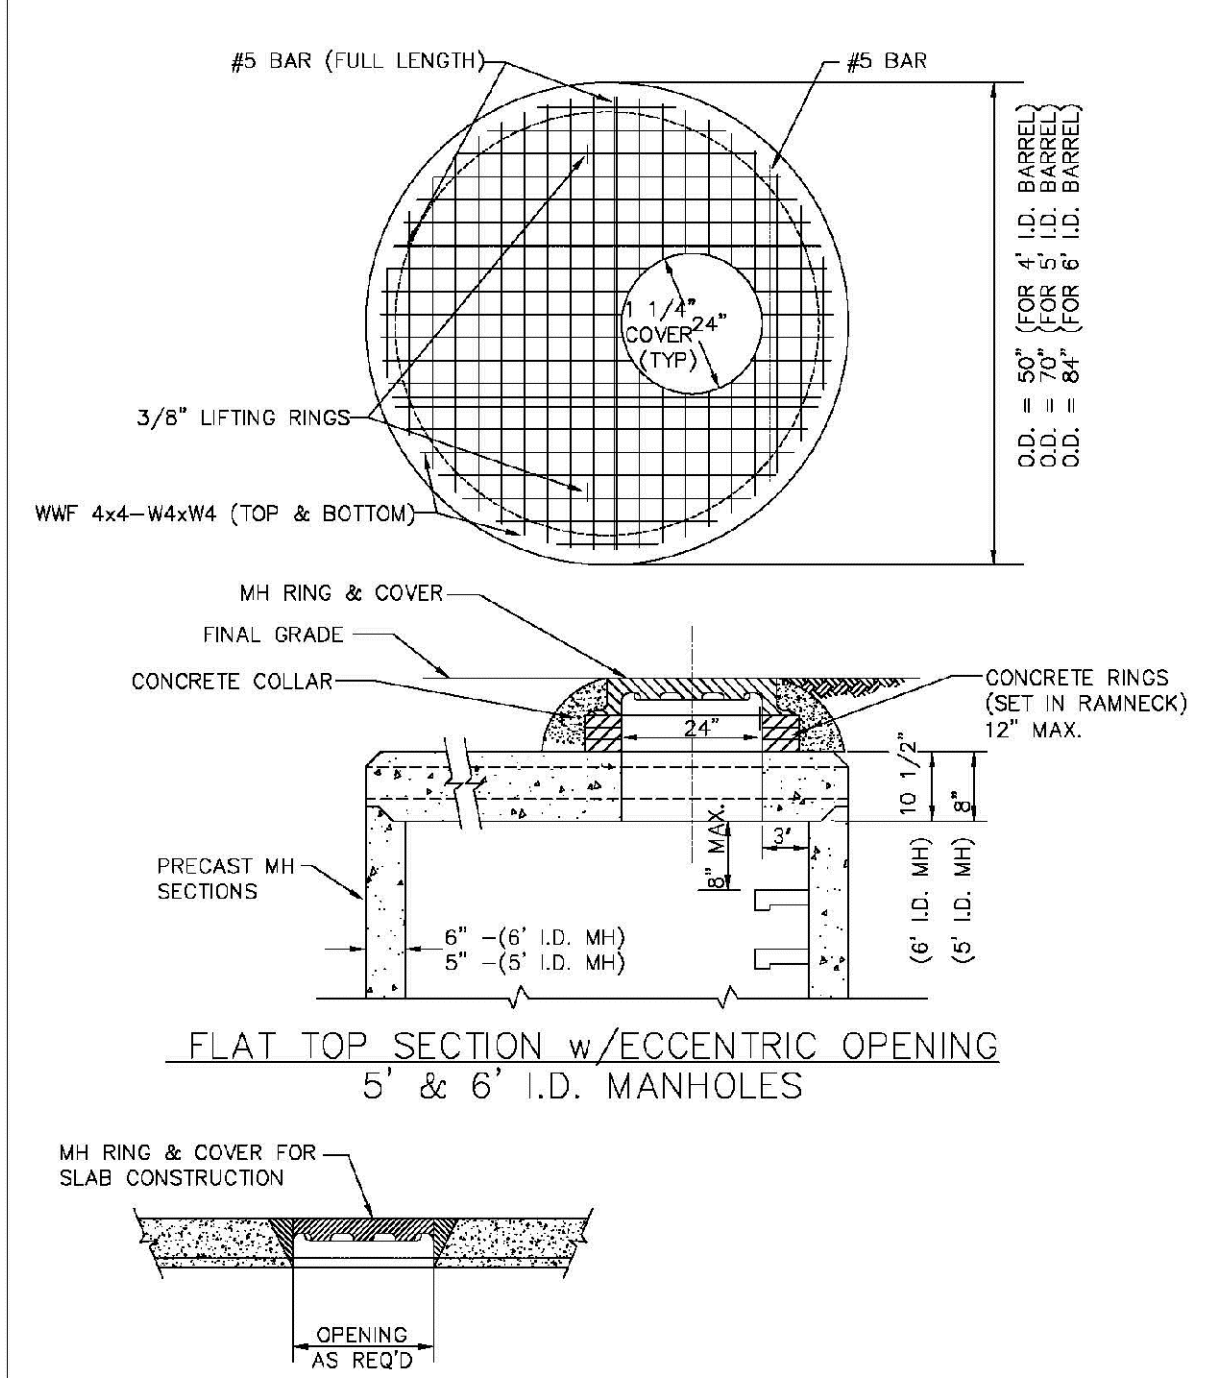

PARKER WATER & SANITATION DISTRICT
PRECAST MANHOLE - 5' & 6' I.D.
WITH ECCENTRIC CONE

SCALE: NONE	DATE: 2/96
APPROVED: PVR	01/02 01/16 10/16
DIRECTOR OF ENGINEERING	

SHEET S3.3

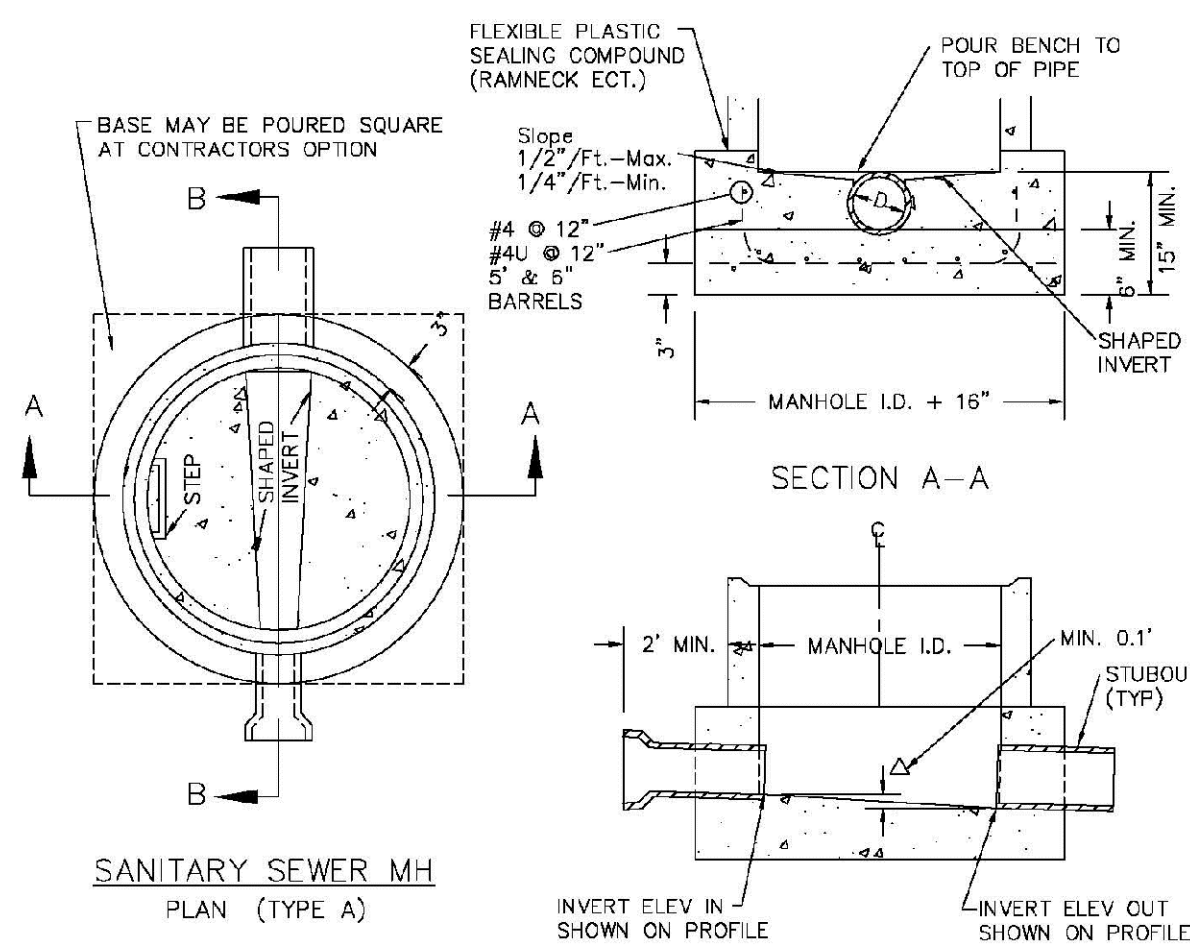


NOTES:

1. Manhole barrel min. thickness to be 5".
2. Shaping for smooth manhole inverts may be done by forming or shaping with cement mortar (San. Sewer).
3. The manhole steps shall conform to District Standards and Specifications.
4. Precast sections to conform to A.S.T.M. C-478.
5. All dead-end manholes, that call out a stub out, shall be thru at 0.40% minimum slope.
6. Stub outs shall extend 2'-0" minimum past manhole O.D. and be satisfactorily plugged.
7. Reinforcing in base required for manhole.
8. Slope of bench = 1/2"/FT.-Max. 1/4"/FT.-Min.
9. Δ = Invert drop thru MH (If Δ > 18", outside drop MH required). Min. 0.1" for all straight through MH and 0.2" for all angled MH.

PARKER WATER & SANITATION DISTRICT			
CAST-IN-PLACE MANHOLE BASE DETAIL			
SCALE: NONE	DATE: 2/96		
APPROVED: PVR	01/02 01/16 10/16		
DIRECTOR OF ENGINEERING			

SHEET S3.5

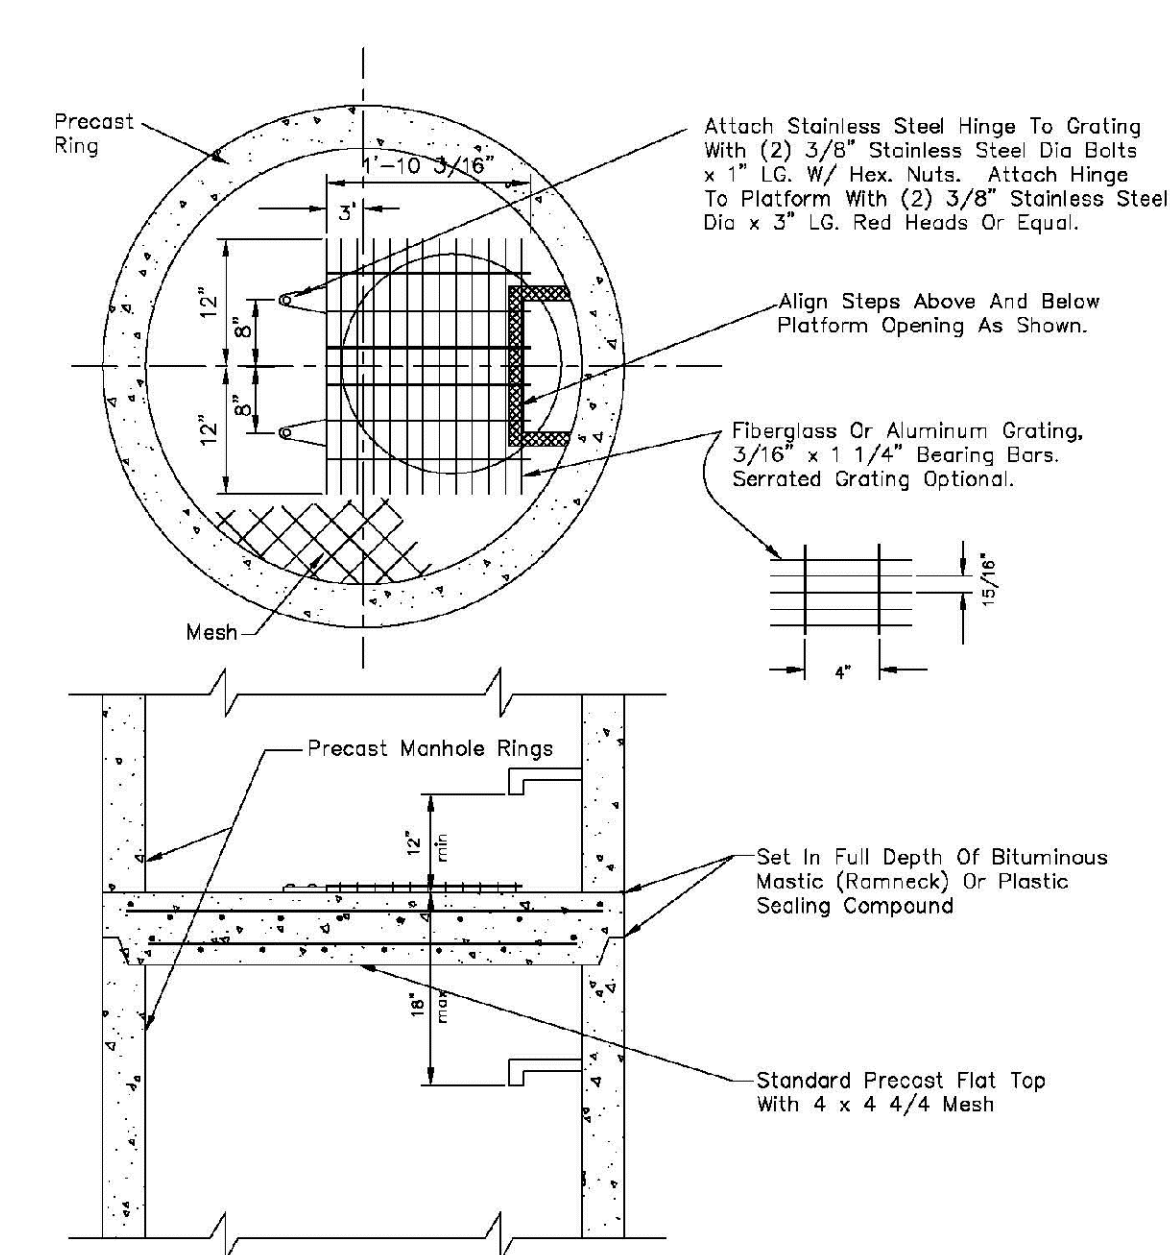


NOTES:

- 1.1 Maximum distance between platforms shall be 15' vertically.
- 1.2 All hardware used inside a manhole shall be stainless steel.
- 1.3 Manholes over 20' deep shall submit structural calculations on base and wall sizing.

PARKER WATER & SANITATION DISTRICT			
INTERMEDIATE PLATFORM FOR MANHOLES OVER 20' DEPTH			
SCALE: NONE	DATE: 2/96		
APPROVED: PVR	2/00 1/16 10/16		
DIRECTOR OF ENGINEERING			


SHEET S3.6

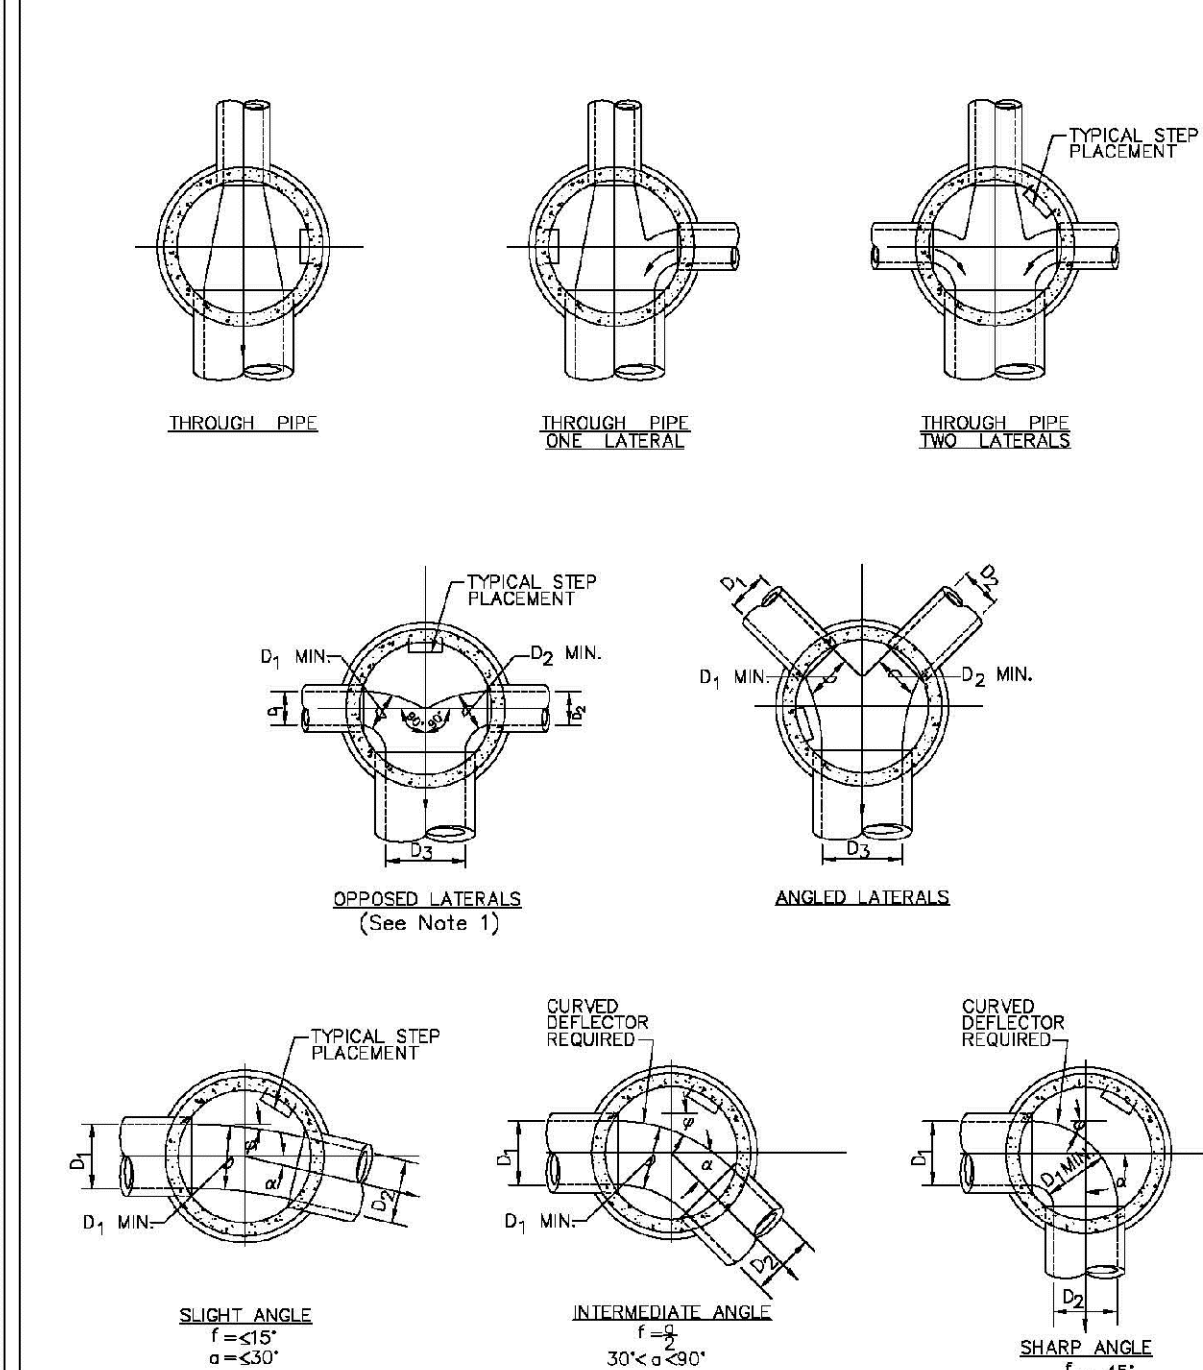

PARKER WATER & SANITATION DISTRICT
TYPICAL BASE
CHANNELIZATION DETAILS

SCALE: NONE	DATE: 2/96
APPROVED: PVR	01/16 10/16
DIRECTOR OF ENGINEERING	

SHEET S3.7

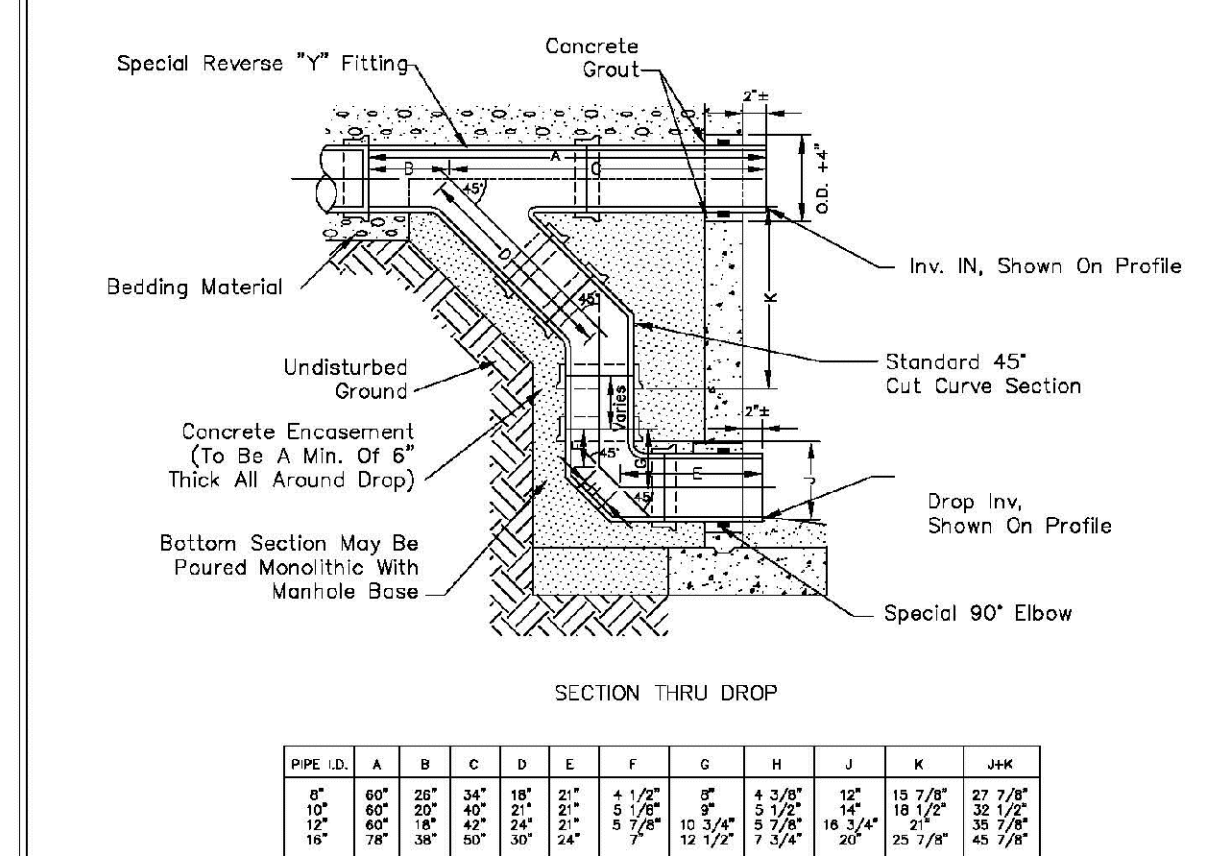


NOTES:

1. Vlt Clay Pipe & fittings (A.S.T.M. C-700) shown, details similar for all other pipe.
2. Diameter of drop shall not be less than the line pipe diameter.
3. For 18" diameter and larger, outside drop detail shall be a special design.
4. Manhole shall be coated using bituminous mastic (ramneck) or plastic sealing compound.

PARKER WATER & SANITATION DISTRICT
OUTSIDE DROP MANHOLE
CONSTRUCTION

SCALE: NONE	DATE: 2/96
APPROVED: PVR	01/16 10/16
DIRECTOR OF ENGINEERING	

SHEET S3.8

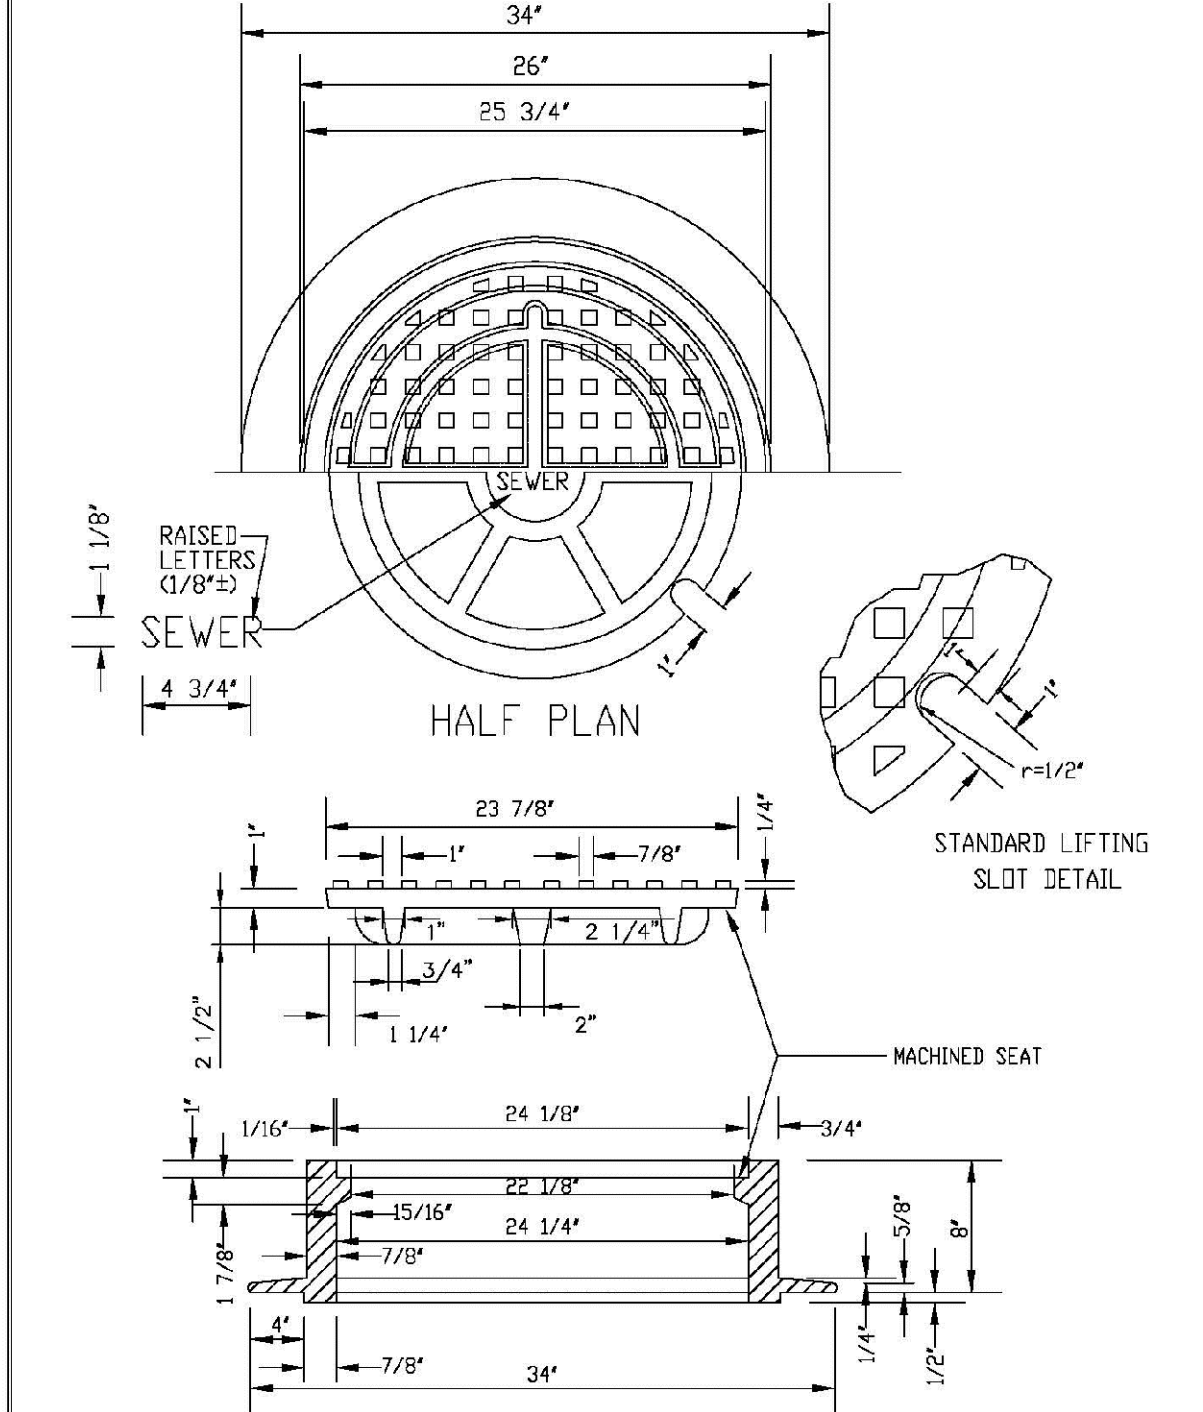











NOTE:


1. Casting Specifications: ASTM A-48 With A Minimum Tensile Strength Of 25 KSI (Class 25)
2. All Casting To Be Dipped in Asphalt Base Paint (Or Approved Equal).
3. No other manhole lids will be accepted without prior approval from the District Engineer.

PARKER WATER & SANITATION DISTRICT
24" DIAMETER RING
AND COVER

SCALE: NONE	DATE: 2/96
APPROVED: PVR	01/16 10/16
DIRECTOR OF ENGINEERING	

SHEET S3.9

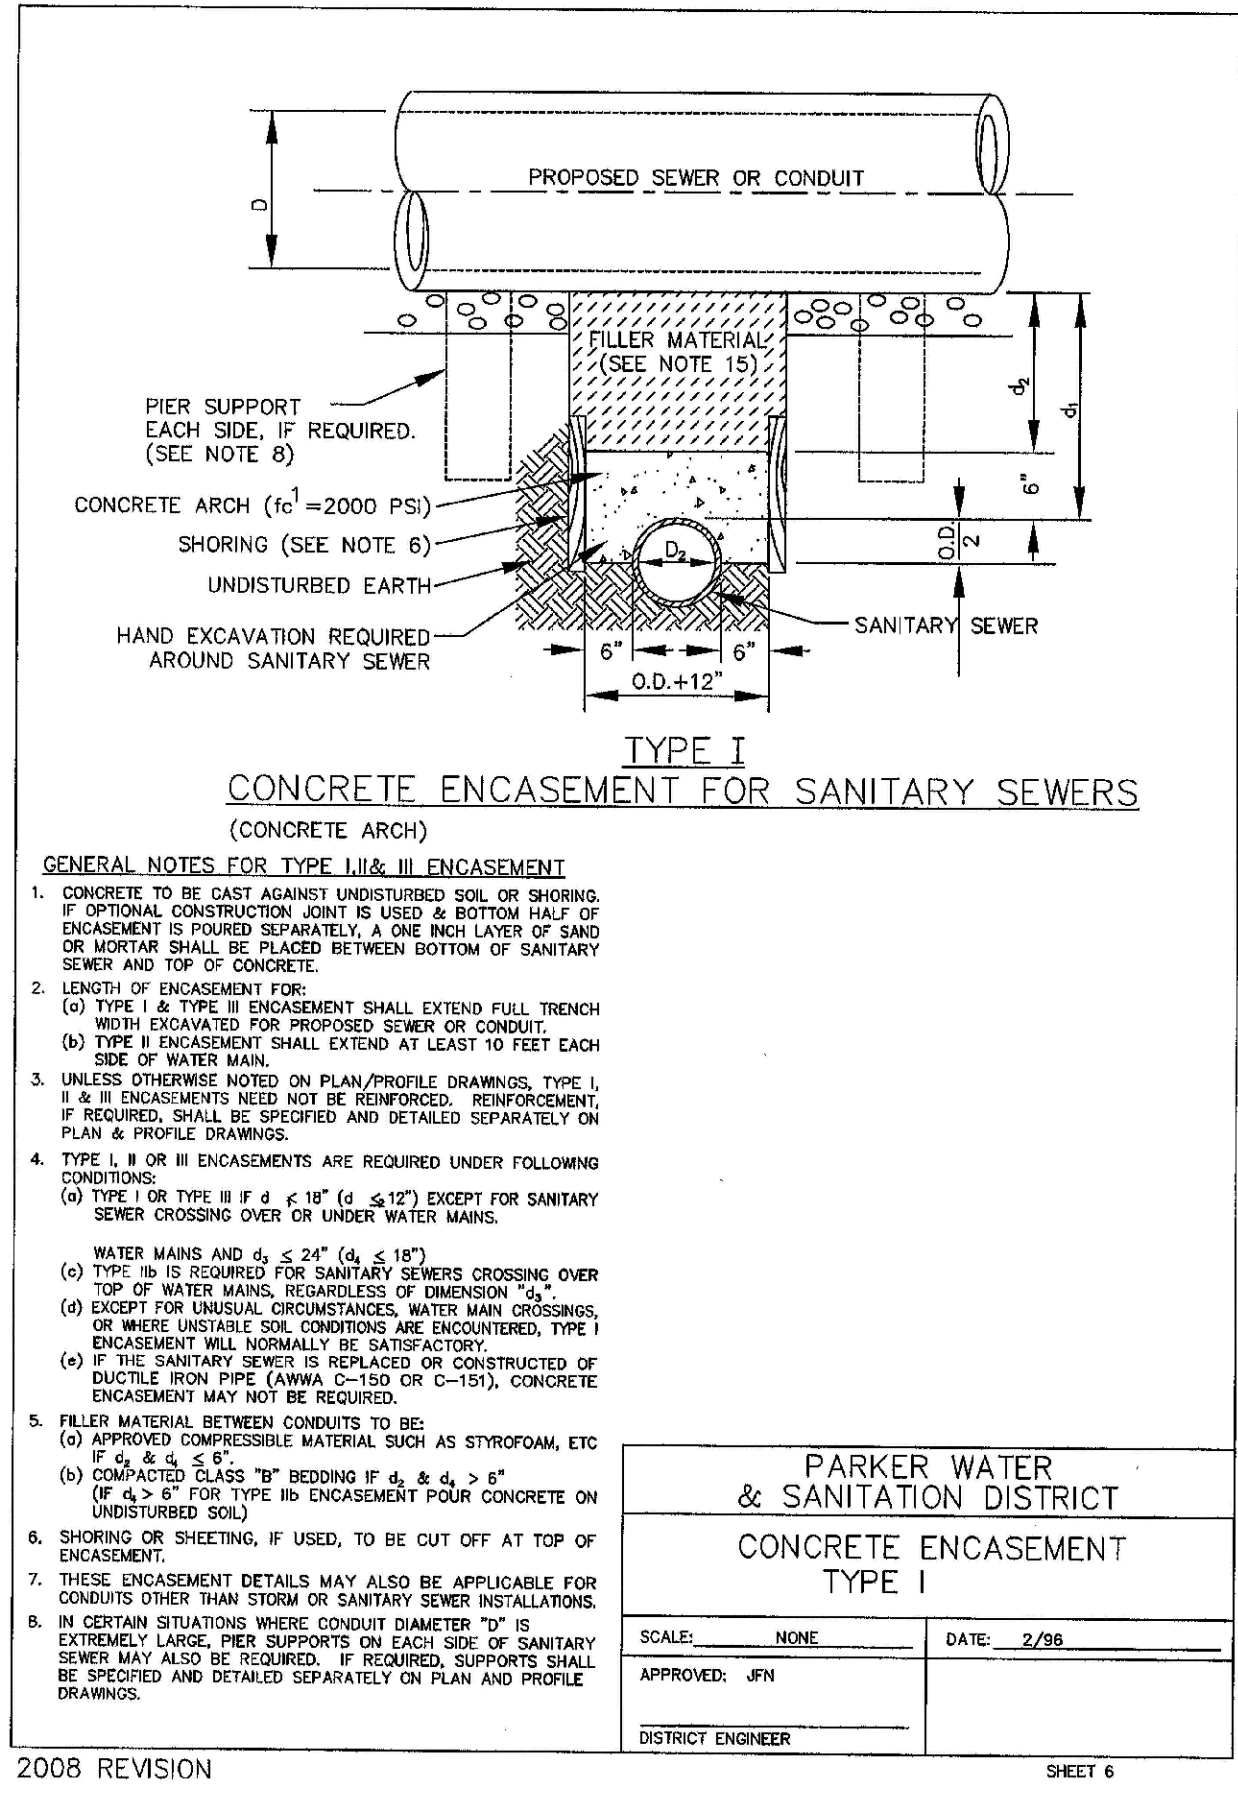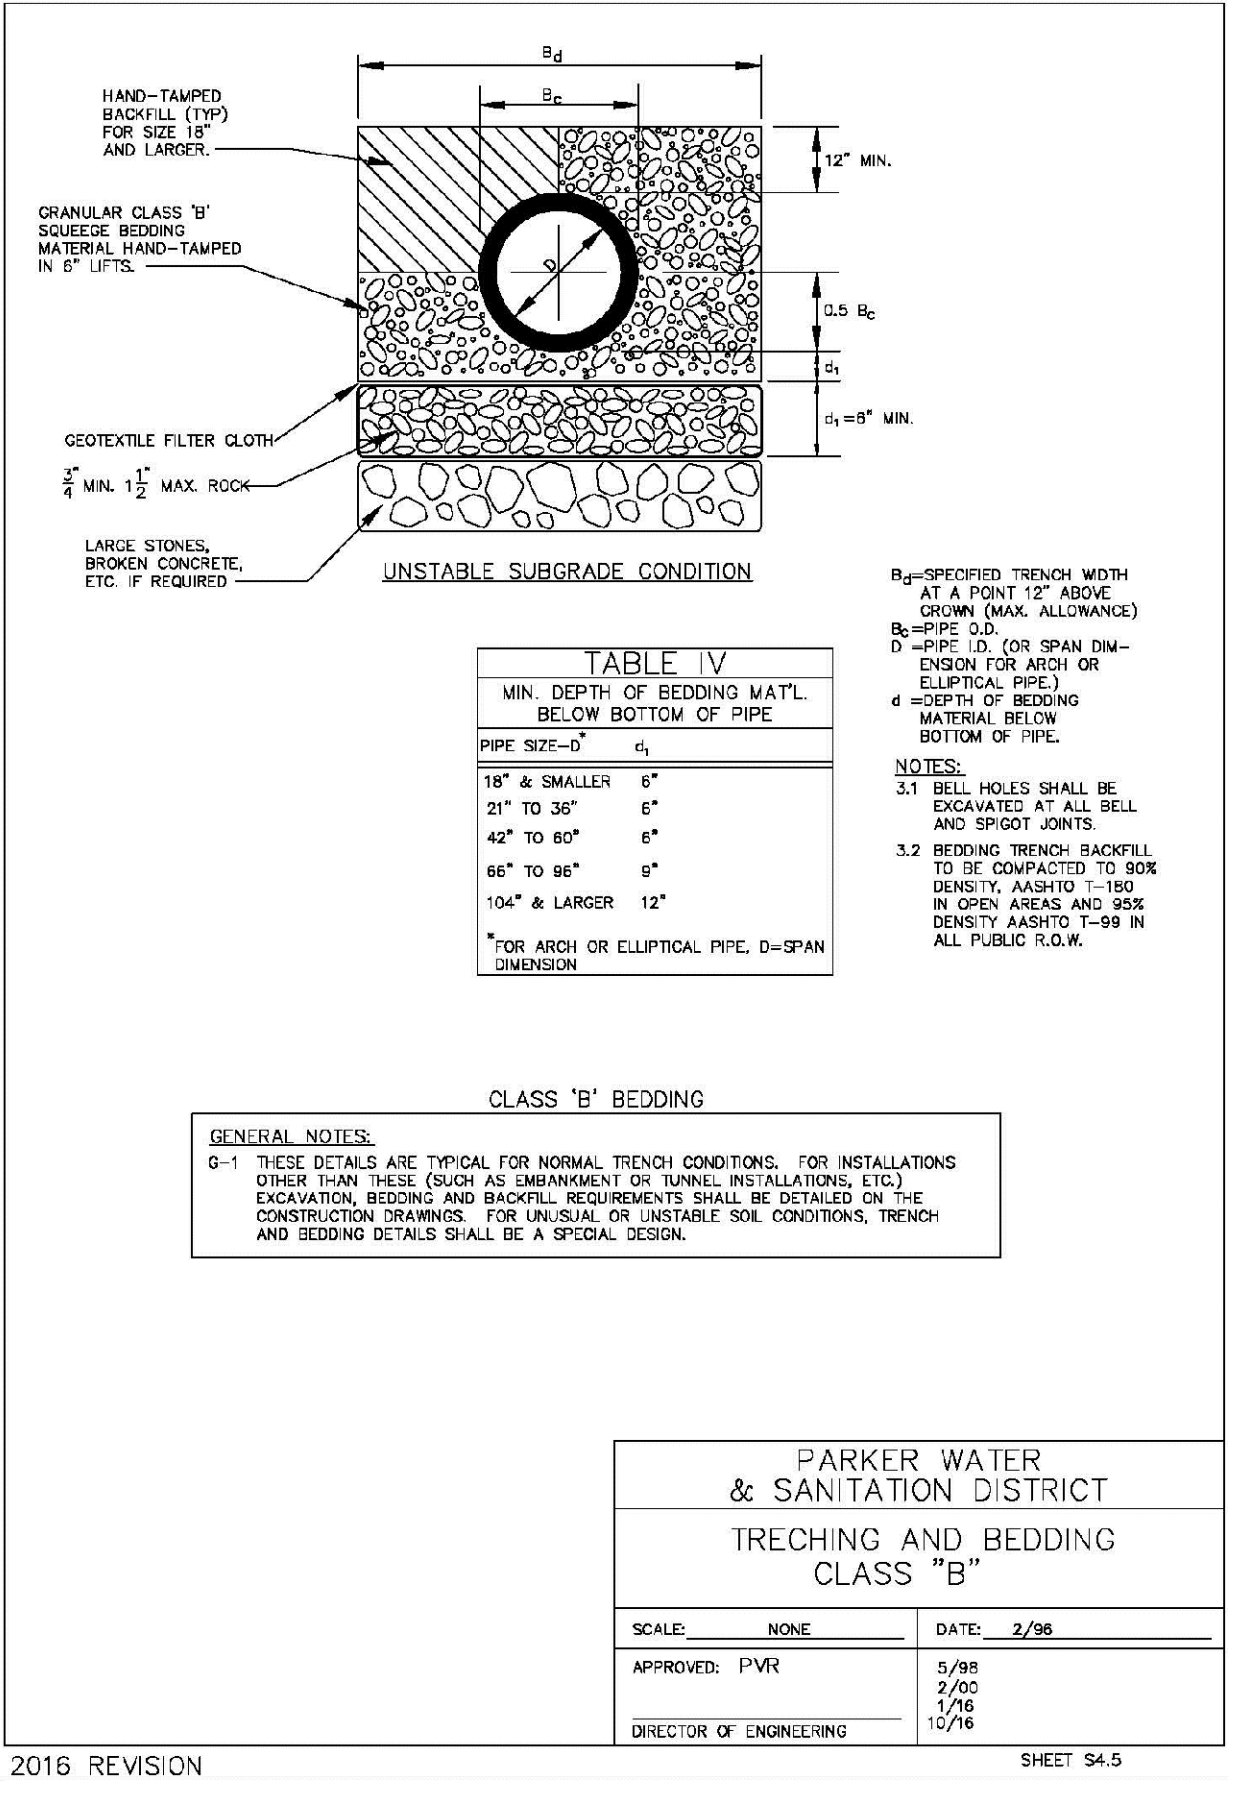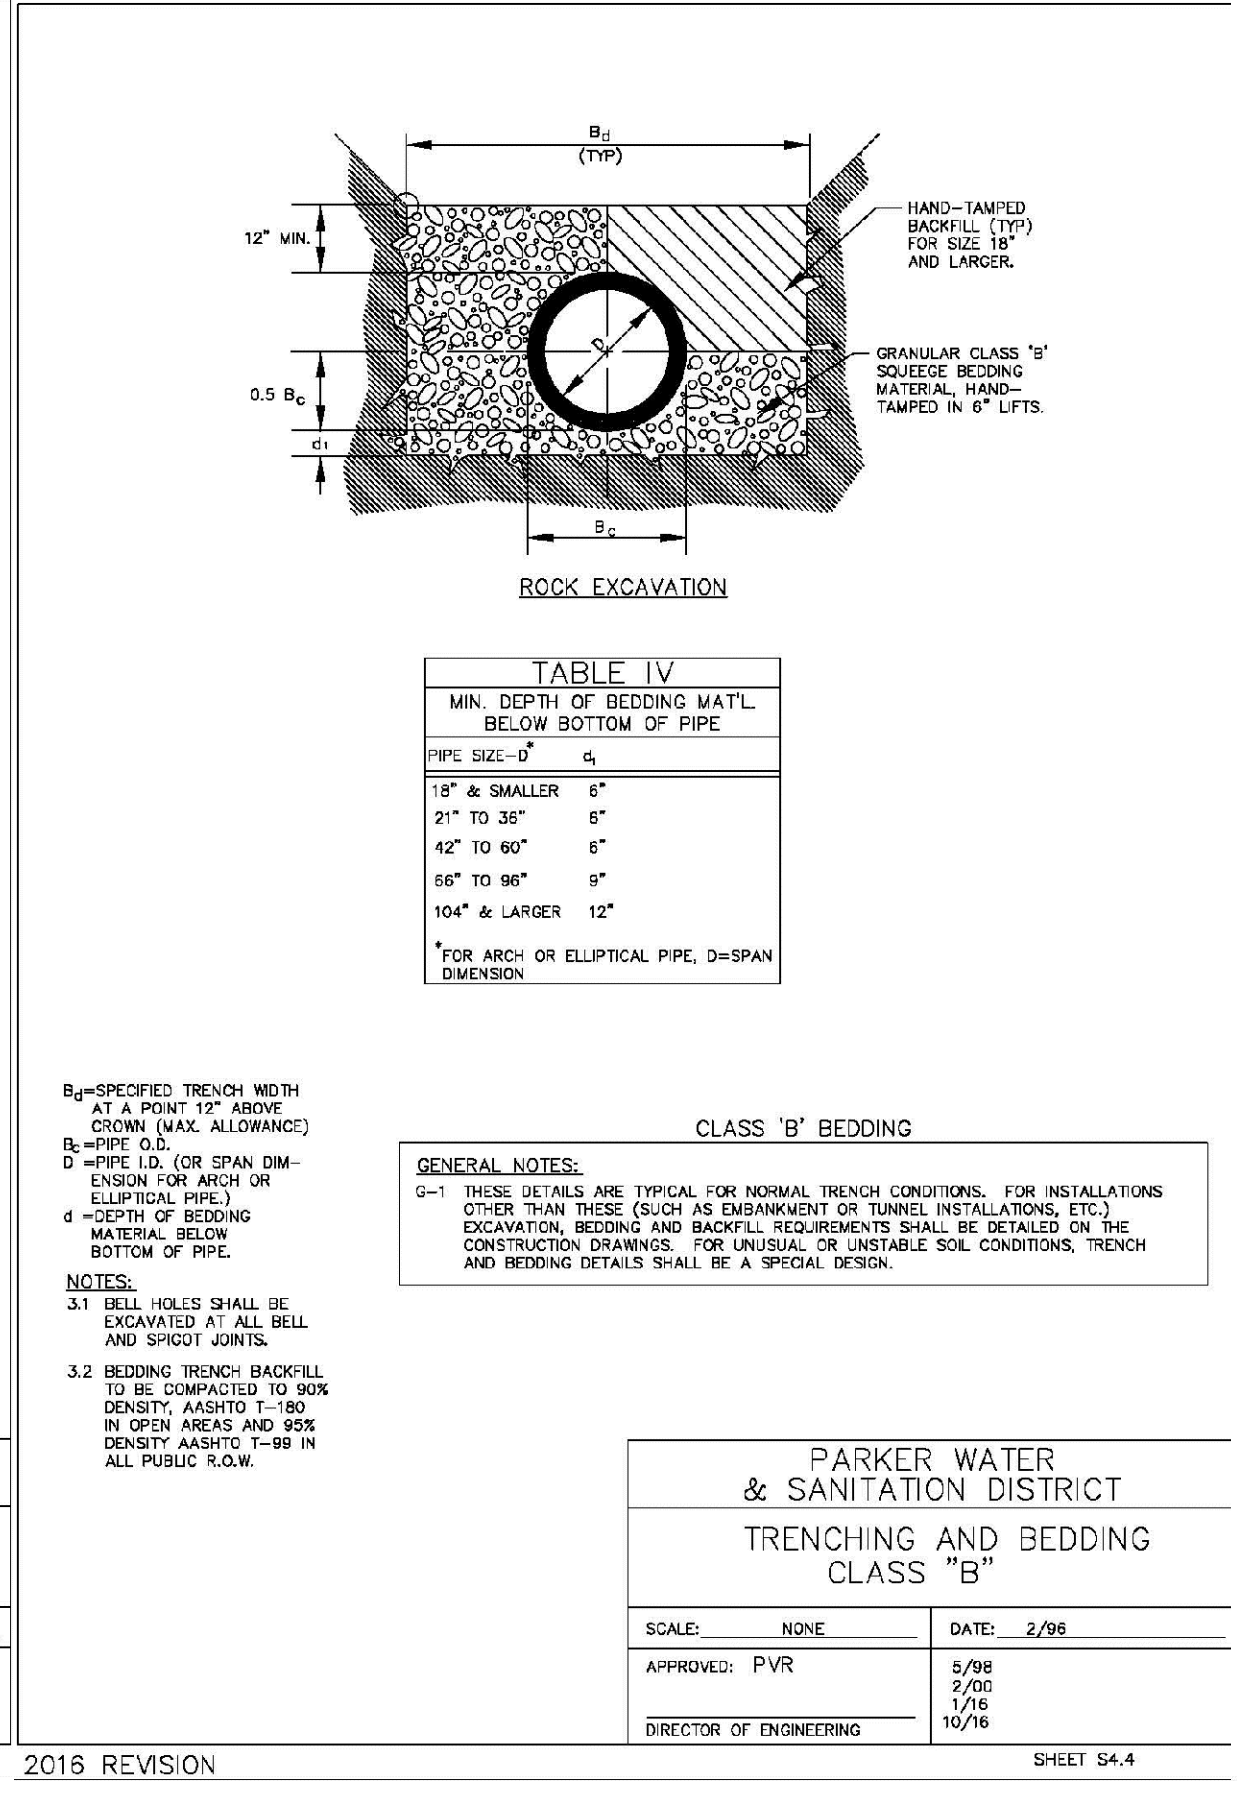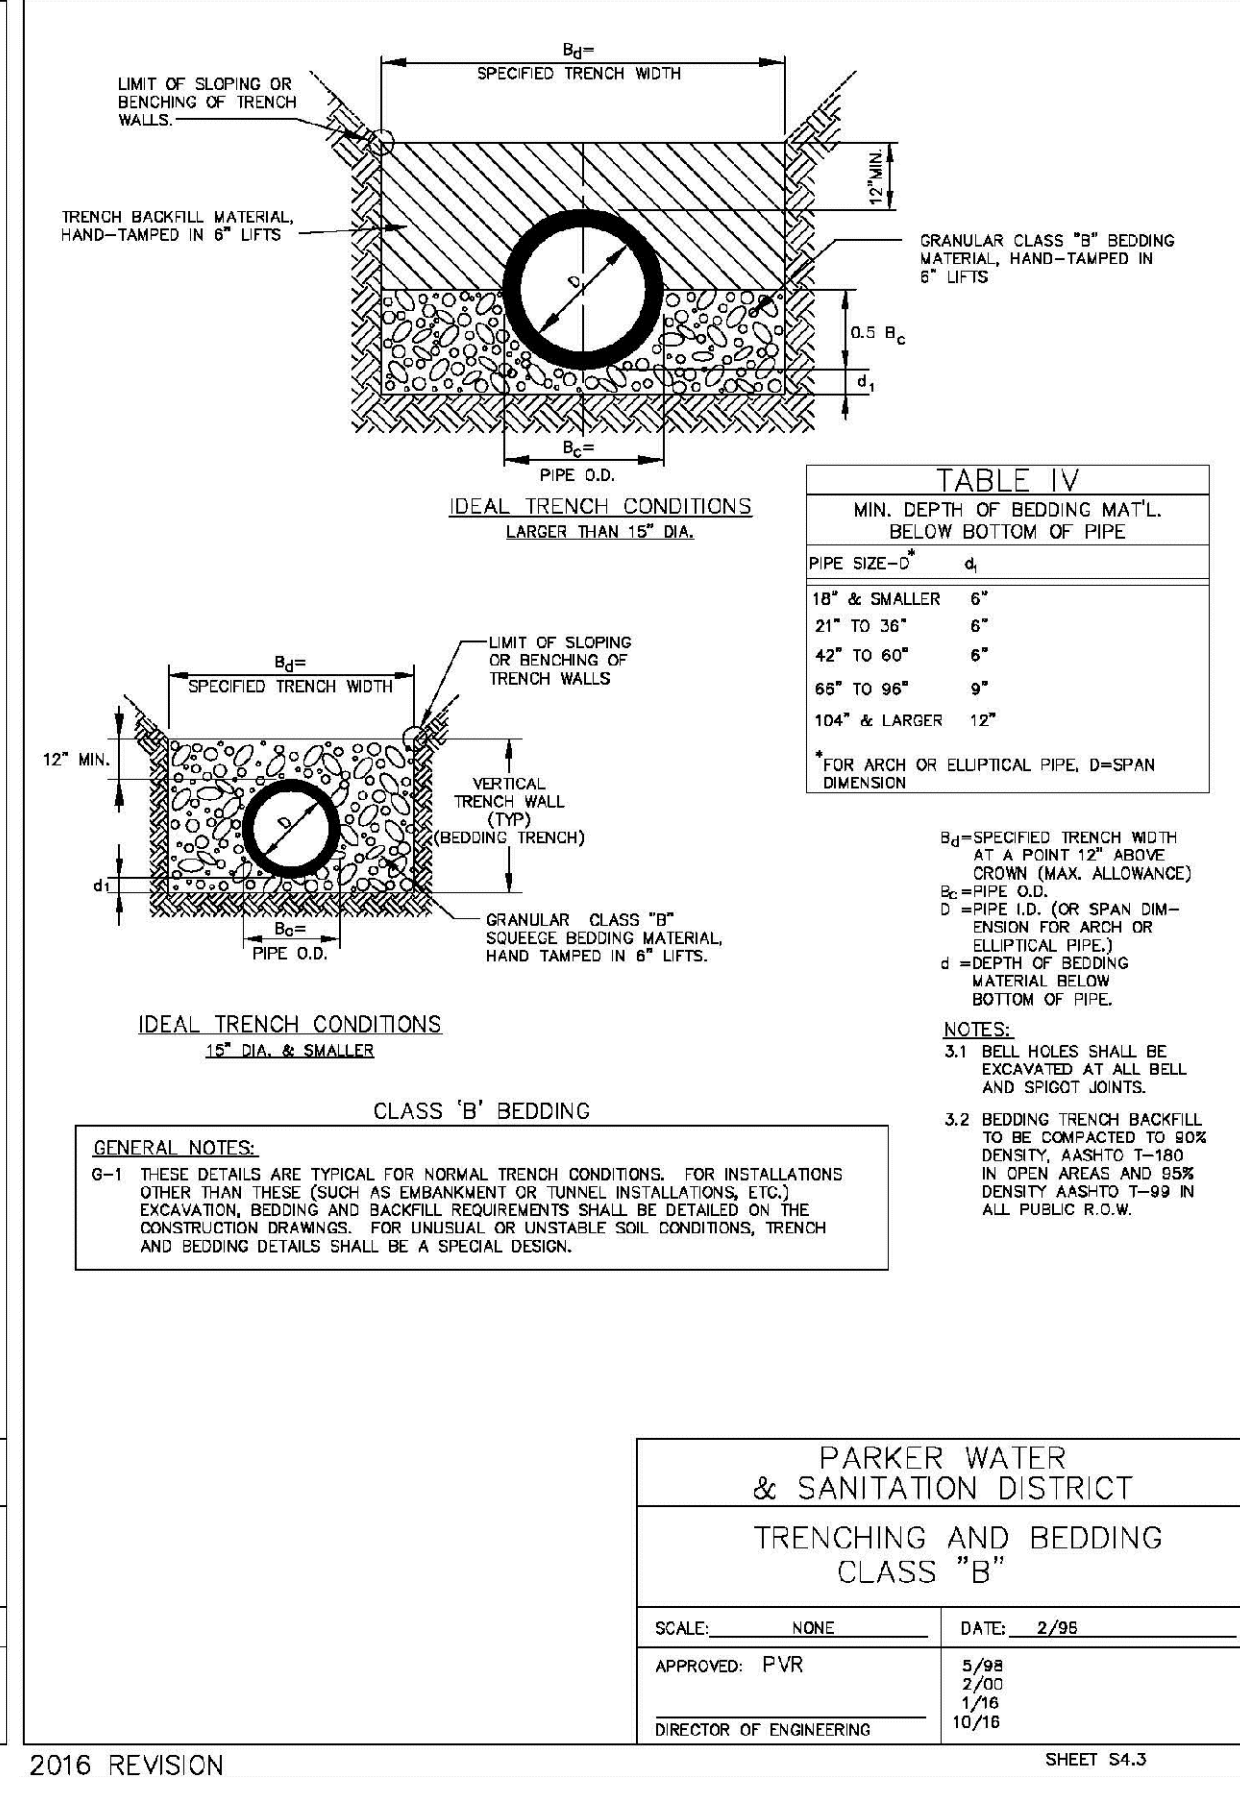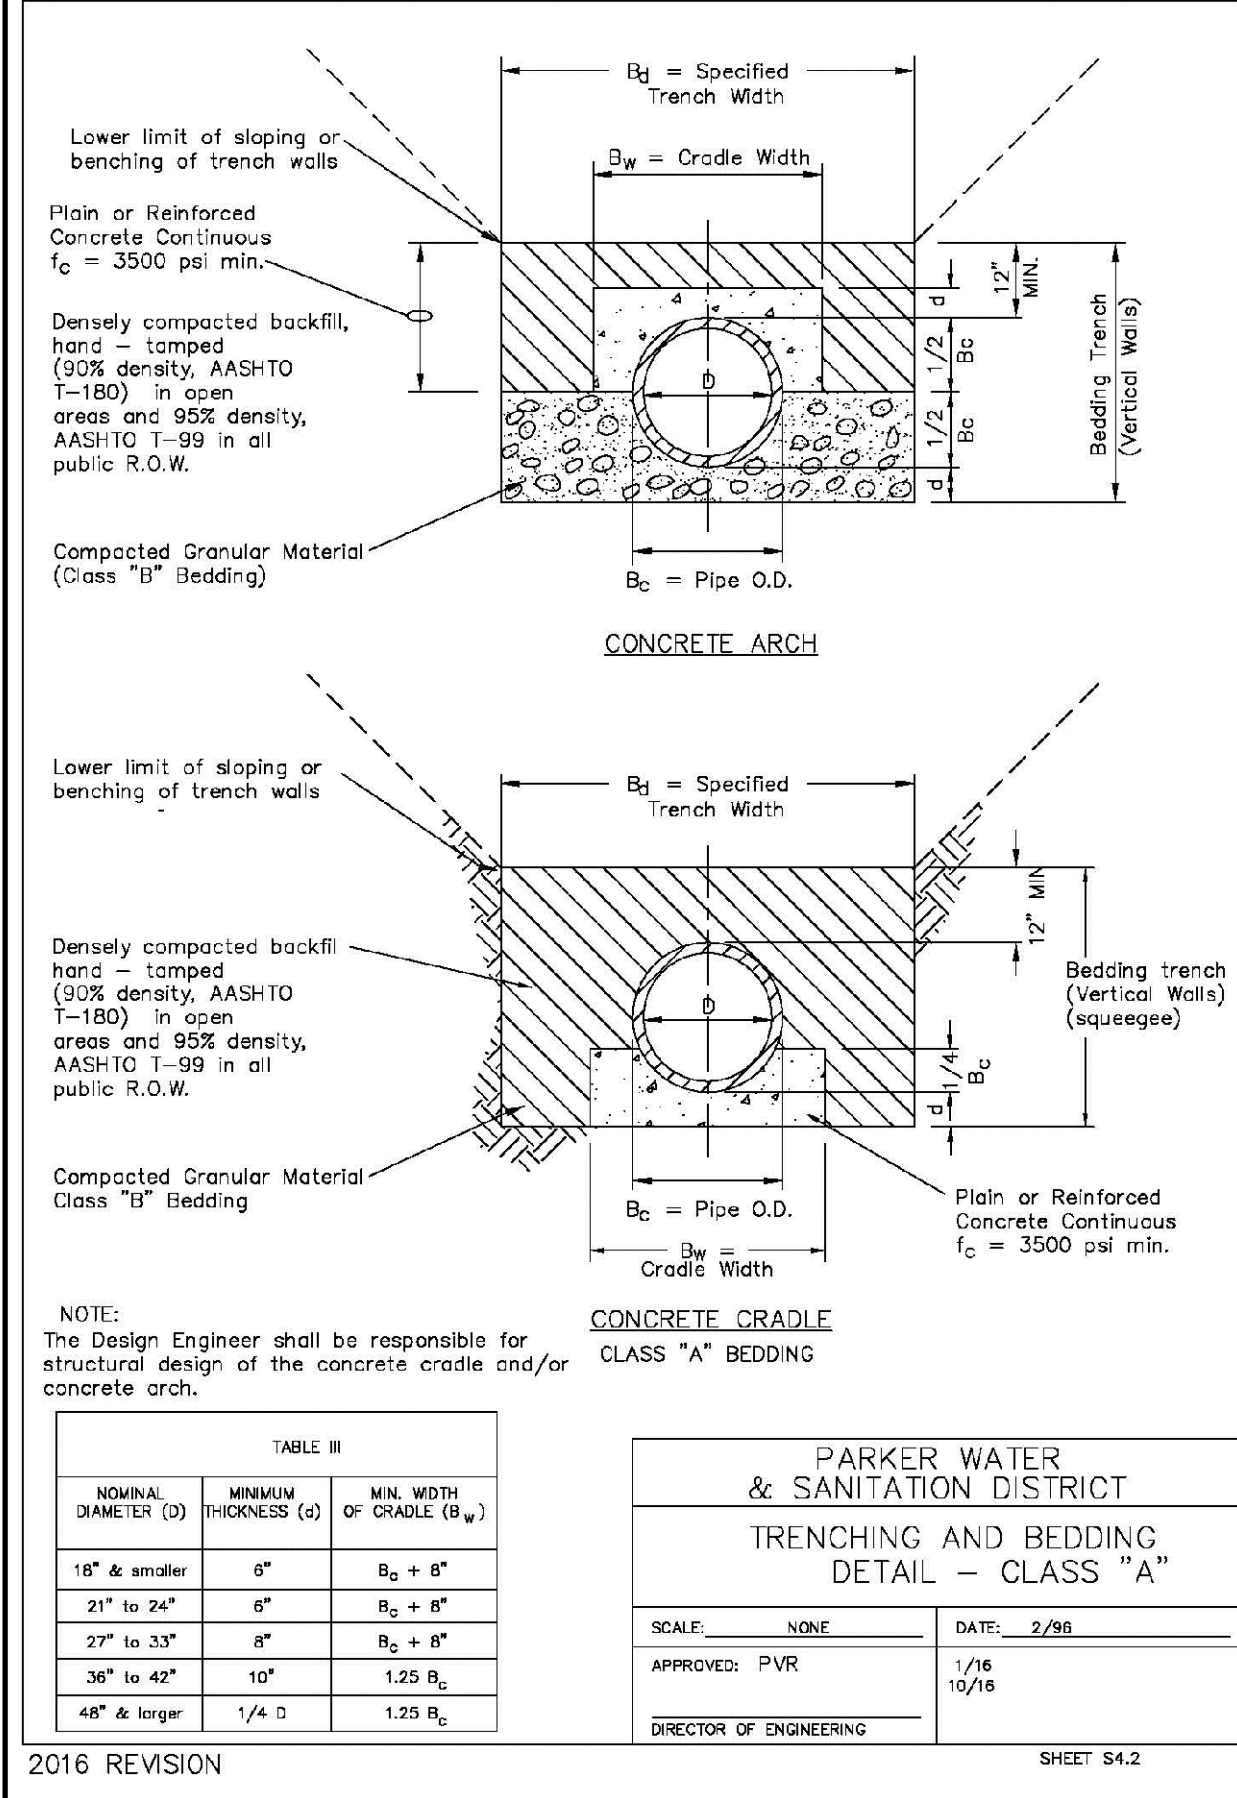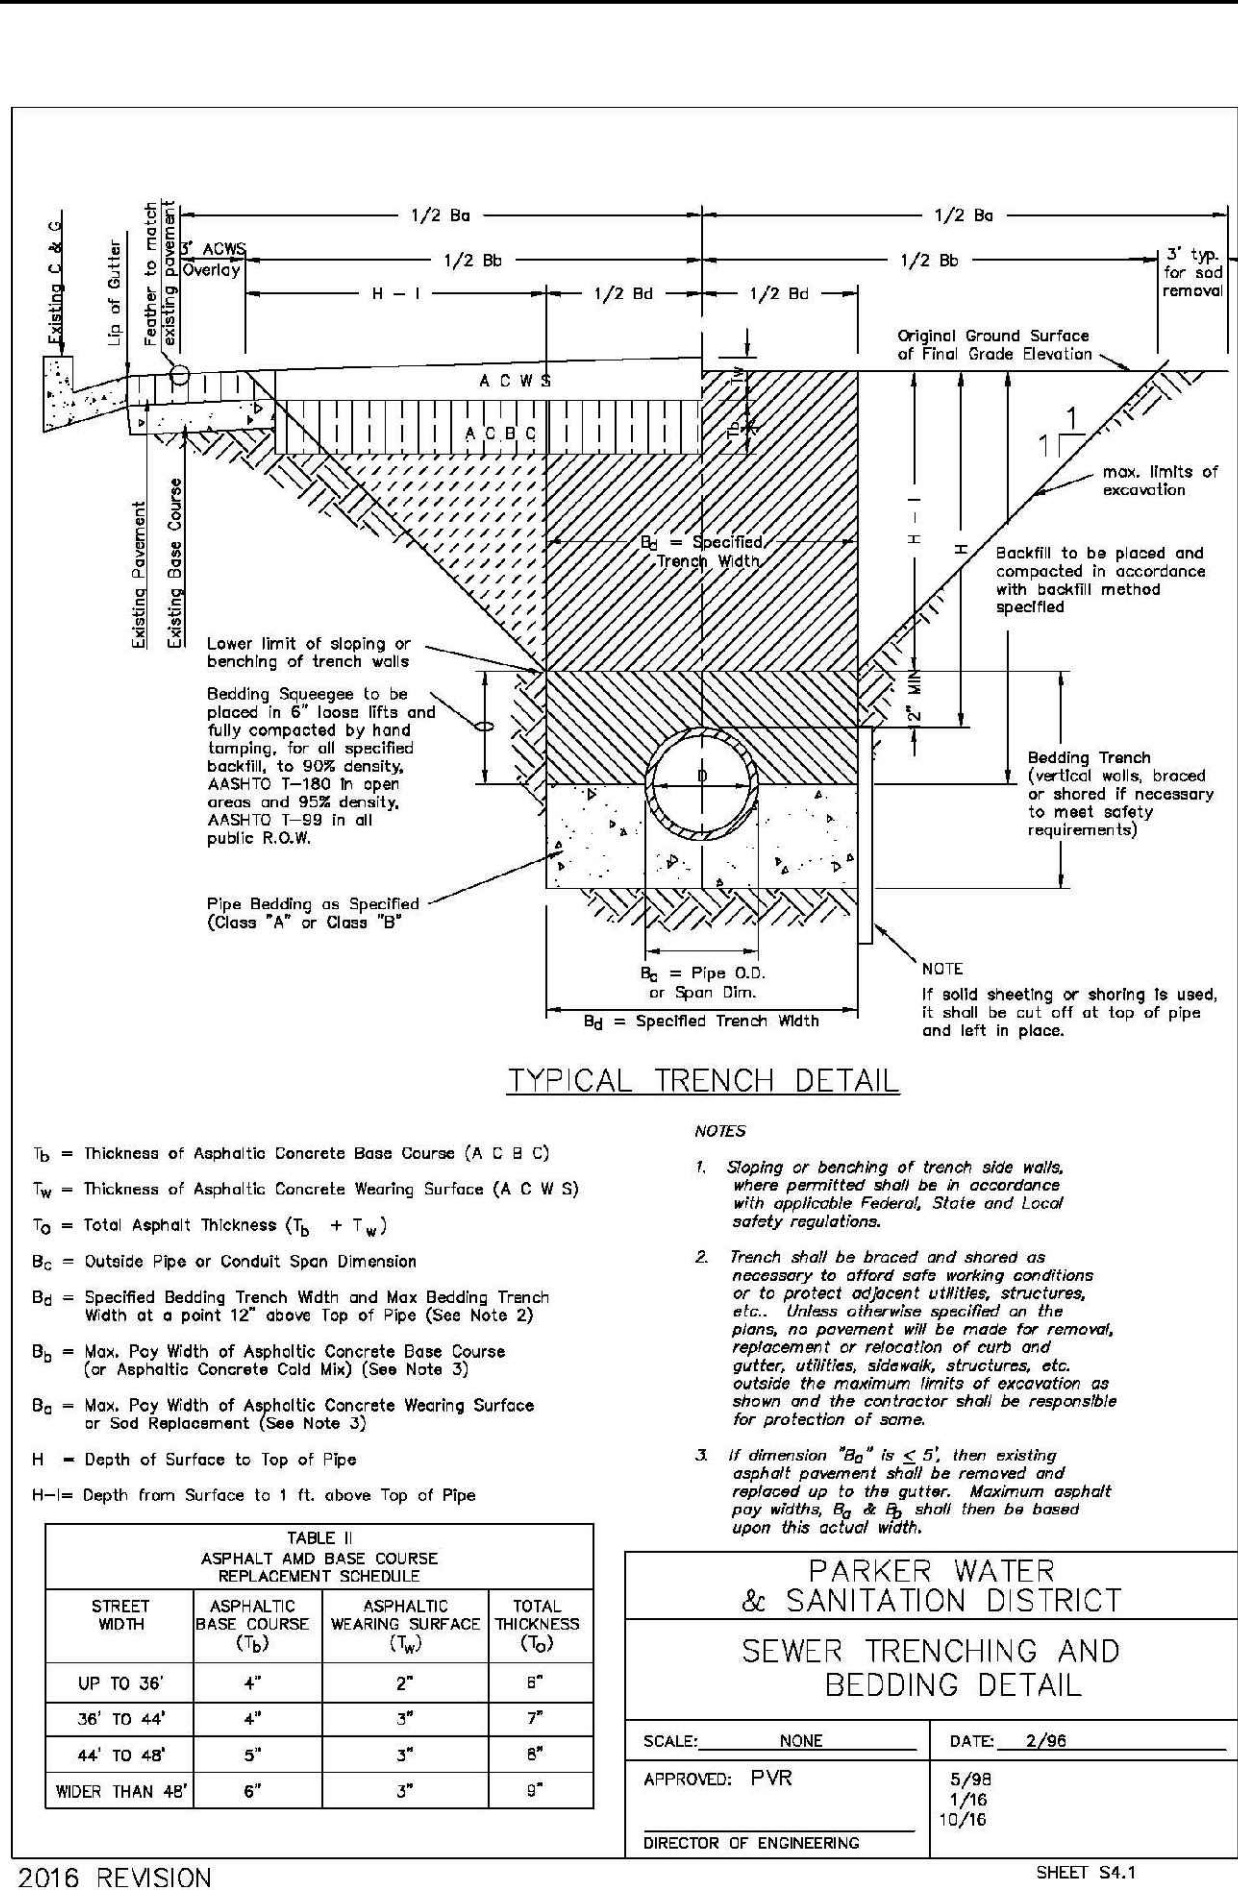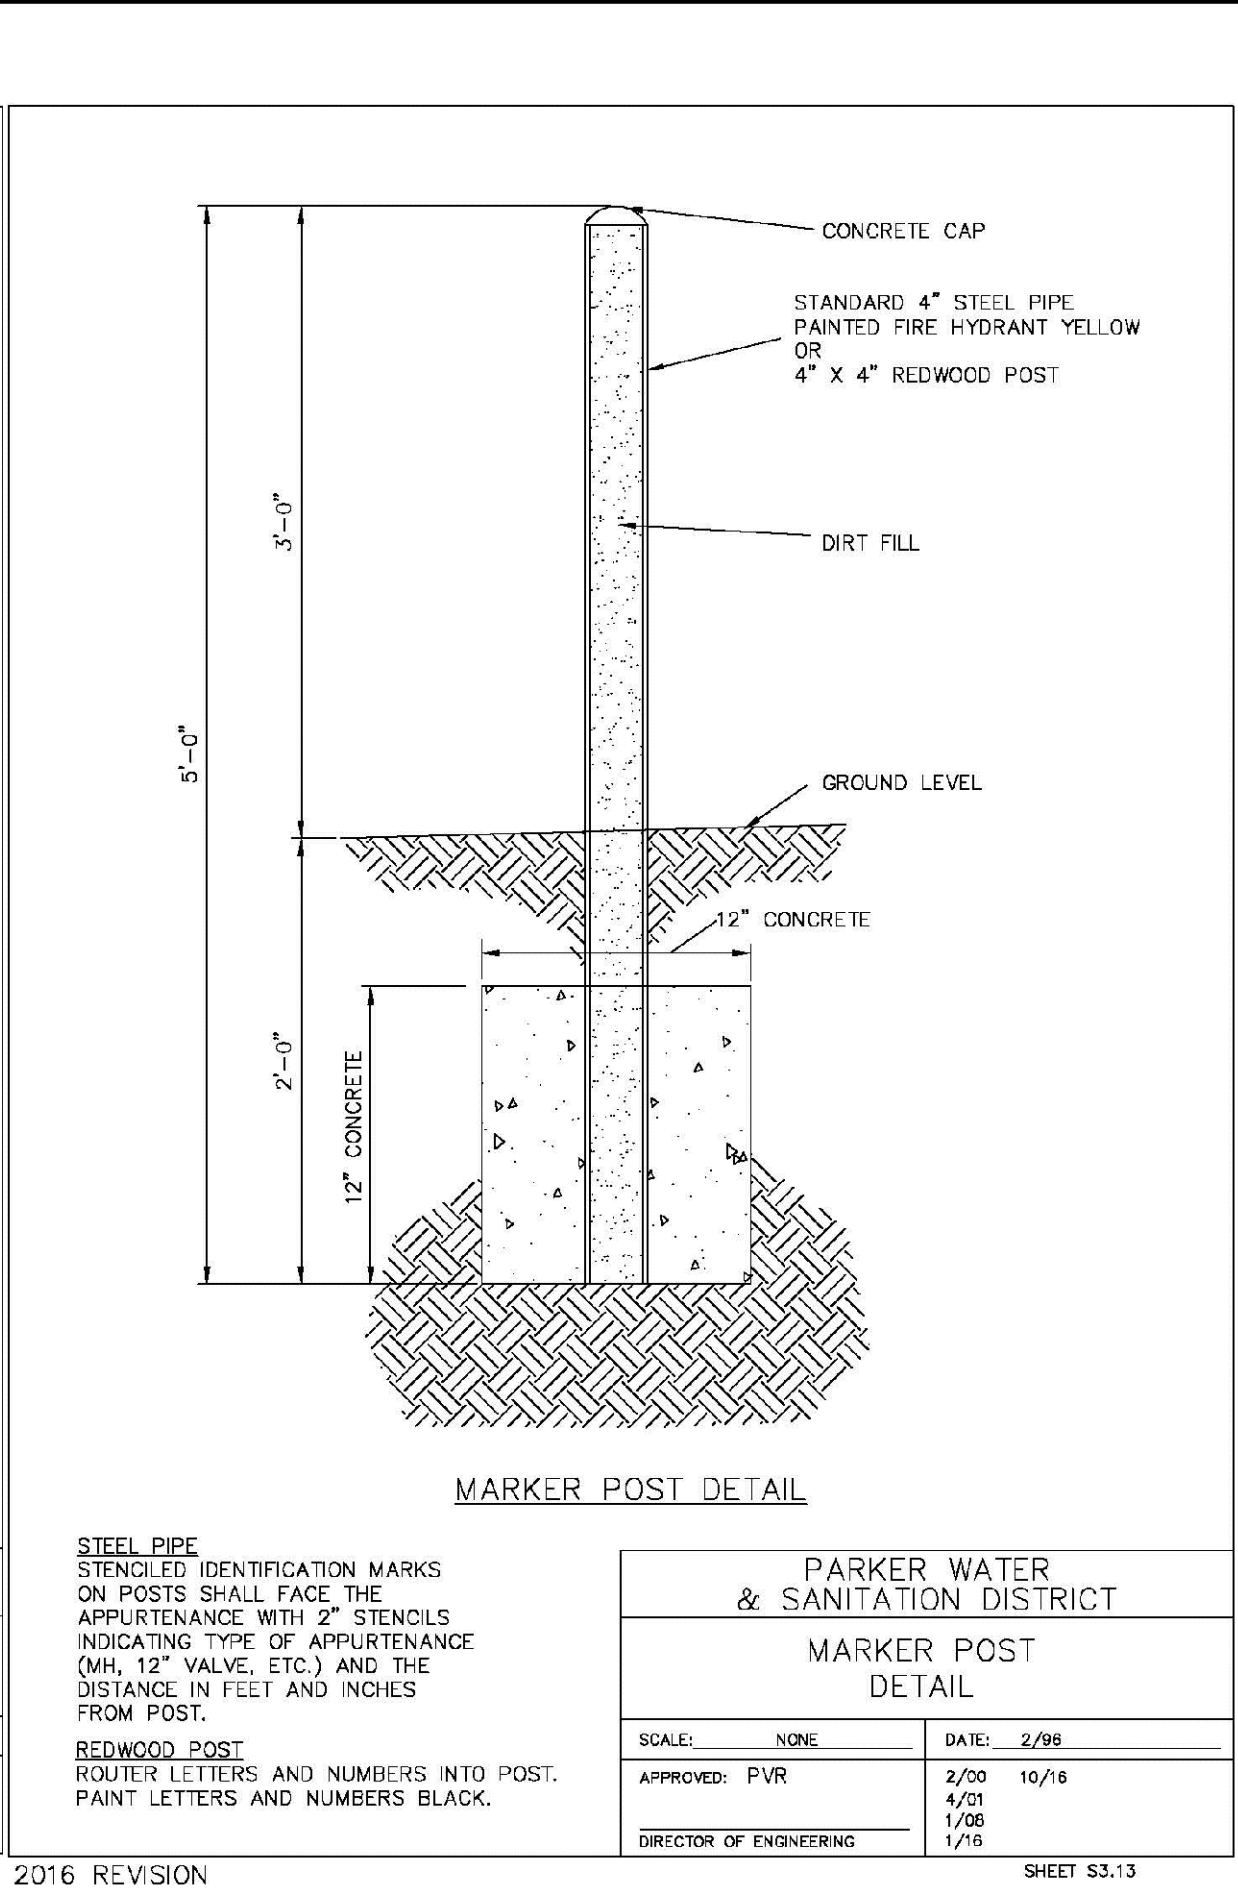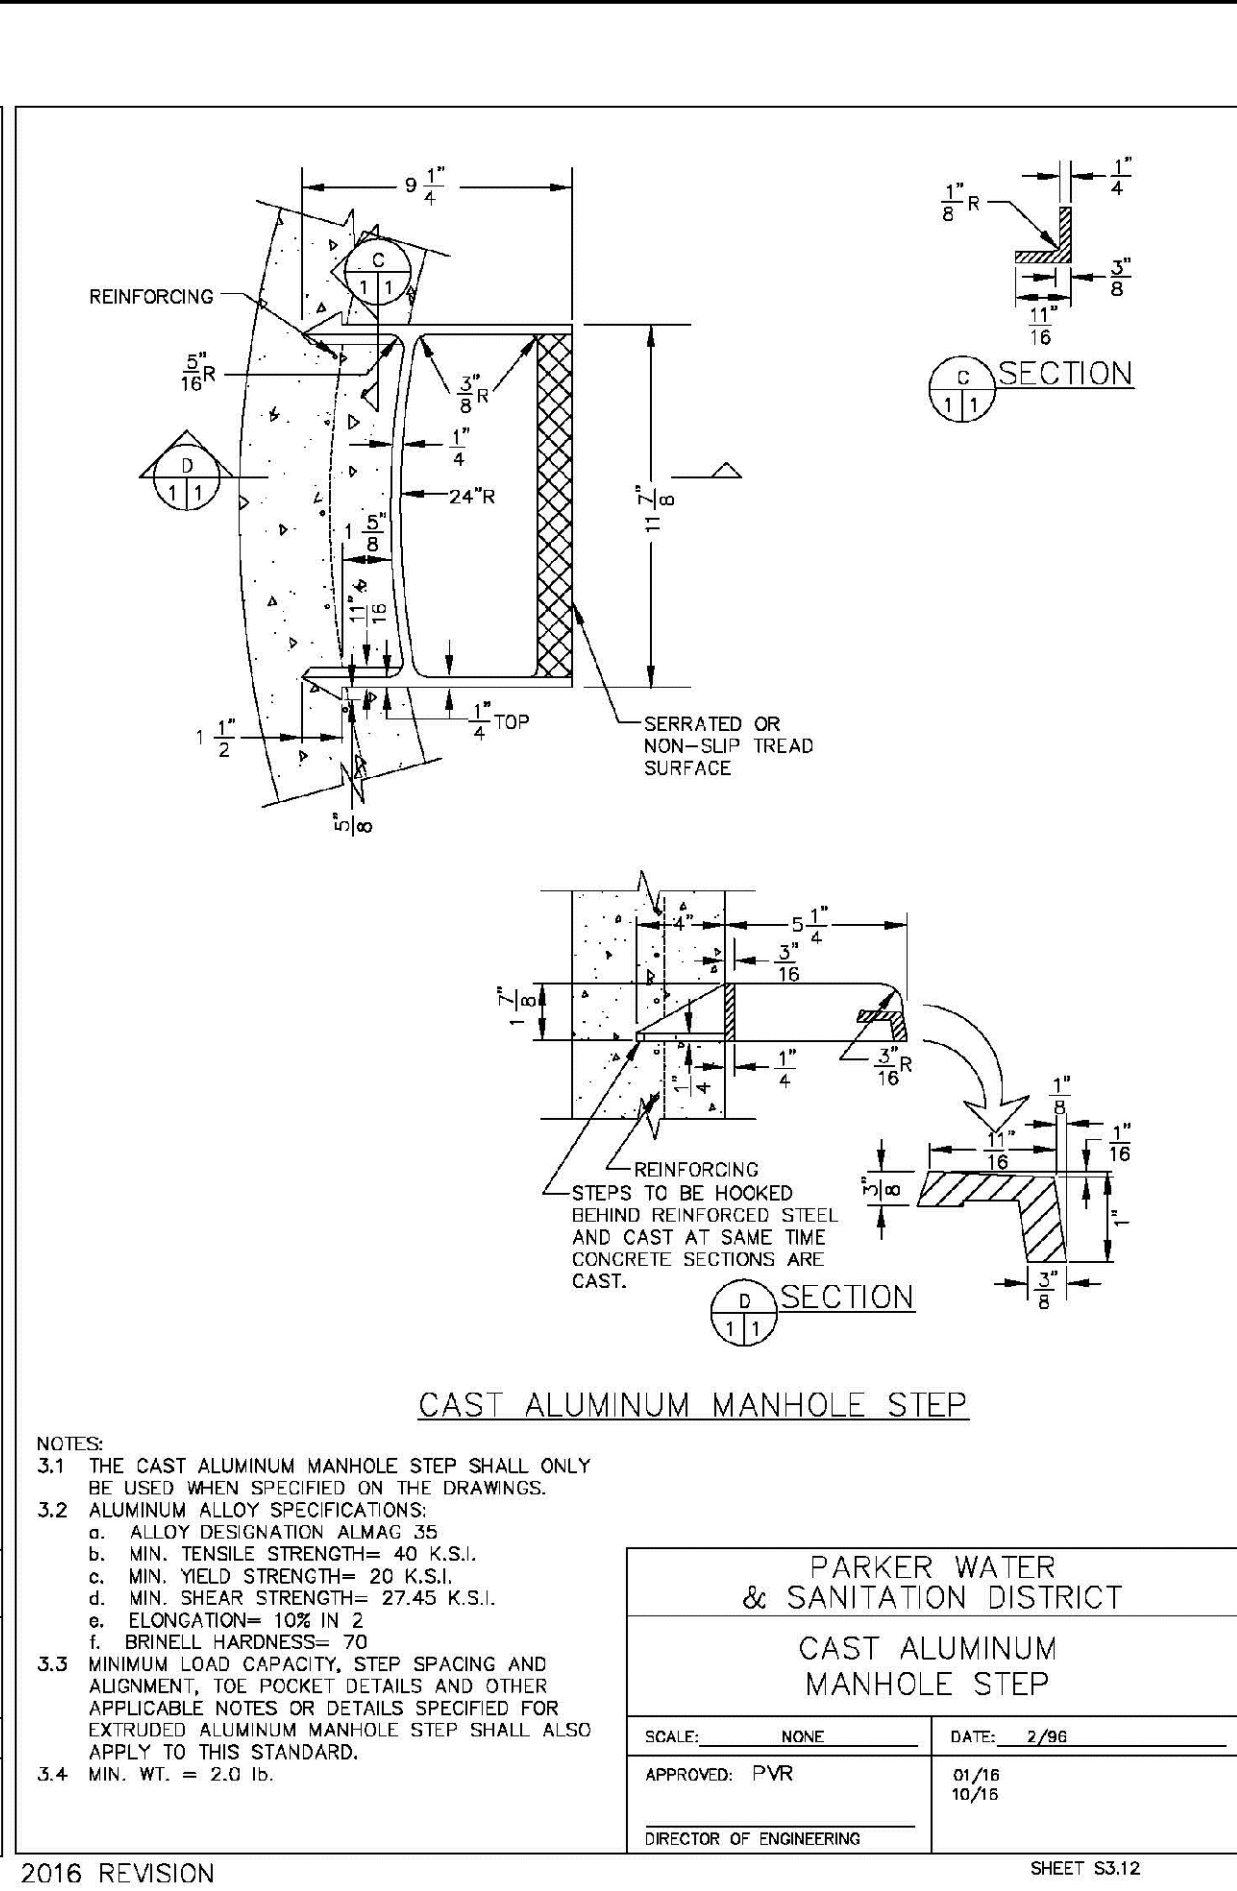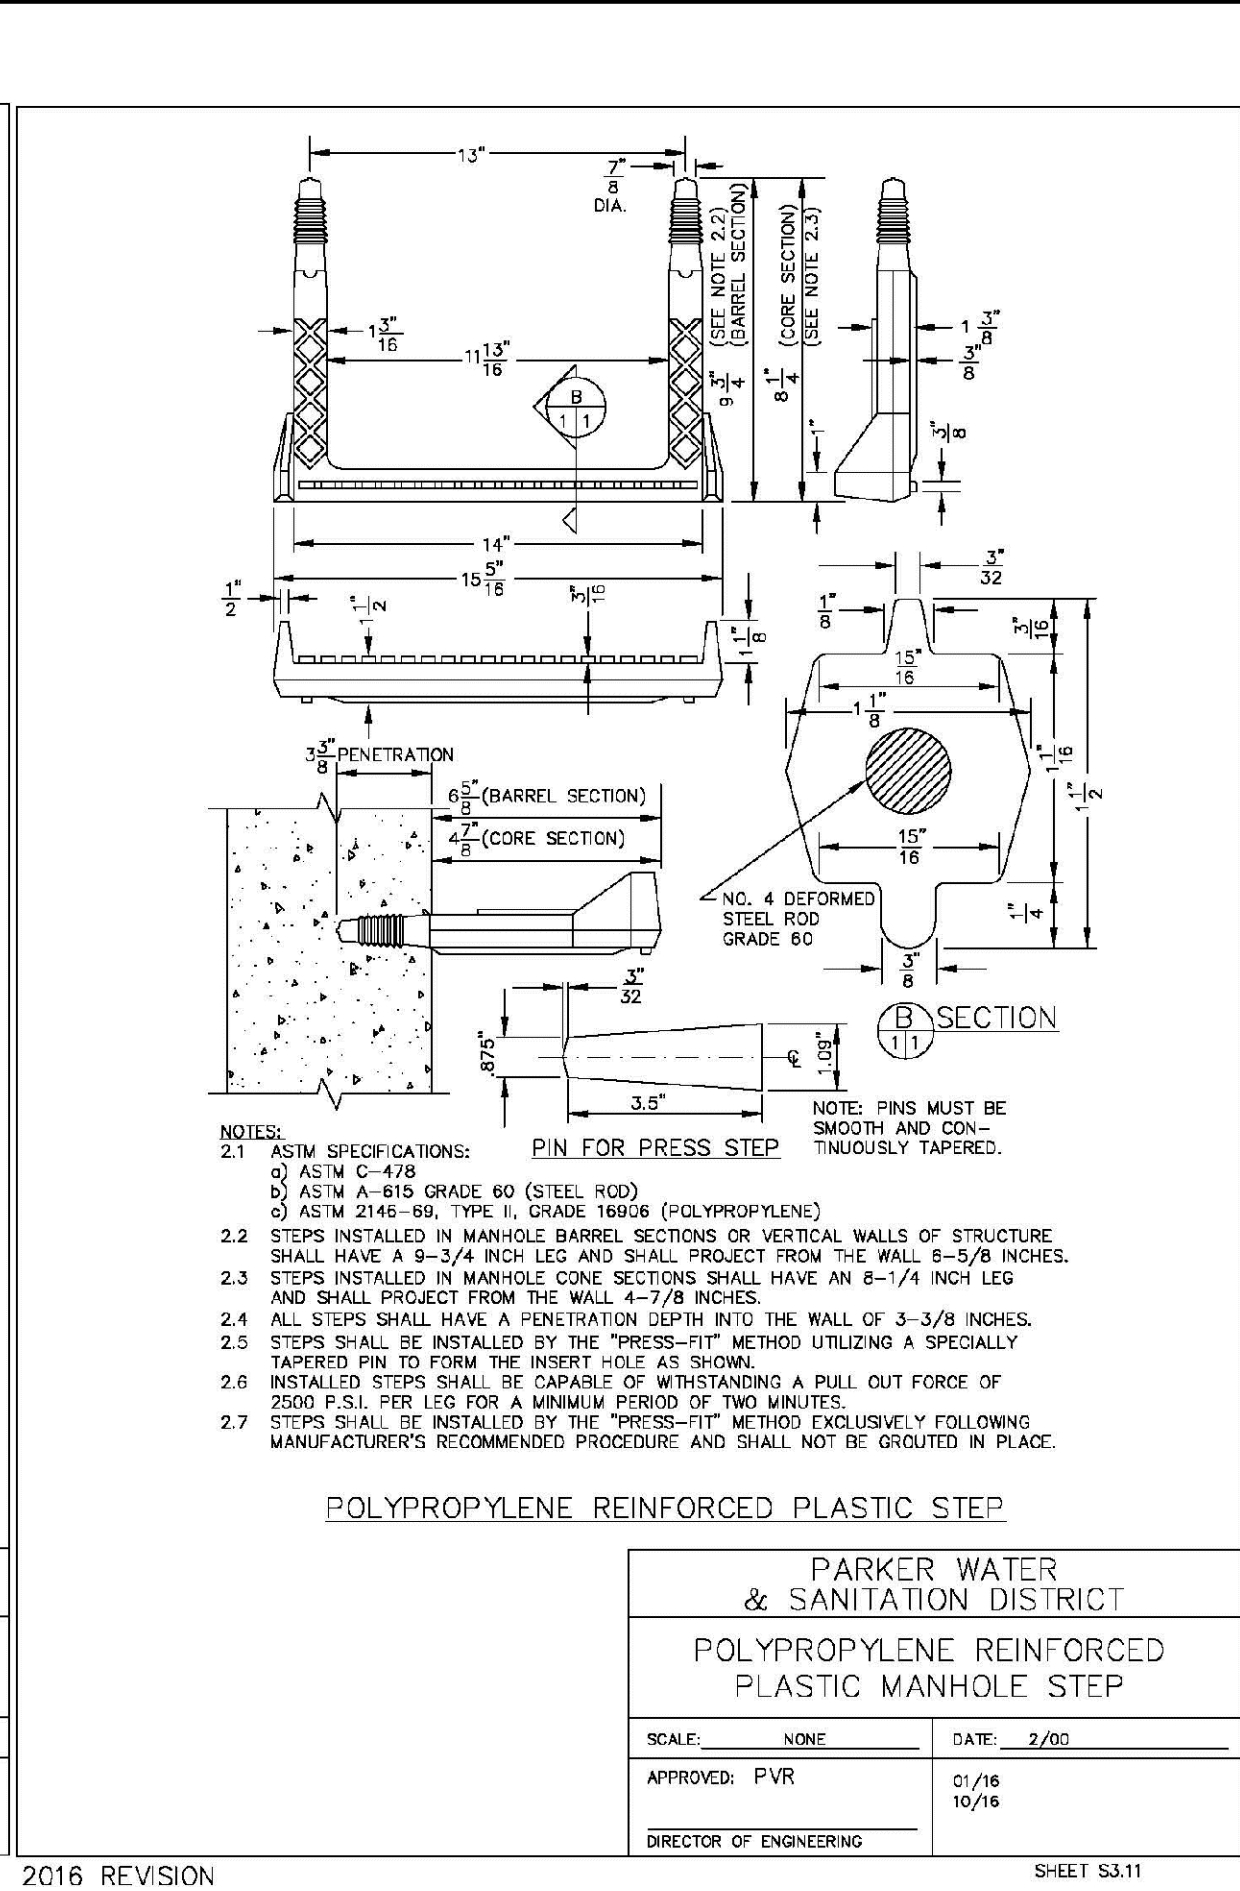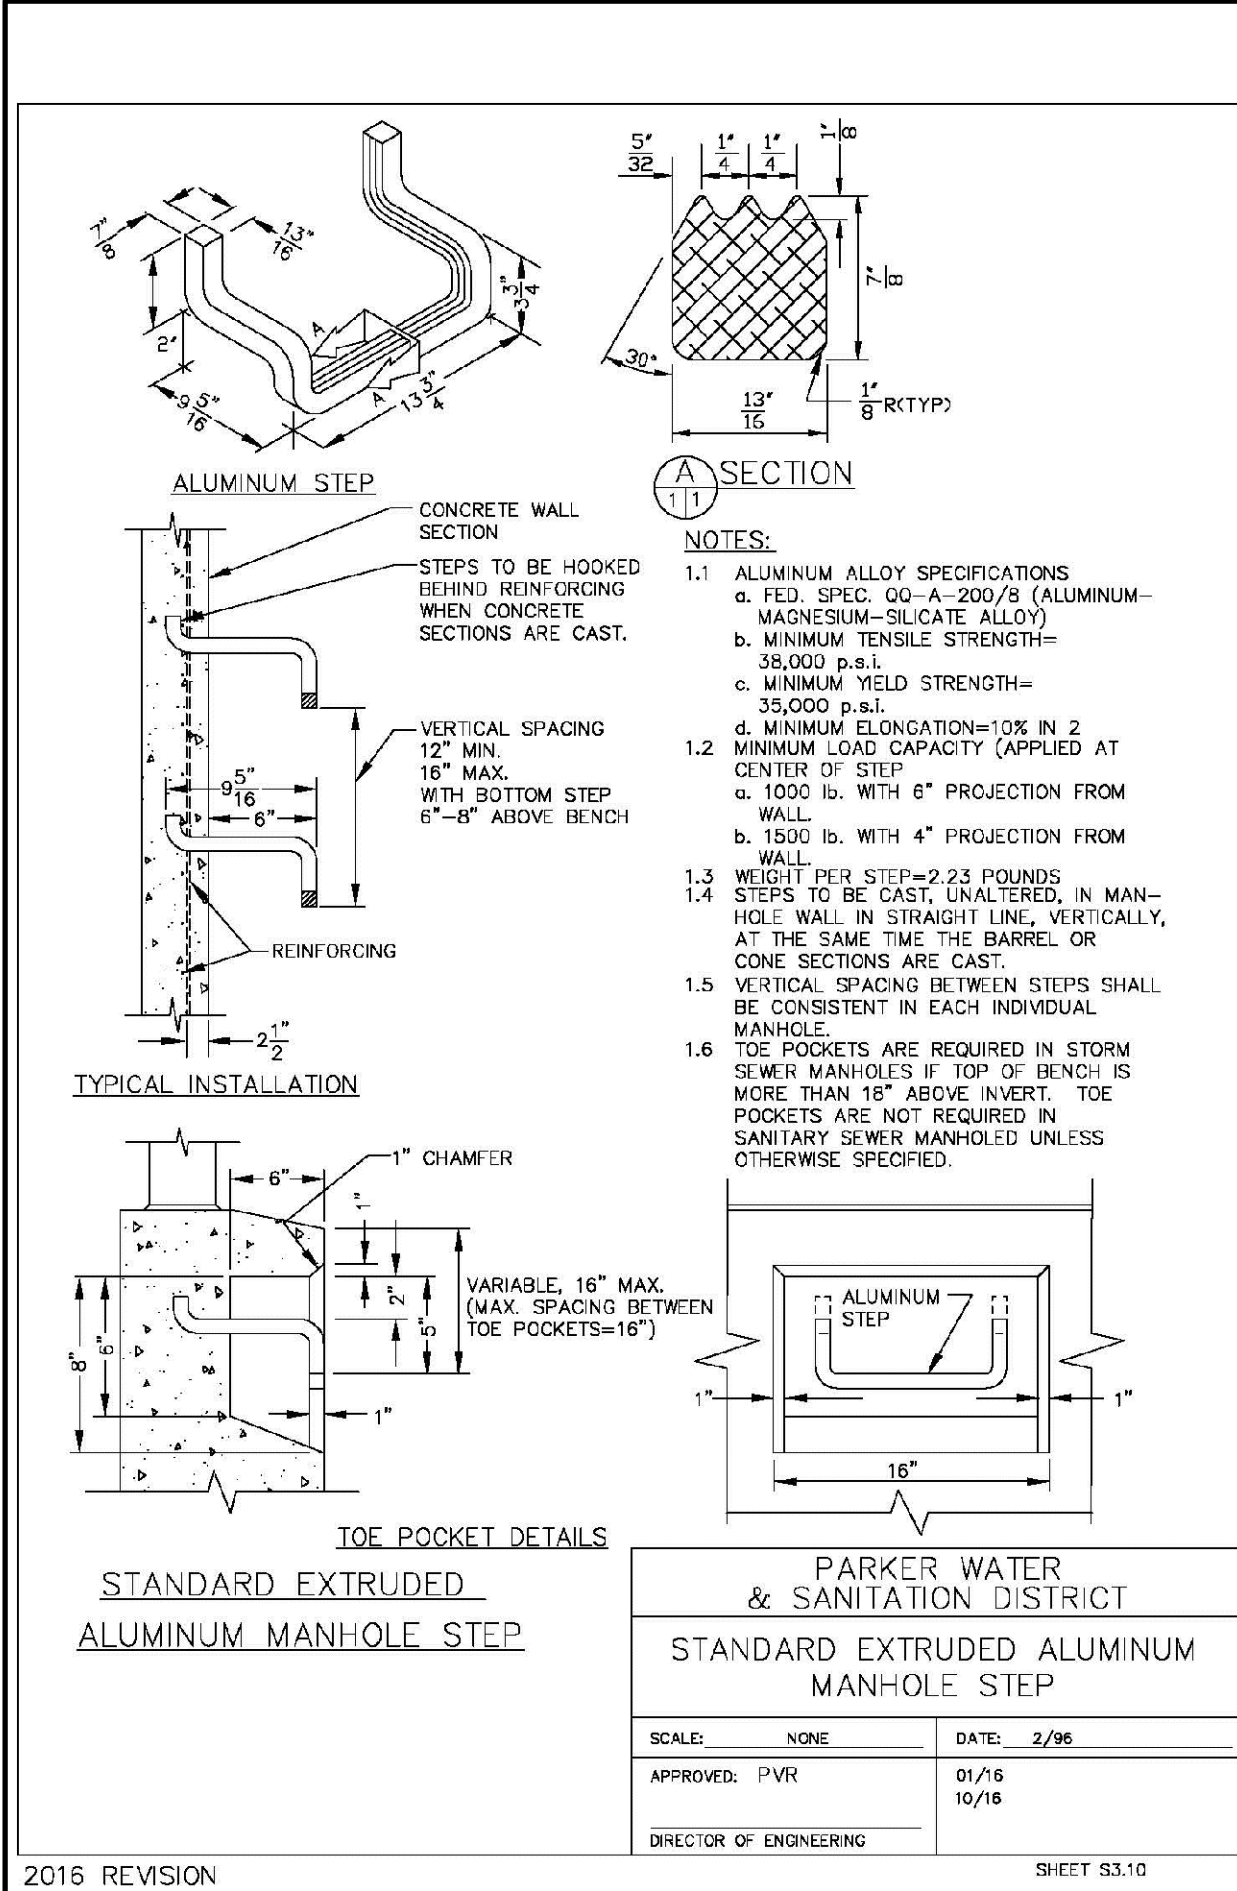

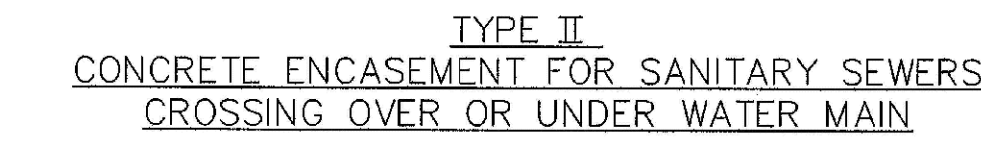

1. CONCRETE TO BE CAST AGAIN UNDISTURBED SOIL OR SHORING. IF OPTIONAL CONSTRUCTION JOINT IS USED & BOTTOM HALF OF CONCRETE IS FOUND DEFECTIVE, A ONE INCH LAYER OF SAND OR MORTAR SHALL BE PLACED BETWEEN BOTTOM OF SANITARY SEWER AND TOP OF CONCRETE.
2. LENGTH OF ENCASMENT FOR:
 - a. TYPE I OR II ENCASMENT SHALL EXTEND FULL TRENCH WIDTH EXCAVATED FOR PROPOSED SEWER OR CONDUIT.
 - b. TYPE I ENCASMENT SHALL EXTEND AT LEAST TO 10 FEET EACH SIDE OF WATER MAIN.
3. UNLESS OTHERWISE NOTED ON PLAN/PROFILE DRAWINGS, TYPE I, II & III ENCASMENTS NEED NOT BE REINFORCED. REINFORCEMENT, IF REQUIRED, SHALL BE SPECIFIED AND DETAILED SEPARATELY ON PLAN & PROFILE DRAWINGS.
4. TYPE I, II OR III ENCASMENTS ARE REQUIRED UNDER FOLLOWING CONDITIONS:
 - a. TYPE I OR TYPE II IF $d \leq 18"$ ($d \leq 12"$) REQUIRED FOR SANITARY SEWER CROSSING OVER OR UNDER WATER MAINS.

- (c) TYPE 1 IS REQUIRED FOR SANITARY SEWERS CROSSING OVER TOP WATER MAINS AND $d_s \leq 24"$ ($d_s \leq 18"$)
- (d) EXCEPT FOR UNUSUAL CIRCUMSTANCES, WATER MAIN CROSSINGS, UNDESIRABLE SOIL CONDITIONS, OR ENCOUNTERED, TYPE 1 ENCASEMENT MUST BE USED TO SATISFY
- (e) IF THE SANITARY SEWER IS REPLACED OR CONSTRUCTED OF DUCTILE IRON PIPE (DIP) WITH $d_s \leq 36"$ OR C-150, CONCRETE ENCASEMENT MAY NOT BE REQUIRED.
5. FILTER MATERIAL, BETWEEN CONDUITS TO BE:
 - (a) FOR COMPRESSIBLE MATERIAL, SUCH AS STYROFOAM, ETC. IF $d_s \leq 6"$.
 - (b) COMPACTED CLASS "B" BEDDING IF d_s , d_c , & $d_v \leq 6"$.
6. ENCASEMENT SHALL BE IN ENCASUREMENT FOUR CONCRETE OR UNDISTURBED SOIL.
7. SHORING OR SHEETING, IF USED, TO BE CUT OFF AT TOP OF ENCASEMENT.
8. THESE ENCASEMENT METHODS MAY ALSO BE APPLICABLE FOR CONDUITS OTHER THAN STORM OR SANITARY SEWER INSTALLATIONS.
9. IN CERTAIN SITUATIONS WHERE CONDUIT DIAMETER d_s IS 36" OR GREATER, PERMANENTLY EMBEDDED SANITARY SEWER MAY ALSO BE REQUIRED. IF REQUIRED, SUPPORTS SHALL BE IDENTIFIED AND DETAILED SEPARATELY ON PLAN AND PROFILE DRAWINGS.

PARKER WATER & SANITATION DISTRICT	
CONCRETE ENCASEMENT TYPE II	
SCALE: NONE	DATE: 2/96
APPROVED: JFN	5/98 4/01 1/08
DISTRICT ENGINEER	

SHEET 2



1. CONCRETE TO BE CAST AGAINST UNDISTURBED SOIL OR SHORING. IF OPTIONAL CONSTRUCTION JOINT IS USED & BOTTOM HALF OF ENCASEMENT IS POURED SEPARATELY, A ONE INCH LAYER OF SAND OR MORTAR SHALL BE PLACED BETWEEN THE TWO LAYERS OF SANITARY SEWER AND TOP OF CONCRETE.
2. LENGTH OF ENCASEMENT FOR:
 - (a) TYPE I & TYPE II ENCASEMENT SHALL EXTEND FULL TRENCH WIDTH EXCAVATED FOR PROPOSED SEWER OR CONDUIT.
 - (b) TYPE III ENCASEMENT SHALL EXTEND AT LEAST TO FEET EACH SIDE OF MAIN.
3. UNLESS OTHERWISE NOTED ON PLAN/PROFILE DRAWINGS, TYPE II & III ENCASEMENTS NEED NOT BE REINFORCED. REINFORCEMENT, IF REQUIRED, TO BE SPECIFIED AND DETAILED SEPARATELY ON PLAN & PROFILE DRAWING.

[illegible]

PARKER WATER & SANITATION DISTRICT	
CONCRETE ENCASUREMENT TYPE III	
SCALE: NONE	DATE: 2/98
APPROVED: PVR	5/98 1/15 10/16
DIRECTOR OF ENGINEERING	

SHEET S4.8



1 - NEW BENCH SHALL INCLUDE REINFORCEMENT TO CONTROL CONCRETE CRACKING.


PARKER WATER & SANITATION DISTRICT MANHOLE INVERT TIE-IN DETAIL	
SCALE: <u> NONE </u>	DATE: <u> 2/96 </u>
APPROVED: <u> PVR </u>	<u> 1/16 </u> <u> 10/16 </u>
<u> DIRECTOR OF ENGINEERING </u>	

SHEET S4.9




PARKER WATER & SANITATION DISTRICT	
MANHOLE STUB-OUT DETAIL	
SCALE: NONE	DATE: 2/16
APPROVED: PVR	1/16 10/16
DIRECTOR OF ENGINEERING	

SHEET S4.1

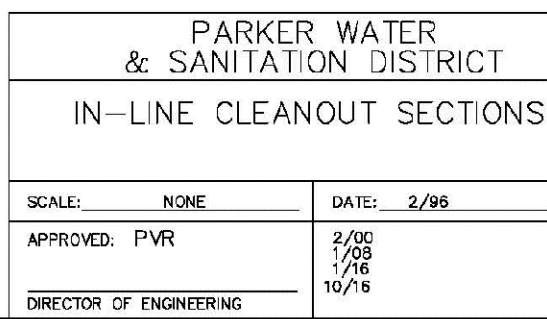

SHEET S4.12

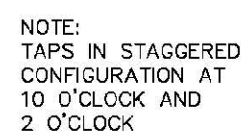

Sewer service connections shall be positioned at either the 2 o'clock or the 10 o'clock position on the circumference of the sewer main. On new installations, tie or wye fittings shall be used. When tapping into existing sewer main, a saddle connection or approved crown method shall be used. The minimum distance from either the bell or spigot end of the pipe shall be 3 feet. The minimum distance from the center of a manhole to the center of a connection shall be 10 feet. The minimum distance from the manhole trench to the normal pipe trench, whichever is greater, shall be 3 feet. A maximum of 4 sewer service connections shall be allowed per 20 foot length of pipe. In all cases, a specific soils investigation should be conducted to determine if the proposed tapping will be within allowable limits regardless of the number of taps involved.

DOMESTIC SEWER TAPPING DETAIL

PARKER WATER & SANITATION DISTRICT	
DOMESTIC SEWER TAPPING DETAIL	
SCALE: <u> NONE </u>	DATE: <u> 2/96 </u>
APPROVED: PWR	4/01: 1/CB
	1/16
DIRECTOR OF ENGINEERING	10/16

SHEET S4.13







1. SADDLE FITTINGS TO BE PER ASTM D3034.
2. CONNECTION SHALL BE Y - SADDLE WITH TWO BONDS

PARKER WATER & SANITATION DISTRICT	
P.V.C. SADDLE CONNECTION DETAIL	
SCALE: NONE	DATE: 2/96
APPROVED: PVR	1/15 10/16
DIRECTOR OF ENGINEERING	

SHEET S4.14

    SHEET W1.1



N:\PROJECTS\SSR\BANCOC\ENGINEERING\SSR\BANCOC\WATER AND SANITATION\WATER DETAILS.DWG, CDDVA, 3/6/2016 4:33 PM

